

BEWARE OF UNDERGROUND SERVICES
THE LOCATIONS OF UNDERGROUND SERVICES ARE
APPROXIMATE ONLY AND THEIR EXACT POSITION
SHOULD BE PROVEN ON SITE. NO GUARANTEE IS
GIVEN THAT ALL EXISTING SERVICES ARE SHOWN.

RE	REVISIONS:			SCALE BAR		
				0 1 2 3 4 5m 10m		
				SCALE 1:100		
				COPYRIGHT © THIS DRAWING IS COPYRIGHT AND THE PROPERTY OF VAN DER MEER (NSW) PTY LTD. IT MUST NOT BE RETAINED, COPIED OR USED WITHOUT THE AUTHORITY OF VAN DER MEER (NSW) PTY LTD. DISCLAIMER THIS DRAWING AND ITS CONTENTS ARE ELECTRONICALLY GENERATED, PURPOSES ONLY, UNLESS SIGNED. FIGURED DIMENSIONS TAKE		
P No	ISSUE FOR APPROVAL REVISION DESCRIPTION	YK DRAWN	25.10.22 DATE	ARE CONFIDENTIAL AND MAY ONLY BE USED FOR THE PURPOSE FOR WHICH THEY WERE INTENDED. VAN DER MEER (NSW) PTY LTD. WILL NOT ACCEPT RESPONSIBILITY FOR ANY CONSEQUENCES ARISING FROM THE USE OF THE DRAWING FOR OTHER THAN ITS INTENDED PURPOSE OR IF IN DOUBT - ASK. PRECEDENCE OVER SCALED. DO NOT SCALE REDUCED SIZE DRAWINGS. VERIFY DIMENSIONS PRIOR TO COMMENCING ANY ON-SITE OR OFF-SITE WORKS OR FABRICATION. IF IN DOUBT - ASK.		






CLIENT	RESIDENTIAL REDEVELOPMENT
	1 LANDFORD AVENUE KILLARNEY HEIGHTS, NSW 2087
TESSERARCH PTY LTD	DRAINAGE LAYOUT


31 WOODSTOCK ROAD, CARLINGFORD, NSW 2118

RESIDENTIAL REDEVELOPI 1 LANDFORD AVENUE	MENT	APPROVAL ISSUE NOT TO BE USED FOR CONSTRUCTION			
KILLARNEY HEIGHTS, NSW 2087	PROJECT LEADER AW	DESIGNER YK	SIGNATURE		
DRAINAGE LAYOUT	DRAFTSPERSON YK	AS SHOWN	OCT 2022	SHEET SIZE A1	
ROOF	JOB No. SY2120	SY212054		REVISION	

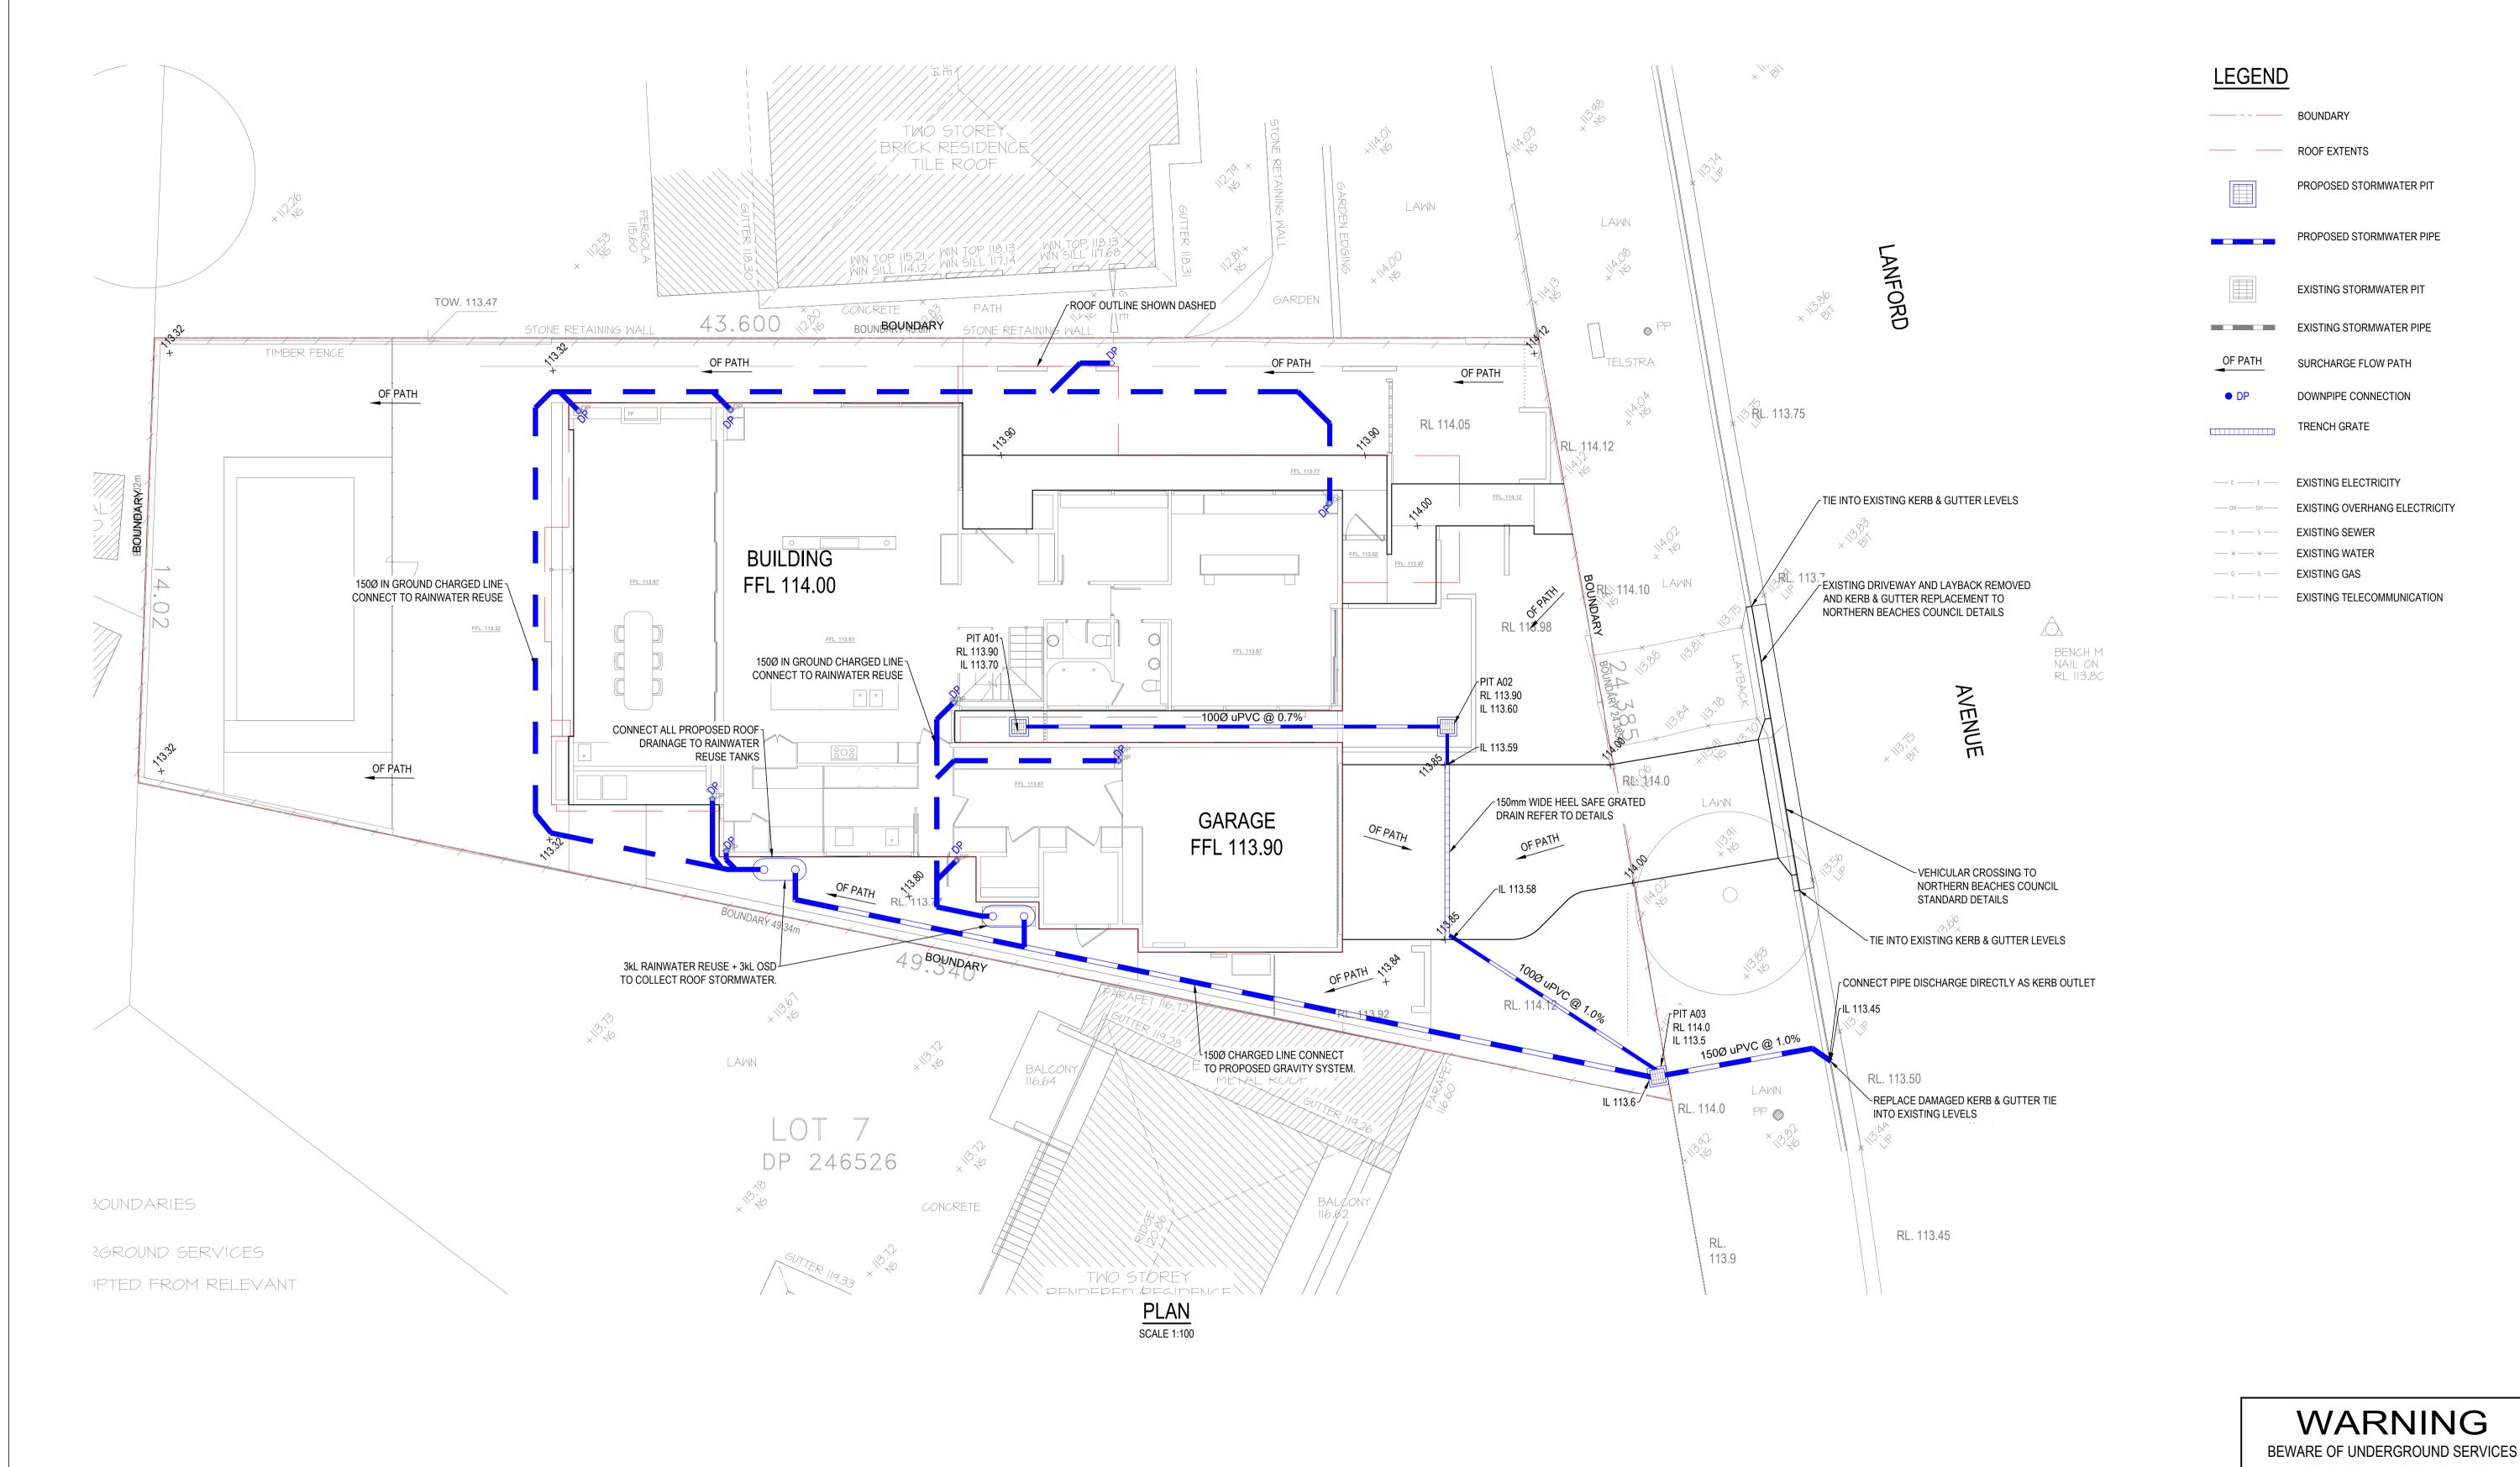

BEWARE OF UNDERGROUND SERVICES

THE LOCATIONS OF UNDERGROUND SERVICES ARE
APPROXIMATE ONLY AND THEIR EXACT POSITION
SHOULD BE PROVEN ON SITE. NO GUARANTEE IS
GIVEN THAT ALL EXISTING SERVICES ARE SHOWN.

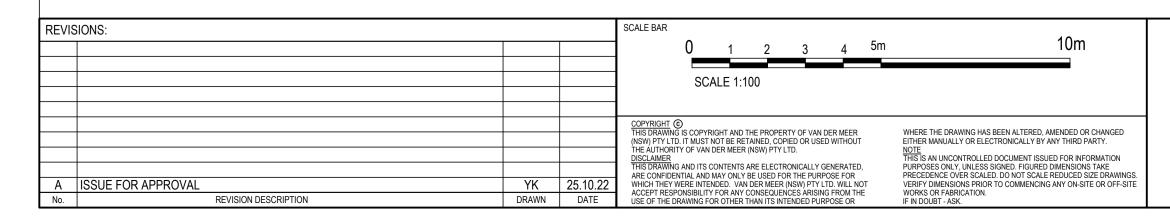





CLIENT	PROJECT TITLE RESIDENTIAL REDEVELOPMENT	
	1 LANDFORD AVENUE KILLARNEY HEIGHTS, NSW 2087	
TESSERARCH PTY LTD	DRAINAGE LAYOUT	

GROUND LEVEL

31 WOODSTOCK ROAD, CARLINGFORD, NSW 2118

APPROVAL ISSUE NOT TO BE USED FOR CONSTRUCTION				
PROJECT LEADER AW	DESIGNER YK	SIGNATURE		
DRAFTSPERSON YK	AS SHOWN	OCT 2022	SHEET SIZE A1	
JOB No. SY212054		DRAWING No.	REVISION	