

Design Certification

Tuesday 26th October 2022

Attn: C.G.M.B. CO PTY LTD

C/ Mr John Kinnear

Dingo Partners

Shop 1, 43-458 North Steyne, Manly NSW 2095

Dear Matthew,

RE: DA 2022/00869 – Grease Arrestor Ventilation at 43-45 North Steyne, Manly

Design Certification

We wish to advise that Hydraulic Services Documentation for the above project have been designed in accordance with the following Standards, Codes, Authorities requirements:

Title of Engineering	Standard, Code or Authority requirements
Trade Waste Drainage	National Construction code (NCC/BCA) vol.3.
system	AS3500.3, AS4072.1 & AS1530.4
Full name of Designer:	Russell Druce
Qualifications:	Associate Diploma in Hydraulic Engineering
	Hydraulic Consultants Association of Australasia (HCAA)
Experience:	Eighteen (18) years in experience in the Hydraulic Services design industry.

Address of Designer: 40A Cowan Rd, Mount Colah.

Email Address: <u>rdruce@outlook.com</u>

Documentation Reference:

DRAWING NO.	DRAWING TITLE
1220-H01	Schematic Section Y-Y
1220-H02	Roof Plan & Detail-Grease Arrestor Vent Line


Should you require any further information or explanation, could you please contact the under

Signed.

Yours faithfully,

to ł

Russell Druce

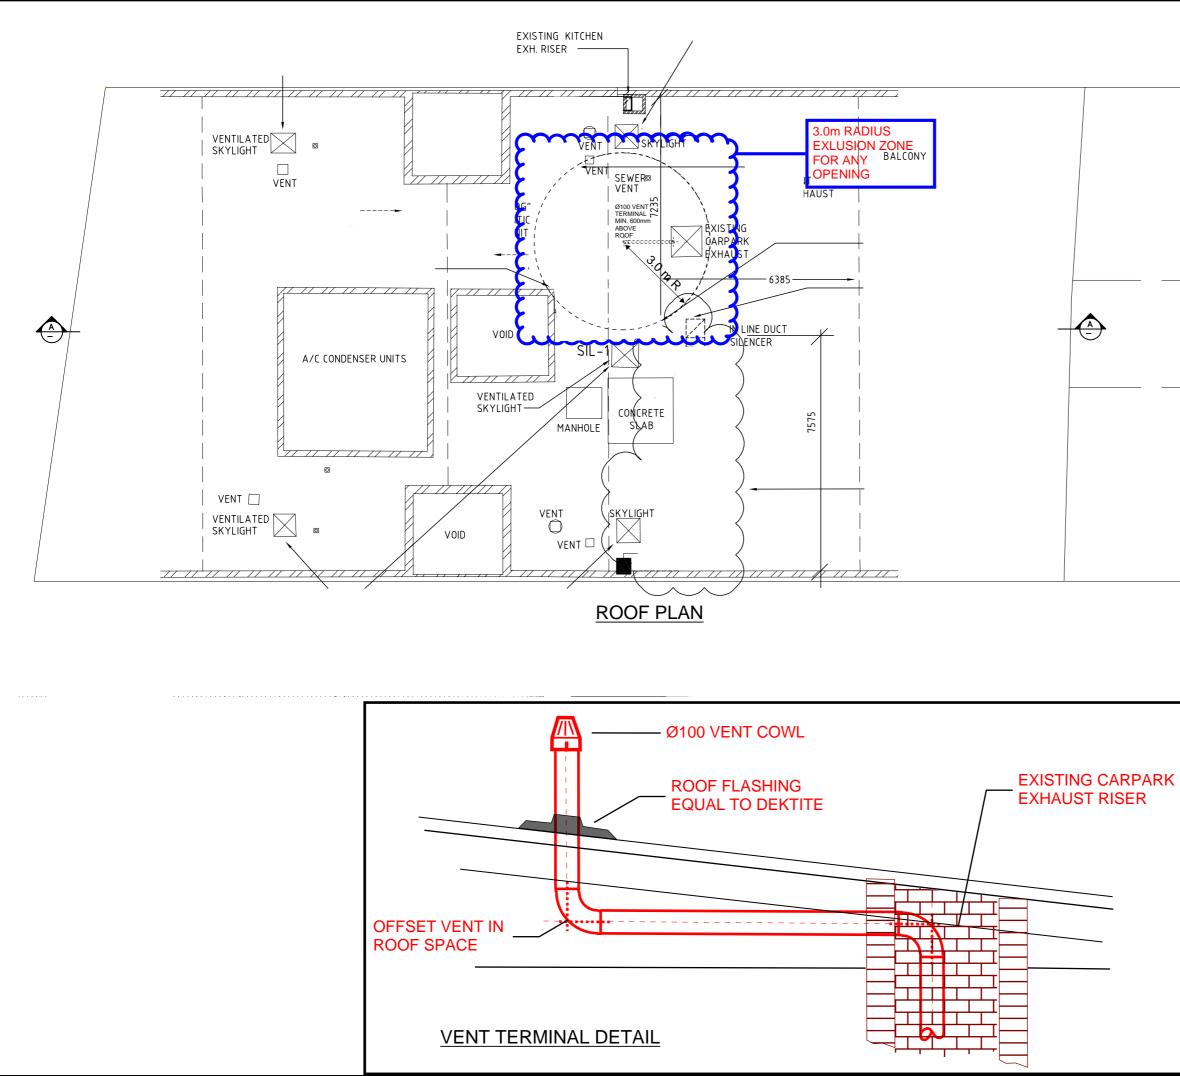

Russell Druce HYDRAULIC ENGINEER **DESIGN DRAWING**

_. _ _ _ _ _ _ _ _

43-45 NORTH STEYNE MANLY

ROOF PLAN & DETAIL-GREASE ARRESTOR VENT LINE

SCALE: 1:100 @ A1

DATE: 24.10.2022 DRAWN BY: R.DRUCE DWG NO.

ISSUE.

H-02

С