## **OPAL SEASIDE**

184-194 GARDEN STREET, WARRIEWOOD, NSW



	DRAWI	NG LIST - GROUPGSA
	Sheet Number	Sheet Name
	DA-0000	NZLE PAGE / LOCATION PLAN
	DA-1100	DEMOLITION PLAN - STAGE 1
>	DA-1100.1	DEMOLITION PLAN - STAGE 2
1	DA- 101	STE PLAN
	DA-1102	SITE ANALYSIS-EXISTING
	DA-1401	SHADOWS DIAGRAMS
	DA-2000	GROUND FLOOR PLAN
	DA-2001	LEVEL 1 FLOOR PLAN
	DA-2002	ROOF PLAN
	DA-3000	ELEVATIONS - SHEET 1
	DA-3001	ELEVATIONS - SHEET 2
	DA-3002	ELEVATIONS - SHEET 3
	DA-3003	SOUTH ELEVATION DESIGN INTENT
	DA-3100	SECTIONS 1
	DA-3200	PHOTOMONTAGES
	DA-3201	PERSPECTIVES - SHEET 1
	DA-3202	PERSPECTIVES - SHEET 2
	DA-4000	GFA CALCULATION
	DA-4001	STAGING DIAGRAM
	DA-8300	MATERIALS & FINISHES

- 1 STAGING LINE ADJUSTED TO ALLOW FOR EGRESS
- **DURING CONSTRUCTION** - PROPOSED TEMPORARY CARPARK TO PROVIDE
- **CARSPACE DURING STAGE 1 CONSTRUCTION**
- DEMOLITION PLAN DIVIDED INTO TWO DRAWINGS TO REFLECT STAGING
- 4 PLAY AREA INCLUDED. ROOF EXTENDED TO COVER
- 5 FIRE ISOLATED STAIR RELOCATED TO THIS LOCATION IN LIEU OF OPEN ENTRY STAIRS
- ACTIVITY ROOM LOCATED ON GROUND FLOOR
- AND LEVEL 1 IN LIEU OF OPEN ENTRY STAIRS - ALLIED HEALTH KIT INCLUDED.
- REMOVAL OF 6 BEDROOMS.
- STAFF COURTYARD FFL ALIGNED WITH STAFF
- 9 INTERCONNECTING DOORS ADDED
- 10 TERRACE AND BALCONIES WITH ROOF ADDED TO **COURTYARD 5. REVISED DESIGN AND LAYOUT**
- 11 ROOM SIZE DECREASED TO ACCOMODATE FIRE ISOLATED STAIRS. PURPOSE FOR STAFF TRAINING
- 12 ACTIVITY ROOM AND FUNCTION ROOM COMBINED TO BE MULTI-PURPOSE ROOM
- 13 ROOF TERRACE DESIGN REVISED
- 14 PERGOLA ADDED TO COURTYARD 1
- 15 AUDIO ROOM LOCATION TO MATCH WITH GROUND
- 16 SOLAR PANELS INCLUDED
- 17 ADDITIONAL CARPARKING ADDED FOR ALLIED
- HEALTH 18 - PERGOLA ADDED TO COURTYARD 4 AND 5
- 19 MINOR ADJUSTMENTS TO INTERNAL ADMIN. LAYOUT
- 20 ESCAPE STAIRS ADJUSTED TO SUIT LEVELS
- 21 PLANTER BED LAYOUT ADJUSTED
- 22 ADJUSTMENTS TO WINDOW FENESTRATION DUE TO ADDITION OF ALLIED HEALTH

A DA SUBMISSION

B S4.55 SUBMISSION 25/06/19



### **S4.55 SUBMISSION**

Project Management Midson Group Suite 7, 33 Alexandra Street

midson

Tel. 02 9868 6923 eghali@midsongroup.com.au www.midsongroup.com.au Building Engineering Services

Northrop Level 11, 345 George Street Sydney NSW 2000

yogesh@sydney.northrop.com.au \_www.northrop.com.au\_\_ Civil and Structural Consultant

H&H Consulting Level 5, 79 Victoria Ave Chatswood, NSW, 2067 Tel.9417 8400

afrancis@hhconsult.com.au \_www.henryandhymas.com.au

Landscape Architect TAYLOR BRAMMER 218 Oxford Street Woollahra NSW 2025

Tel.9387 8855 CKratochvil@taylorbrammer.com.au www.taylorbrammer.com.au Traffic Engineer

48 Chandos Street St Leonards NSW 2065 Tel.9439 7288

\_www.ttw.com.au\_\_ Bushfire Consultant BCBHS Unit 16, 2 Marina Close

Paul.Yannoulatos@ttw.com.au

MT KURING-GAI NSW 2080 Tel.9457 6530 Wayne@bcbhs.com.au

Arterra Design Epping, NSW, 2121, Australia

Tel.9957 2466 rsmart@arterra.com.au \_www.arterra.com.au\_ Land Surveyor Bee & Lethbridge

First floor Suite 2-14 Starkey Street Forestville, NSW, 2087 Tel.9451 6757 warren@beeleth.com.au

OPAL SEASIDE Level 27, 135 King Street,

Sydney NSW 2000 Fax. 0882411690 www.opalagedcare.com.au communications@opalagedcare.com.au

Tel. 028241 1600





T +612 9361 4144 F +612 9332 3458

www.groupgsa.com

architecture interior design urban design landscape nom architect M. Sheldon 3990 Project Title

OPAL SEASIDE 184 - 194 Garden Street Warriewood NSW

#### TITLE PAGE / LOCATION PLAN


Scale		
Drawing Created	(date)	01/18
Drawing Created	(by)	
Plotted and checked by		
Verified		
Approved		
Project No	Drawing No	Is


### 160760 DA-0000

This drawing is the copyright of Group GSA Pty Ltd and may not be altered, reproduced or transmitted in any form or by any means in part or in whole without the written permission of Group GSA Pty Ltd. All levels and dimensions are to be checked and verified on site prior to the commencement of


components. Do not scale drawings. Use figured Dimensions.


any work, making of shop drawings or fabrication of

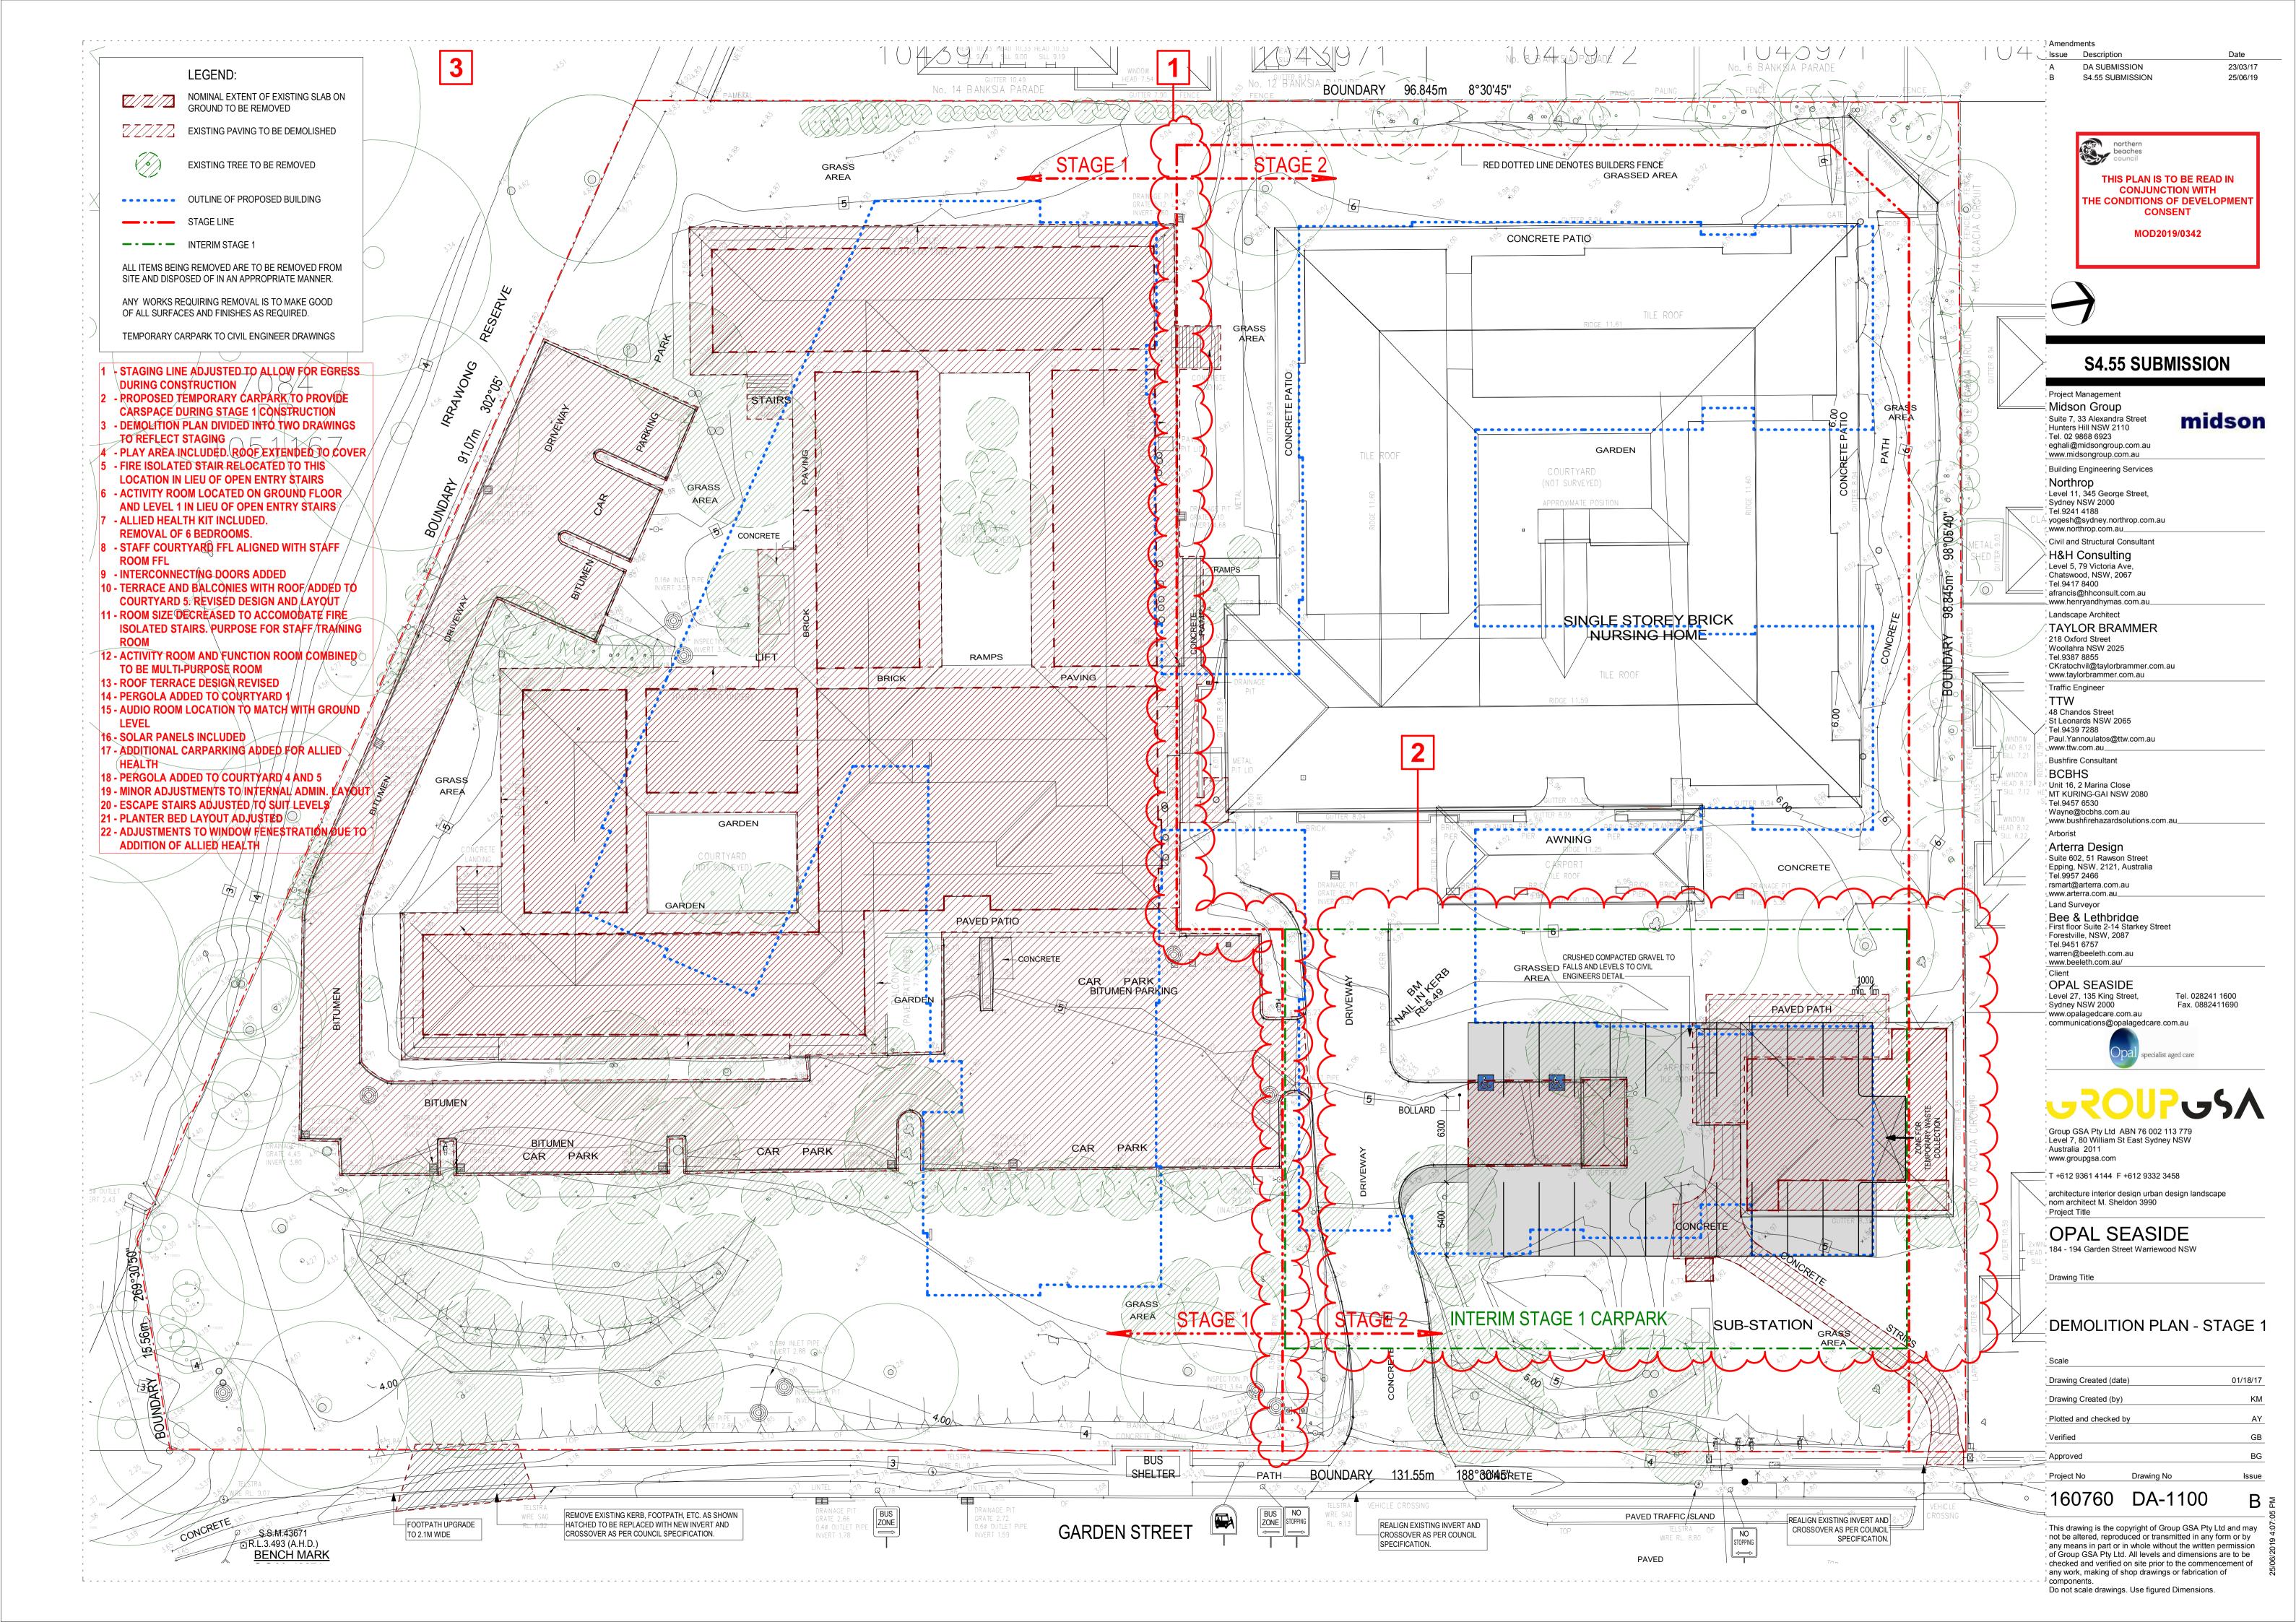


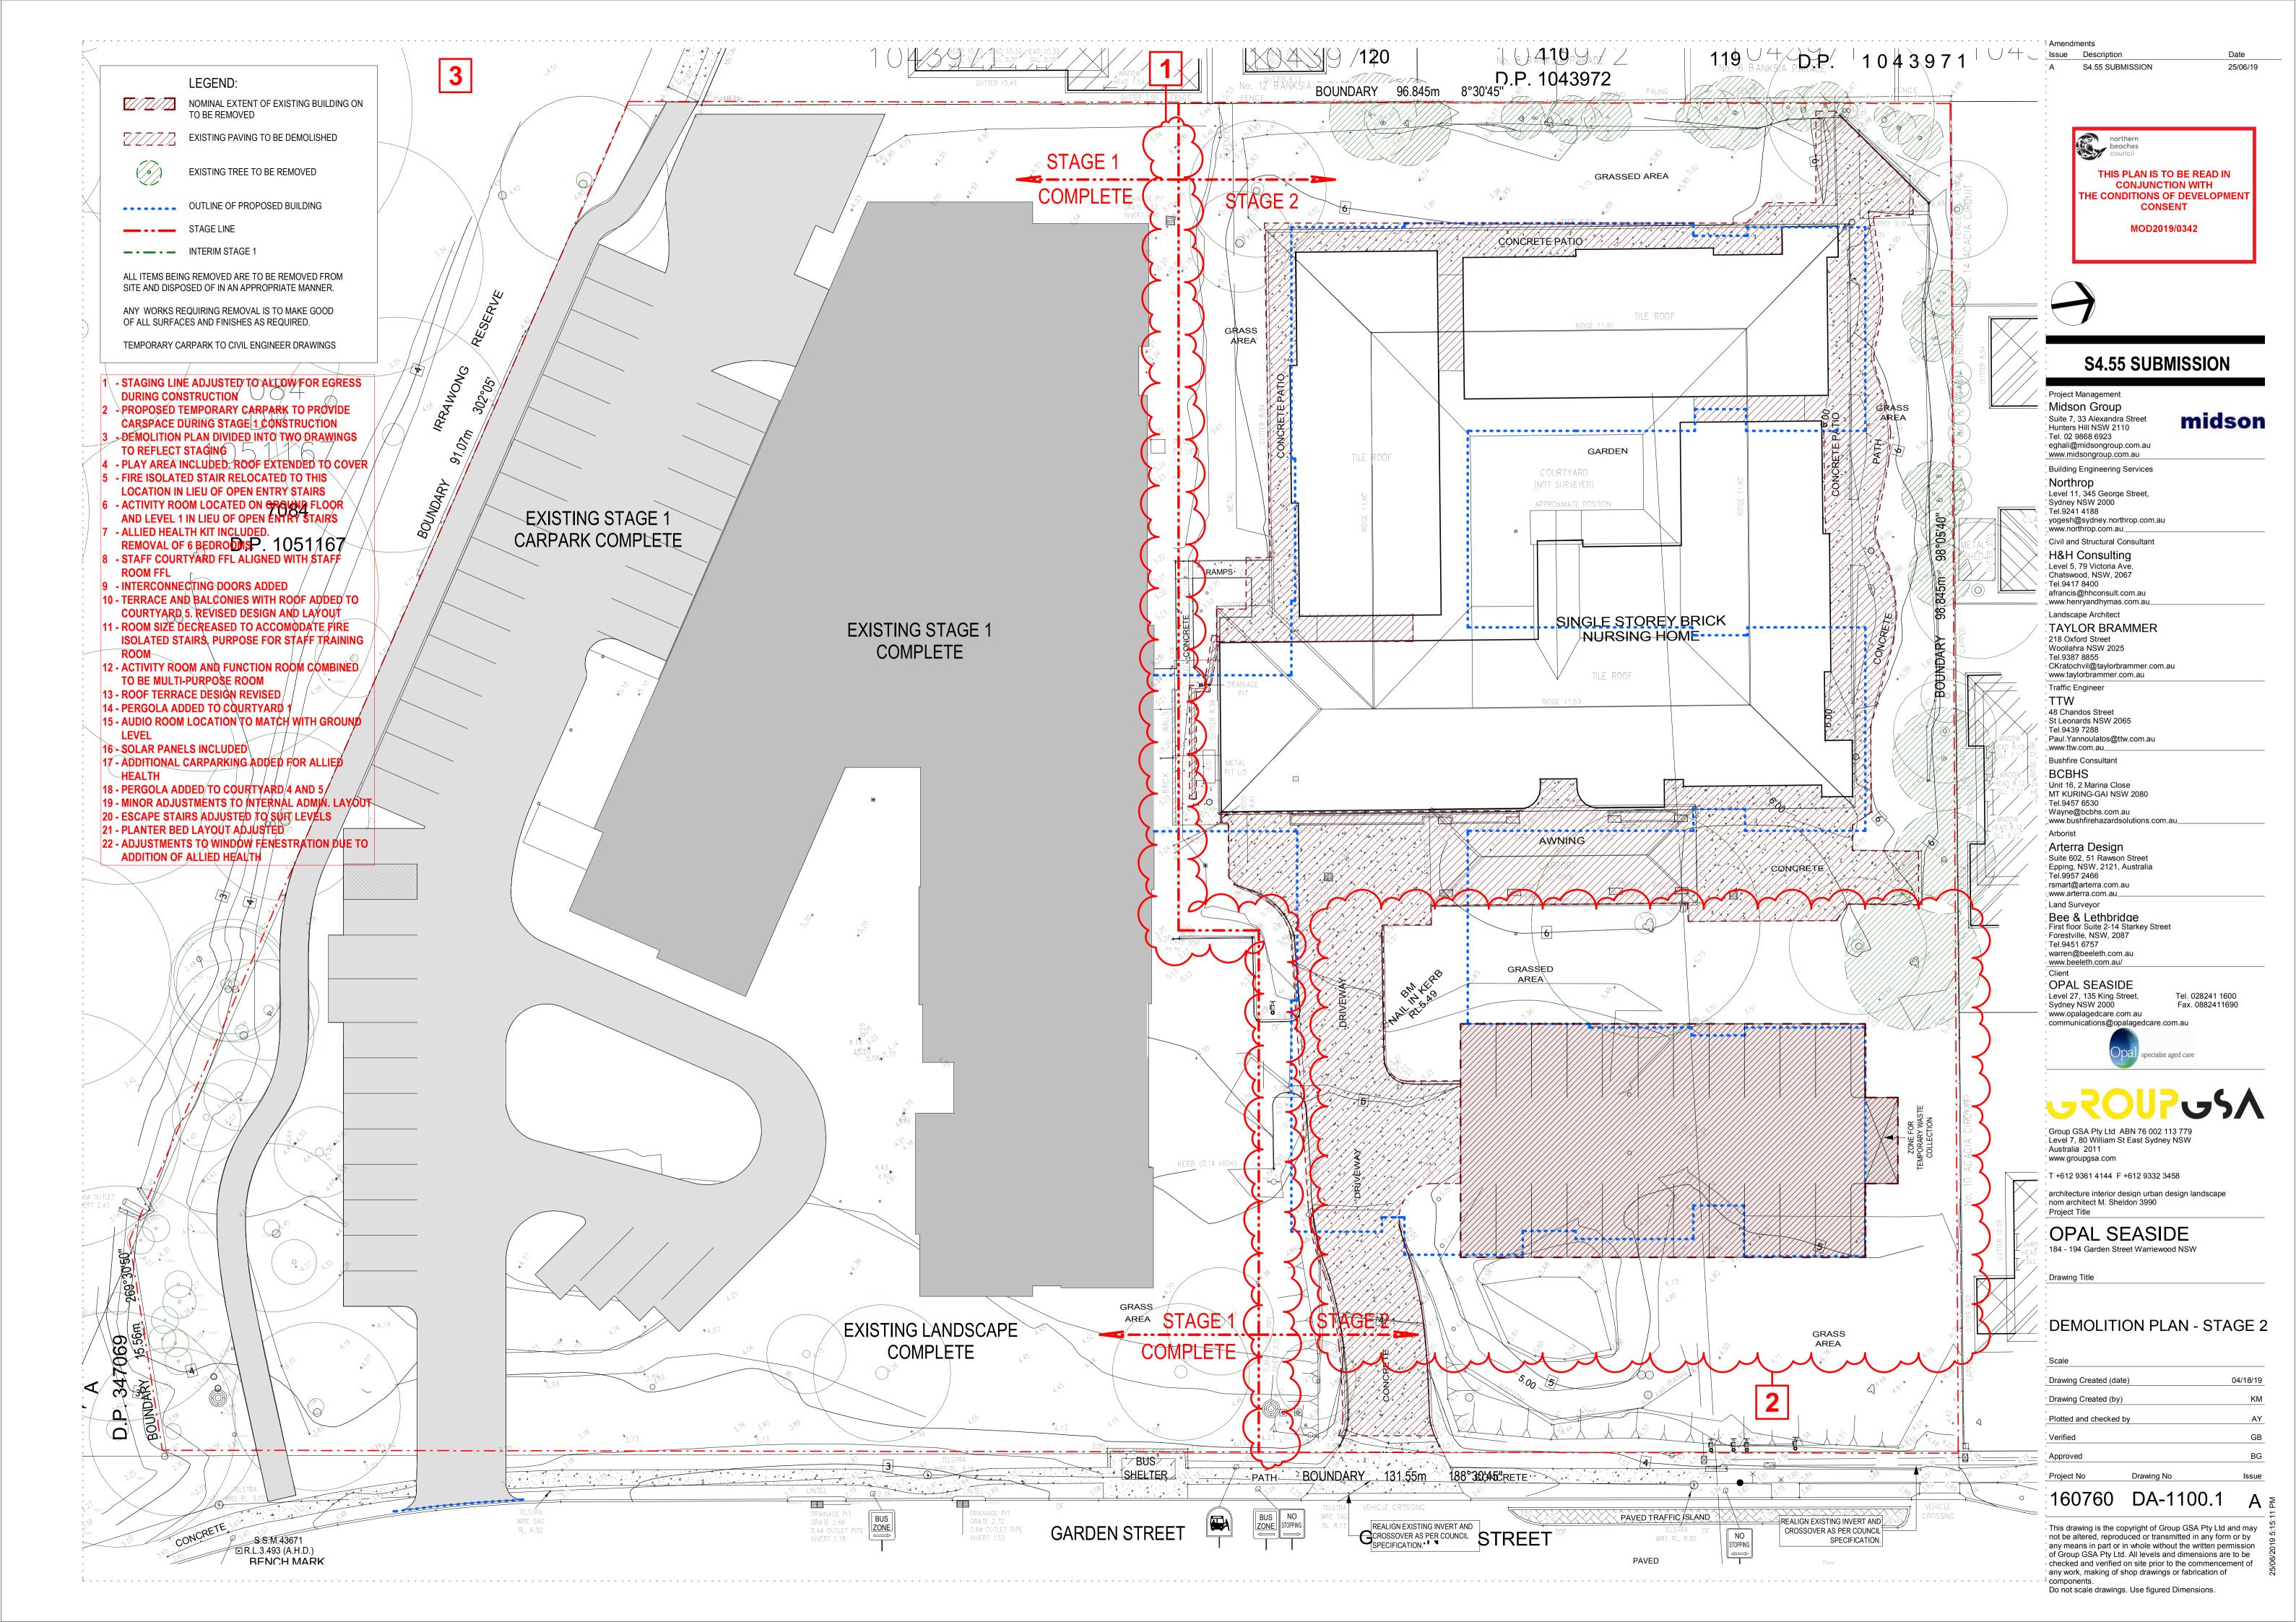





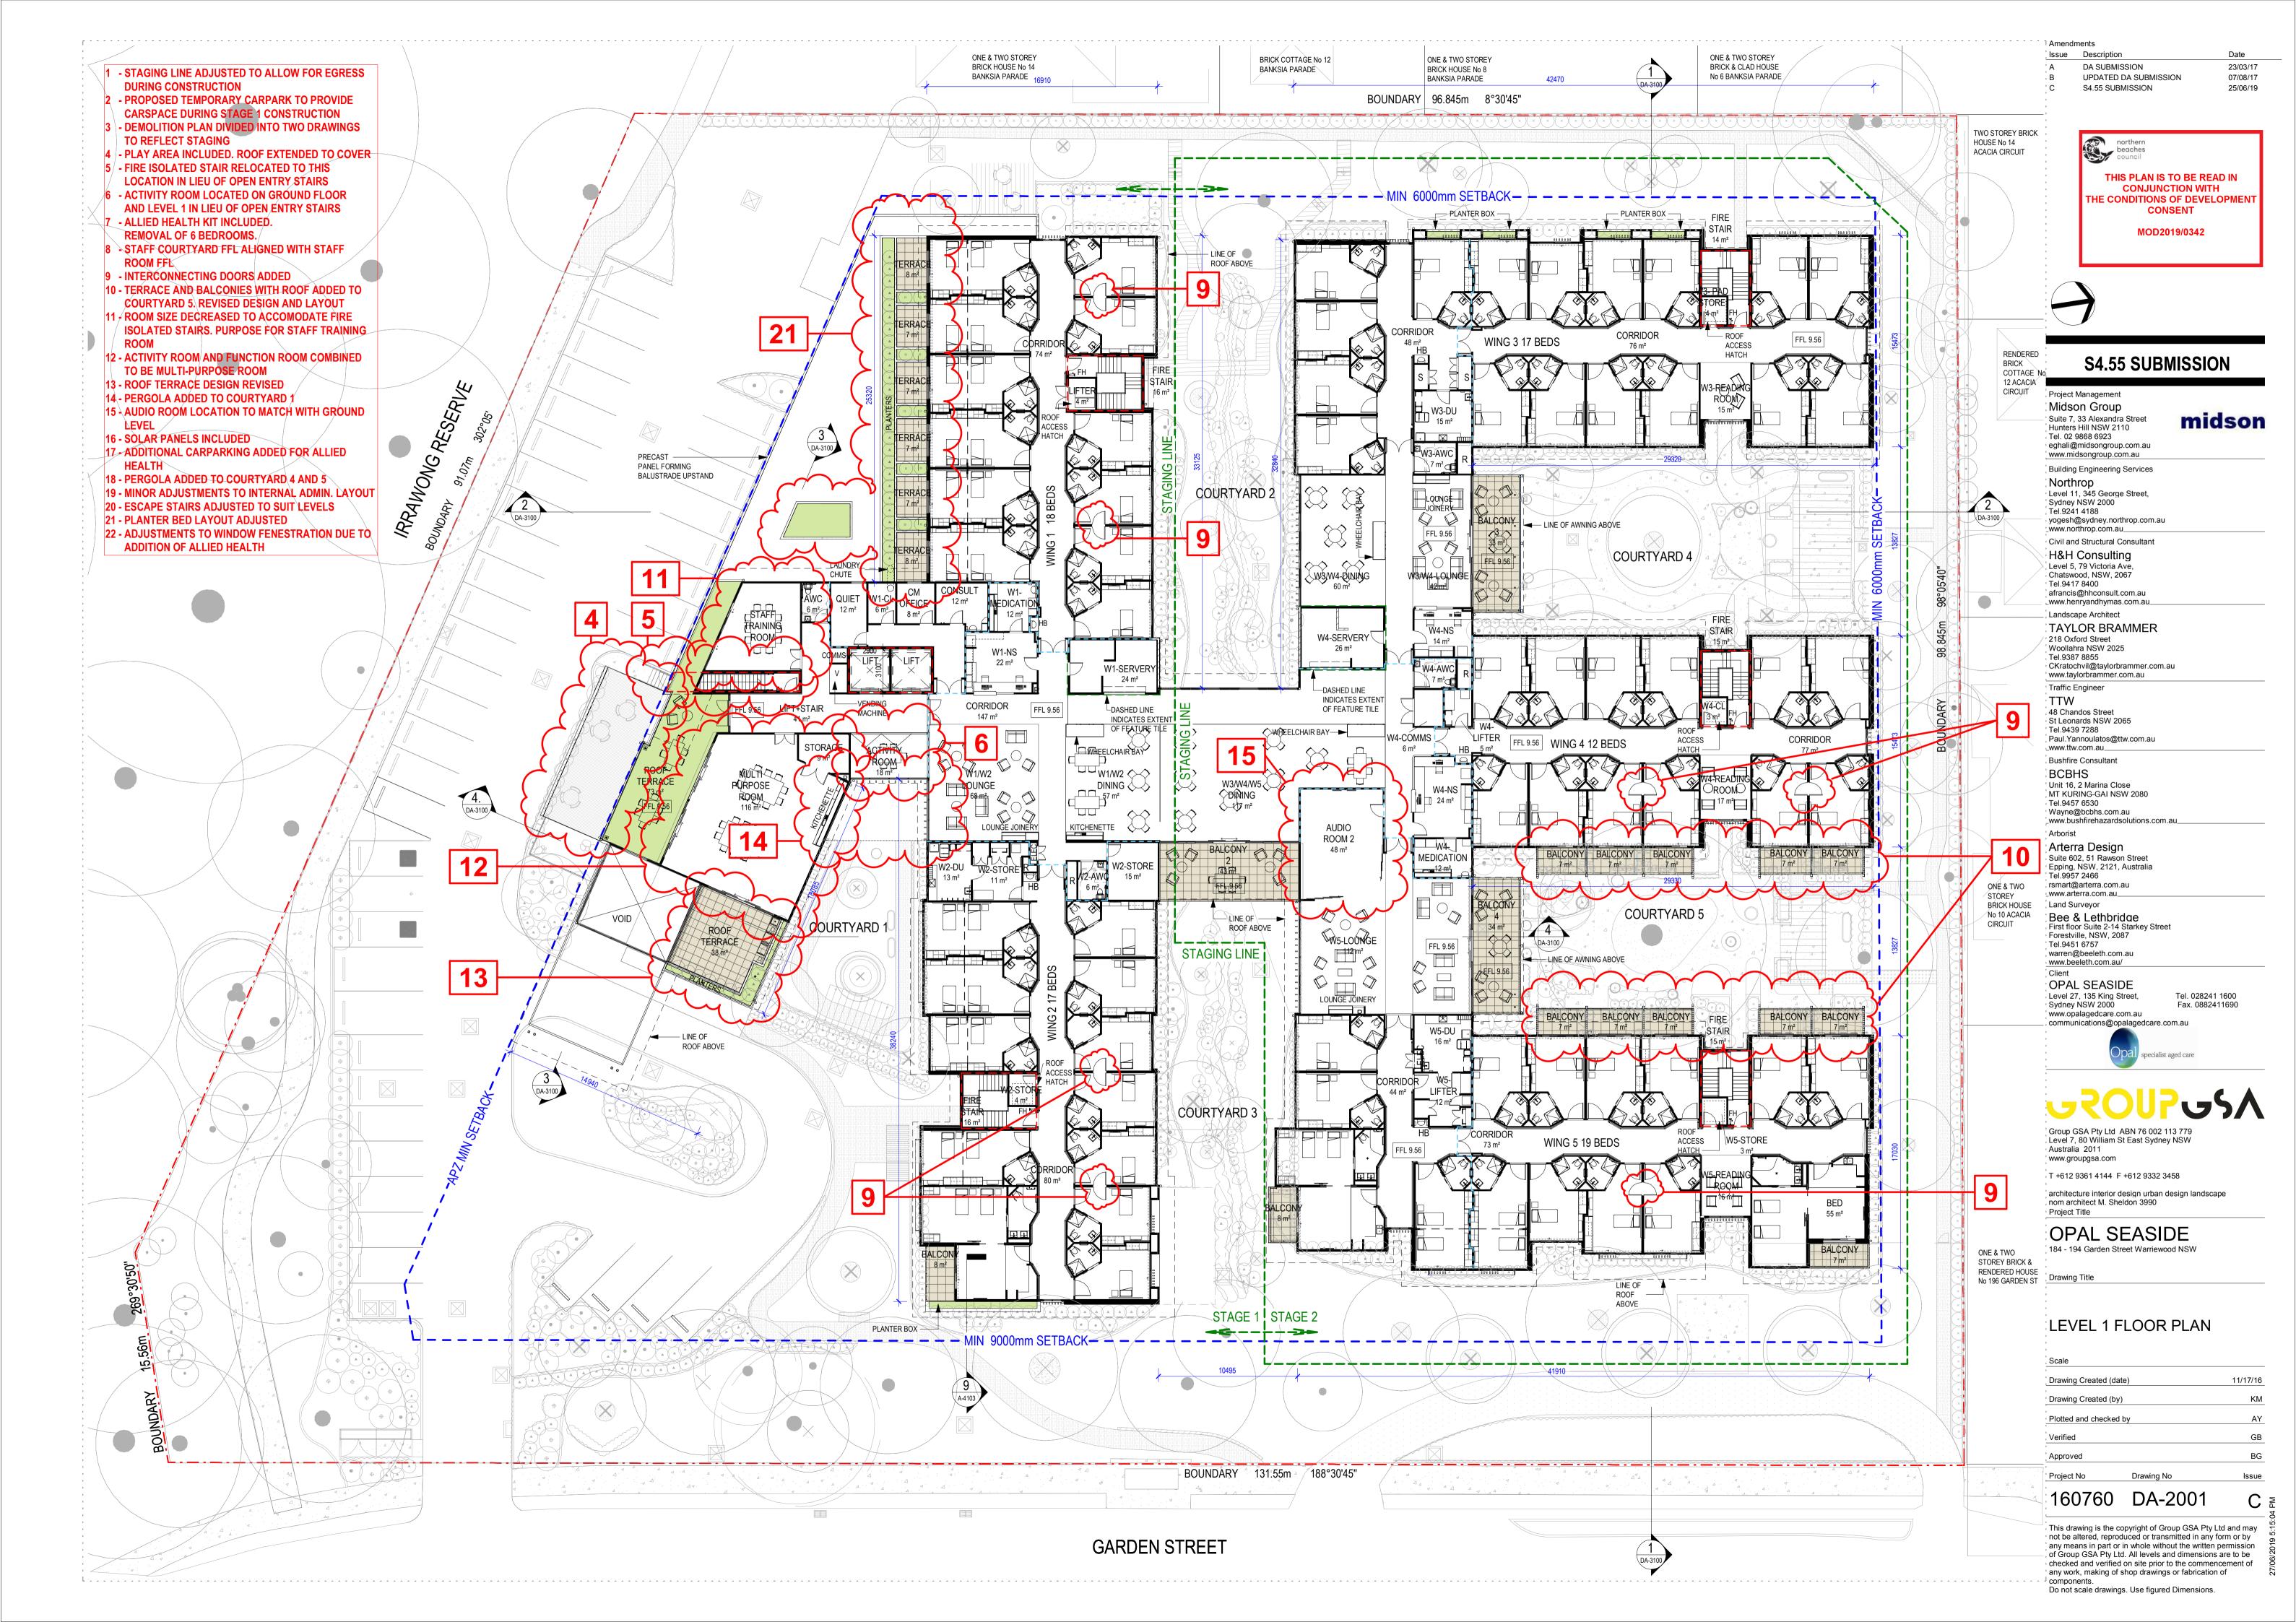

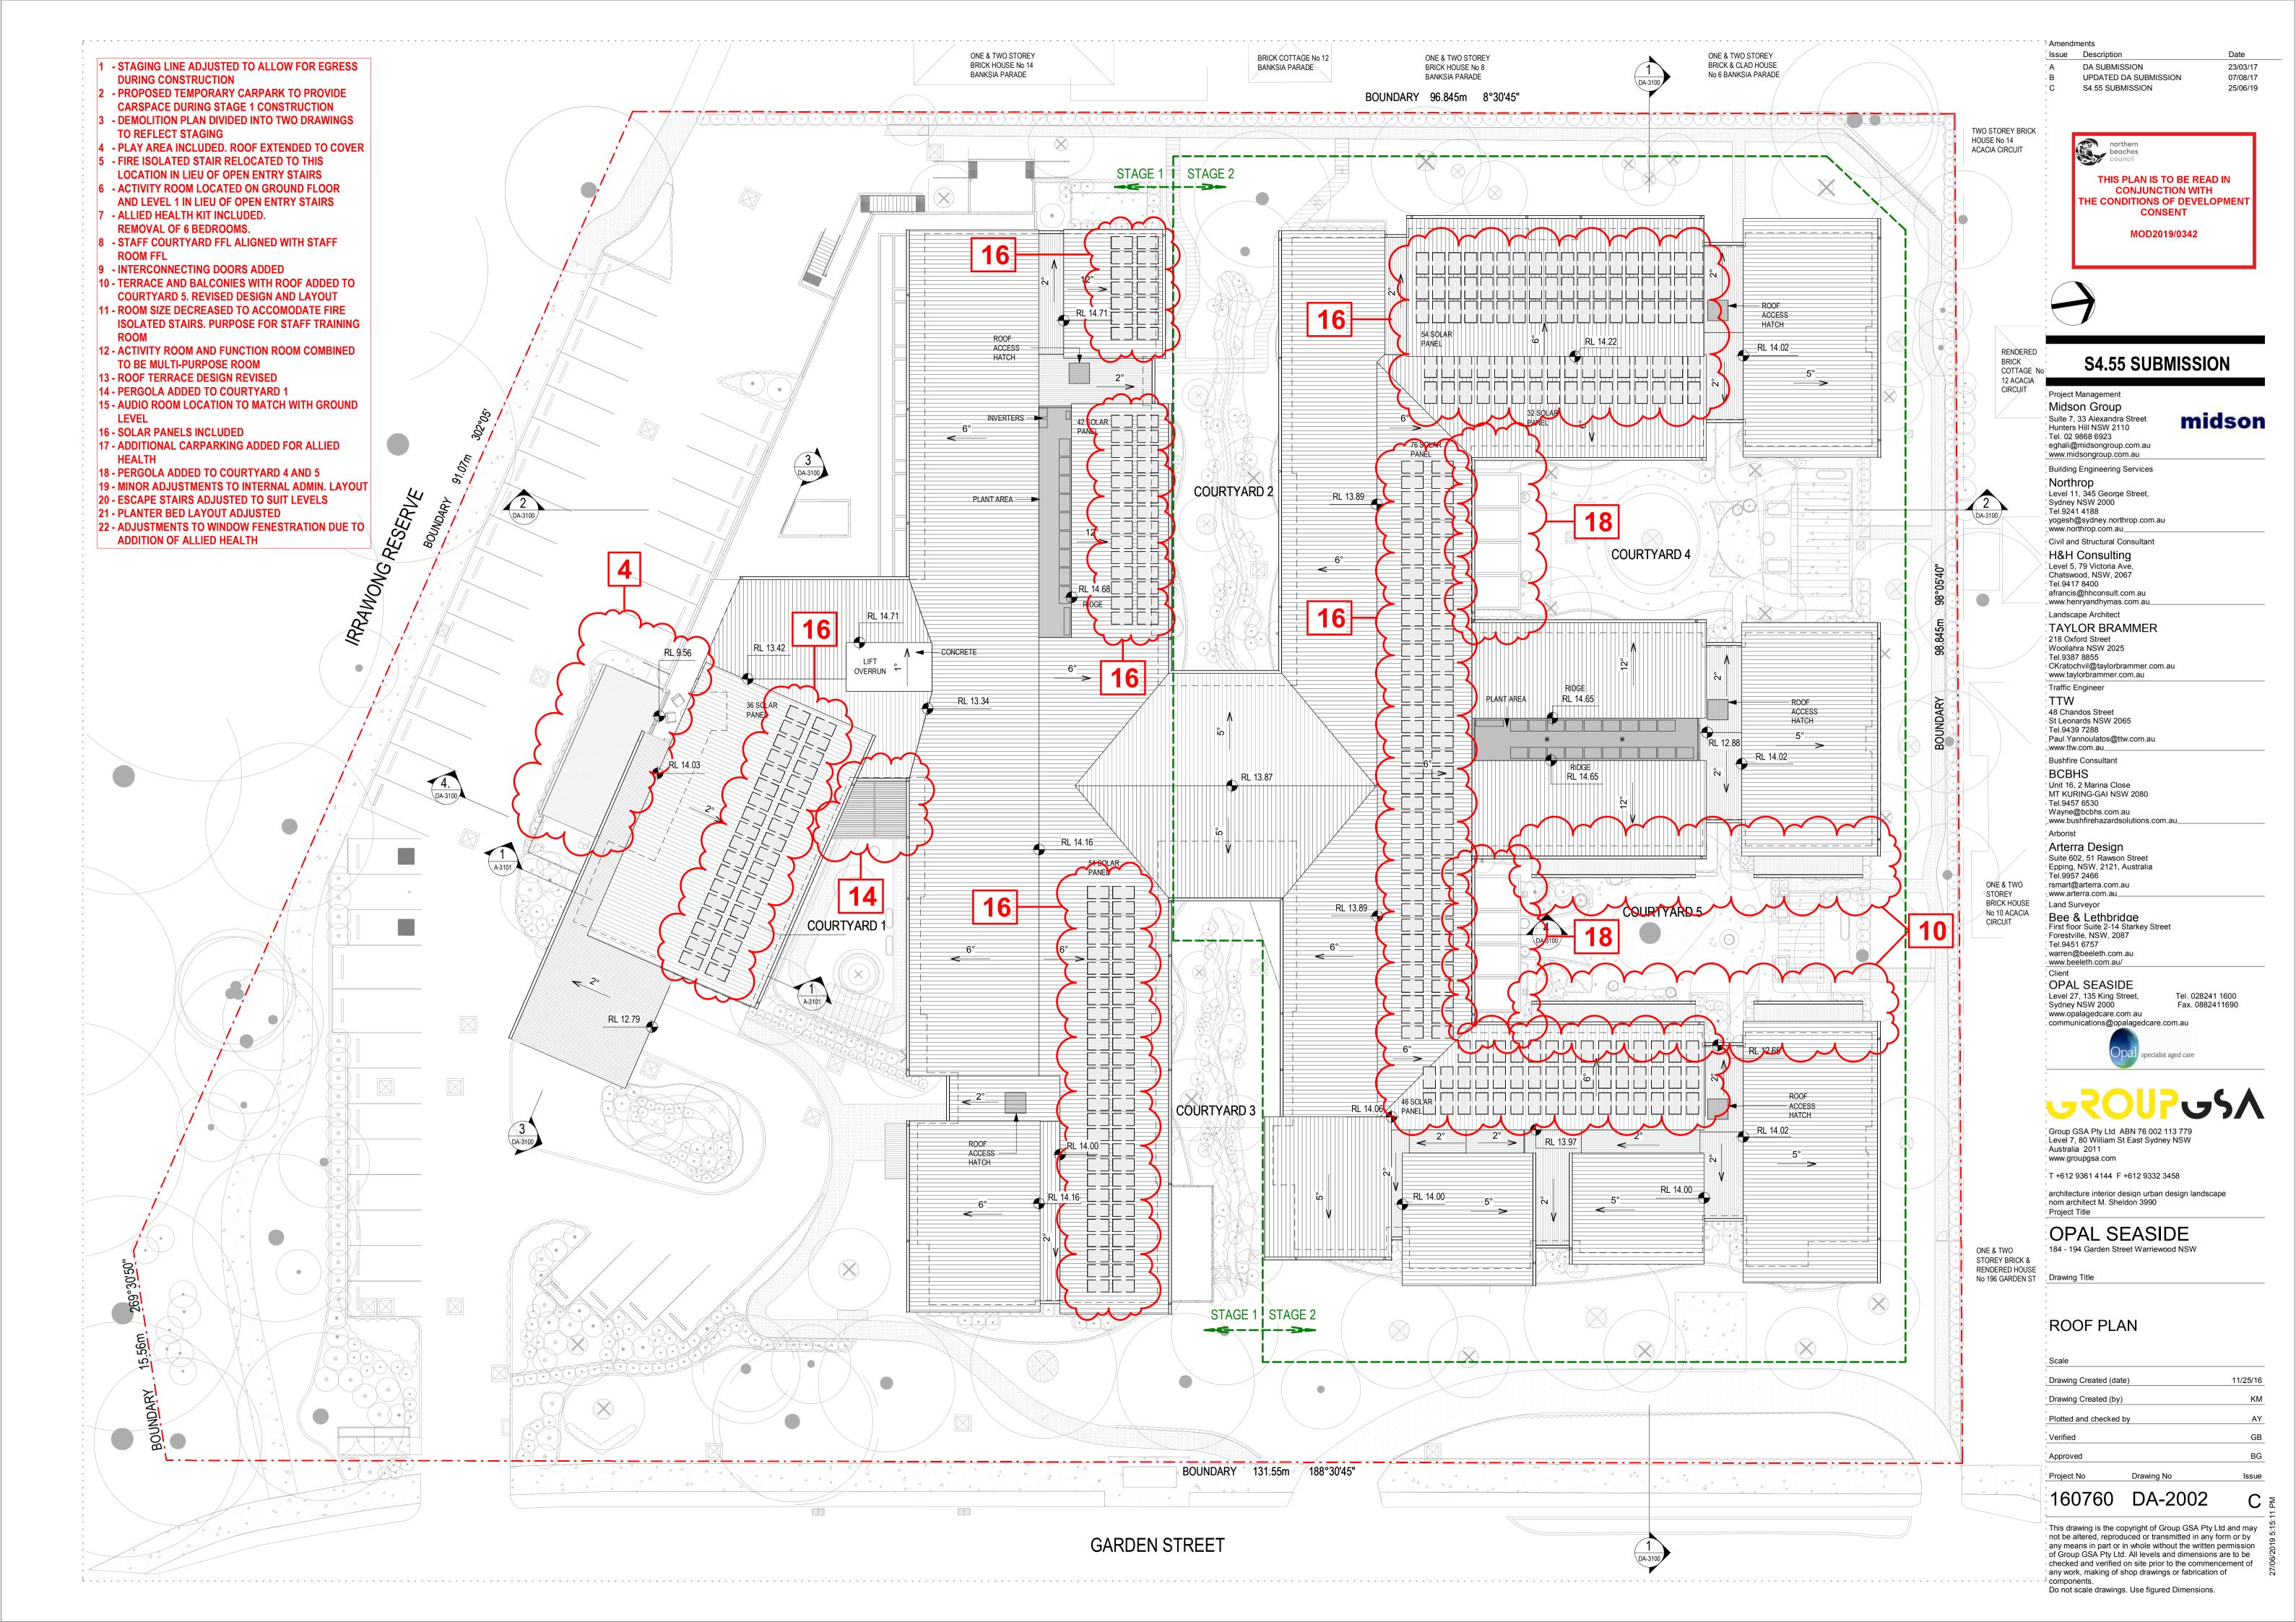

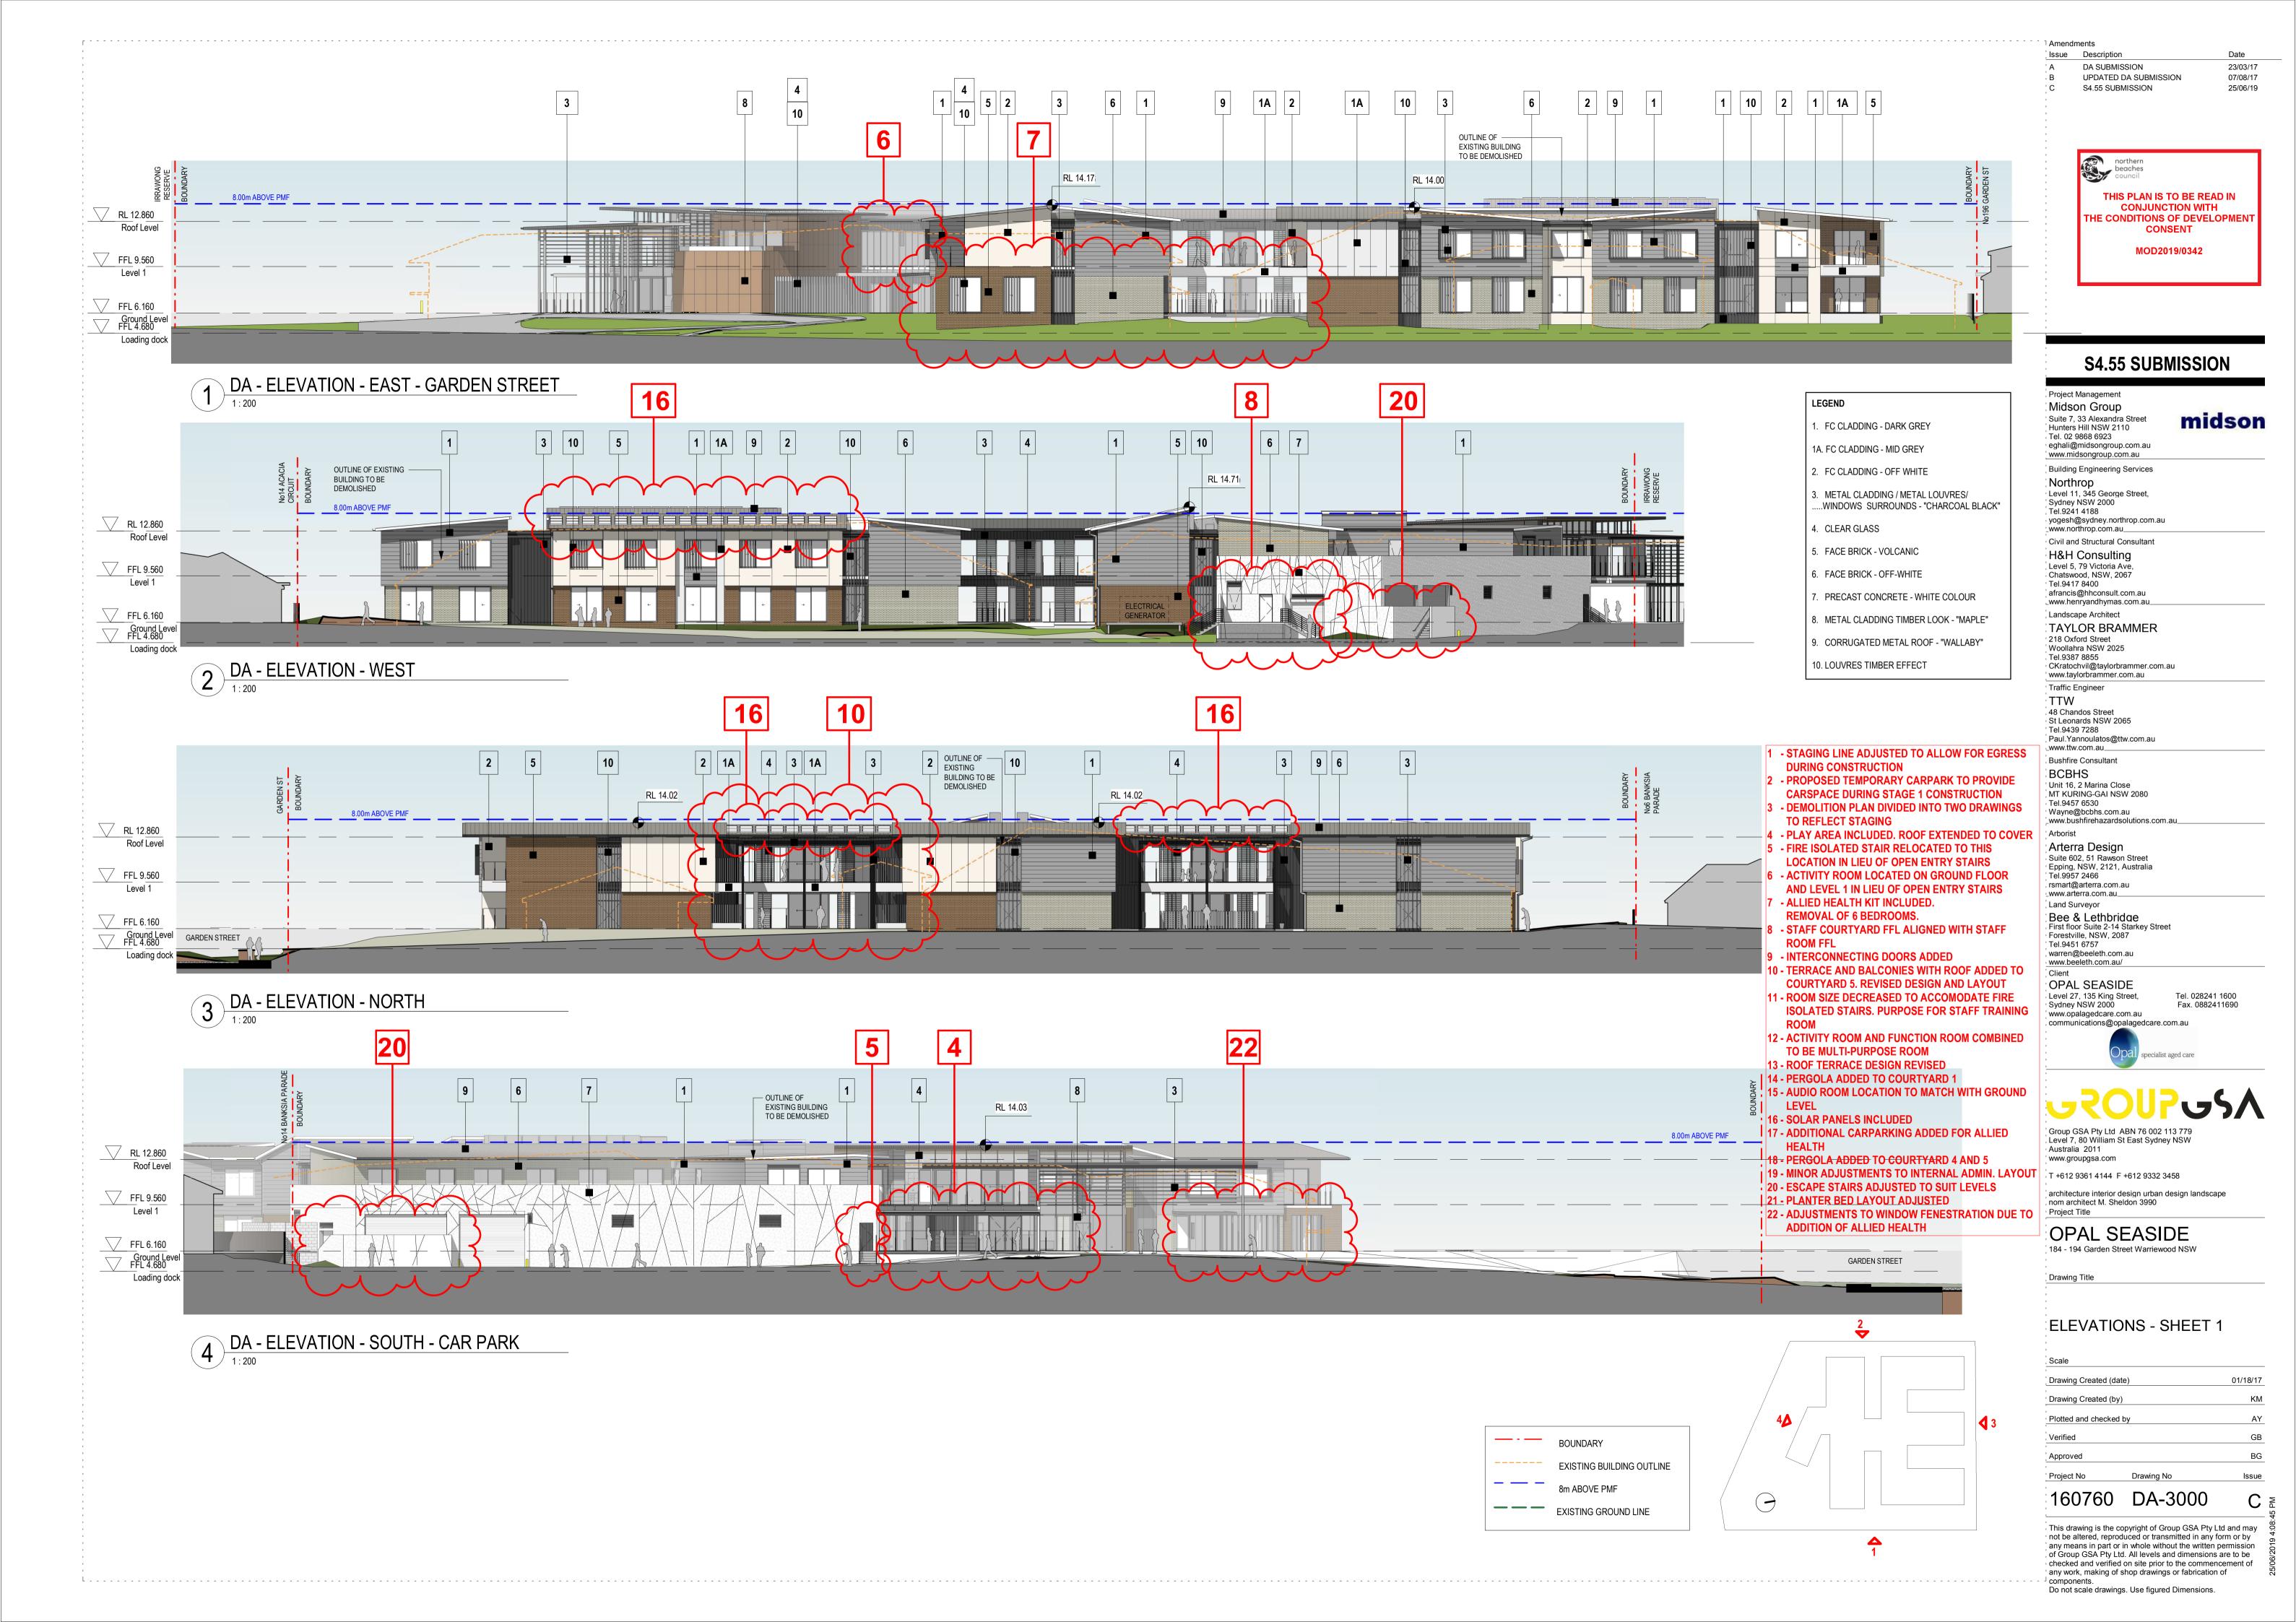

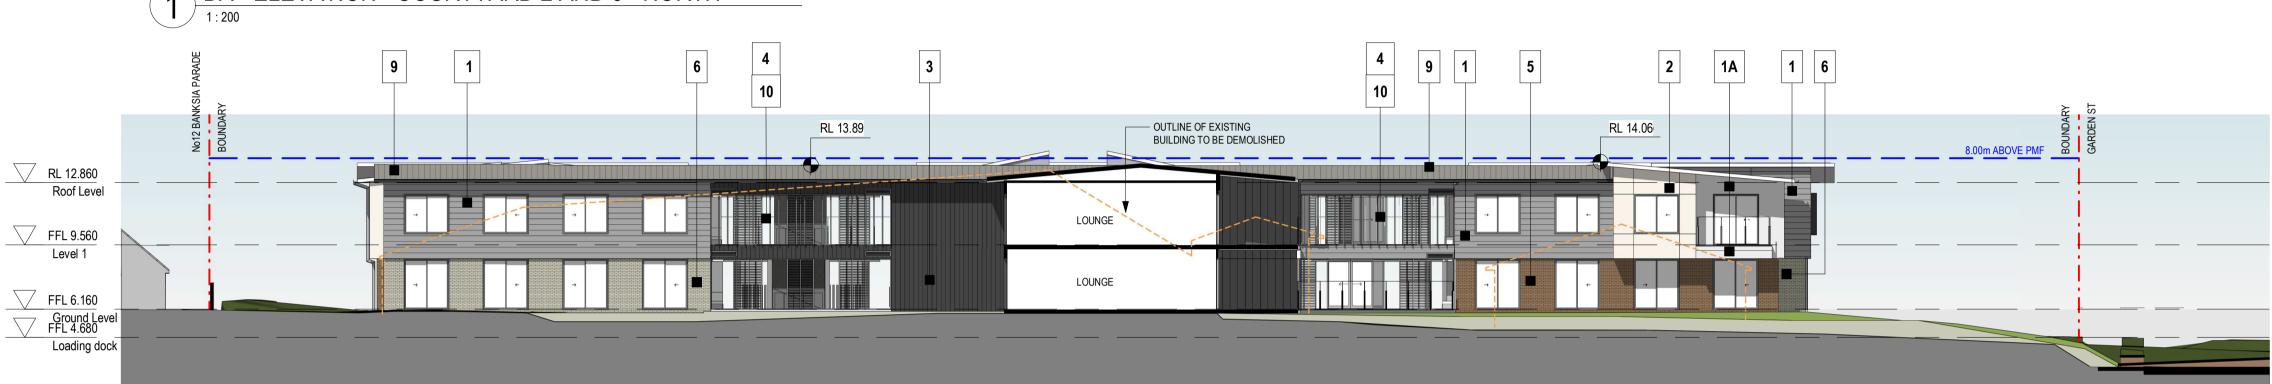

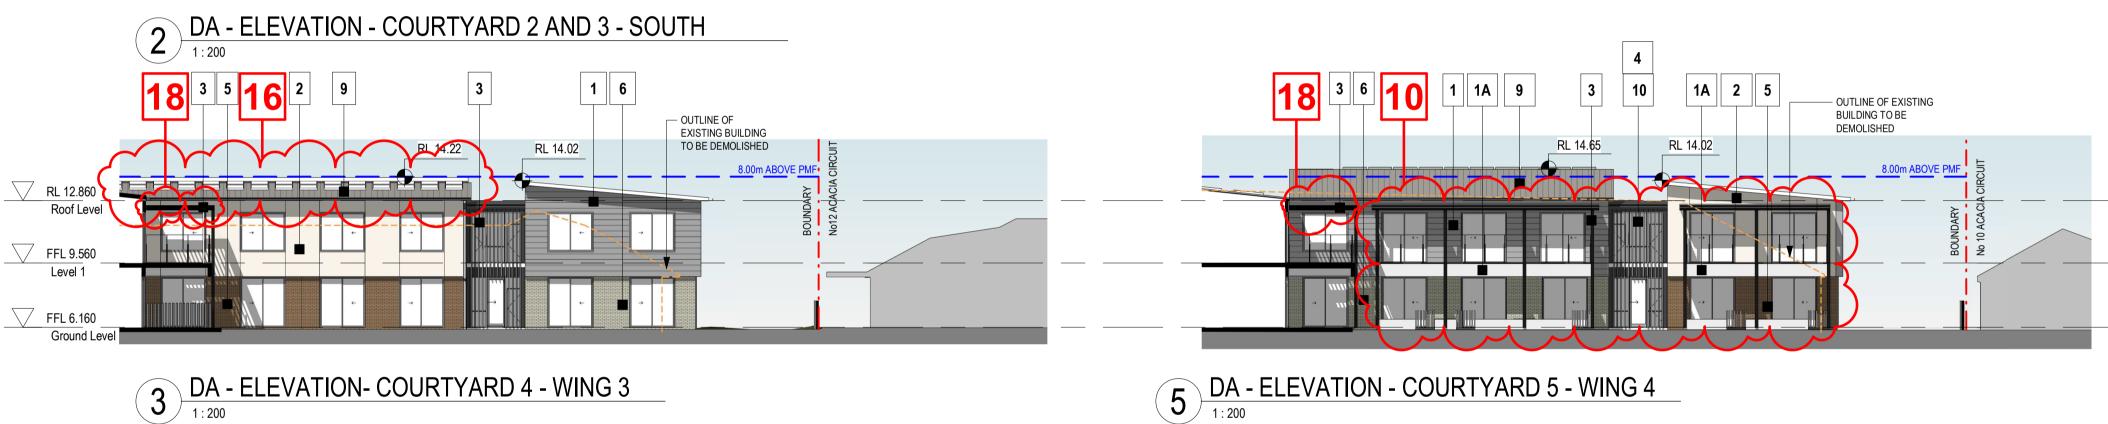





DA - ELEVATION - COURTYARD 4 - WING 4

6 DA - ELEVATION - COURTYARD 5 - WING 5



DA - ELEVATION - WING 2 - COURTYARD 1

1. FC CLADDING - DARK GREY

1A. FC CLADDING - MID GREY

2. FC CLADDING - OFF WHITE

BOUNDARY

EXISTING GROUND LINE

- STAGING LINE ADJUSTED TO ALLOW FOR EGRESS

- PROPOSED TEMPORARY CARPARK TO PROVIDE

- DEMOLITION PLAN DIVIDED INTO TWO DRAWINGS

4 - PLAY AREA INCLUDED. ROOF EXTENDED TO COVER

5 - FIRE ISOLATED STAIR RELOCATED TO THIS

**LOCATION IN LIEU OF OPEN ENTRY STAIRS** 

- ACTIVITY ROOM LOCATED ON GROUND FLOOR

AND LEVEL 1 IN LIEU OF OPEN ENTRY STAIRS

- STAFF COURTYARD FFL ALIGNED WITH STAFF

10 - TERRACE AND BALCONIES WITH ROOF ADDED TO COURTYARD 5. REVISED DESIGN AND LAYOUT

11 - ROOM SIZE DECREASED TO ACCOMODATE FIRE **ISOLATED STAIRS. PURPOSE FOR STAFF TRAINING** 

12 - ACTIVITY ROOM AND FUNCTION ROOM COMBINED

15 - AUDIO ROOM LOCATION TO MATCH WITH GROUND

17 - ADDITIONAL CARPARKING ADDED FOR ALLIED

19 - MINOR ADJUSTMENTS TO INTERNAL ADMIN. LAYOUT

22 - ADJUSTMENTS TO WINDOW FENESTRATION DUE TO

18 - PERGOLA ADDED TO COURTYARD 4 AND 5

20 - ESCAPE STAIRS ADJUSTED TO SUIT LEVELS

**CARSPACE DURING STAGE 1 CONSTRUCTION** 

**DURING CONSTRUCTION** 

TO REFLECT STAGING

- ALLIED HEALTH KIT INCLUDED. REMOVAL OF 6 BEDROOMS.

9 - INTERCONNECTING DOORS ADDED

TO BE MULTI-PURPOSE ROOM 13 - ROOF TERRACE DESIGN REVISED

14 - PERGOLA ADDED TO COURTYARD 1

21 - PLANTER BED LAYOUT ADJUSTED

ADDITION OF ALLIED HEALTH

**16 - SOLAR PANELS INCLUDED** 

**ROOM FFL** 

EXISTING BUILDING OUTLINE

10. LOUVRES TIMBER EFFECT

TTW 48 Chandos Street

\_www.ttw.com.au\_\_

Arterra Design

Land Surveyor

warren@beeleth.com.au

OPAL SEASIDE Level 27, 135 King Street,

Sydney NSW 2000 www.opalagedcare.com.au



Group GSA Pty Ltd ABN 76 002 113 779 Level 7, 80 William St East Sydney NSW

Australia 2011

www.groupgsa.com

T +612 9361 4144 F +612 9332 3458

architecture interior design urban design landscape nom architect M. Sheldon 3990 Project Title

OPAL SEASIDE 184 - 194 Garden Street Warriewood NSW

Drawing Title

ELEVATIONS - SHEET 2

01/18/17 Drawing Created (date) KM Drawing Created (by) Plotted and checked by GB BG Approved

Drawing No DA-3001

This drawing is the copyright of Group GSA Pty Ltd and may not be altered, reproduced or transmitted in any form or by any means in part or in whole without the written permission of Group GSA Pty Ltd. All levels and dimensions are to be checked and verified on site prior to the commencement of any work, making of shop drawings or fabrication of

Issue

B

<sup>⊥</sup> components. Do not scale drawings. Use figured Dimensions.

 $\frac{4}{3}$ 

. METAL CLADDING / METAL LOUVRES/ ....WINDOWS SURROUNDS - "CHARCOAL BLACK"

4. CLEAR GLASS

5. FACE BRICK - VOLCANIC

6. FACE BRICK - OFF-WHITE

PRECAST CONCRETE - WHITE COLOUR

8. METAL CLADDING TIMBER LOOK - "MAPLE"

CORRUGATED METAL ROOF - "WALLABY"

TAYLOR BRAMMER 218 Oxford Street Woollahra NSW 2025 Tel.9387 8855

Landscape Architect

**Project Management** 

Midson Group

Hunters Hill NSW 2110 Tel. 02 9868 6923

Suite 7, 33 Alexandra Street

eghali@midsongroup.com.au

Building Engineering Services

Level 11, 345 George Street,

yogesh@sydney.northrop.com.au

Sydney NSW 2000

\_www.northrop.com.au\_\_ Civil and Structural Consultant

**H&H Consulting** 

Level 5, 79 Victoria Ave

Chatswood, NSW, 2067 Tel.9417 8400

afrancis@hhconsult.com.au

\_www.henryandhymas.com.au\_

Tel.9241 4188

www.midsongroup.com.au

Northrop

Issue Description

DA SUBMISSION

S4.55 SUBMISSION

THIS PLAN IS TO BE READ IN CONJUNCTION WITH

THE CONDITIONS OF DEVELOPMEN

CONSENT

MOD2019/0342

**S4.55 SUBMISSION** 

midson

23/03/17

25/06/19

CKratochvil@taylorbrammer.com.au www.taylorbrammer.com.au Traffic Engineer

St Leonards NSW 2065 Tel.9439 7288 Paul.Yannoulatos@ttw.com.au

Bushfire Consultant **BCBHS** Unit 16, 2 Marina Close MT KURING-GAI NSW 2080

Tel.9457 6530 Wayne@bcbhs.com.au www.bushfirehazardsolutions.com.a


Suite 602, 51 Rawson Street Epping, NSW, 2121, Australia Tel.9957 2466 rsmart@arterra.com.au \_www.arterra.com.au\_

Bee & Lethbridge First floor Suite 2-14 Starkey Street Forestville, NSW, 2087 Tel.9451 6757

www.beeleth.com.au/

Tel. 028241 1600 Fax. 0882411690 communications@opalagedcare.com.au



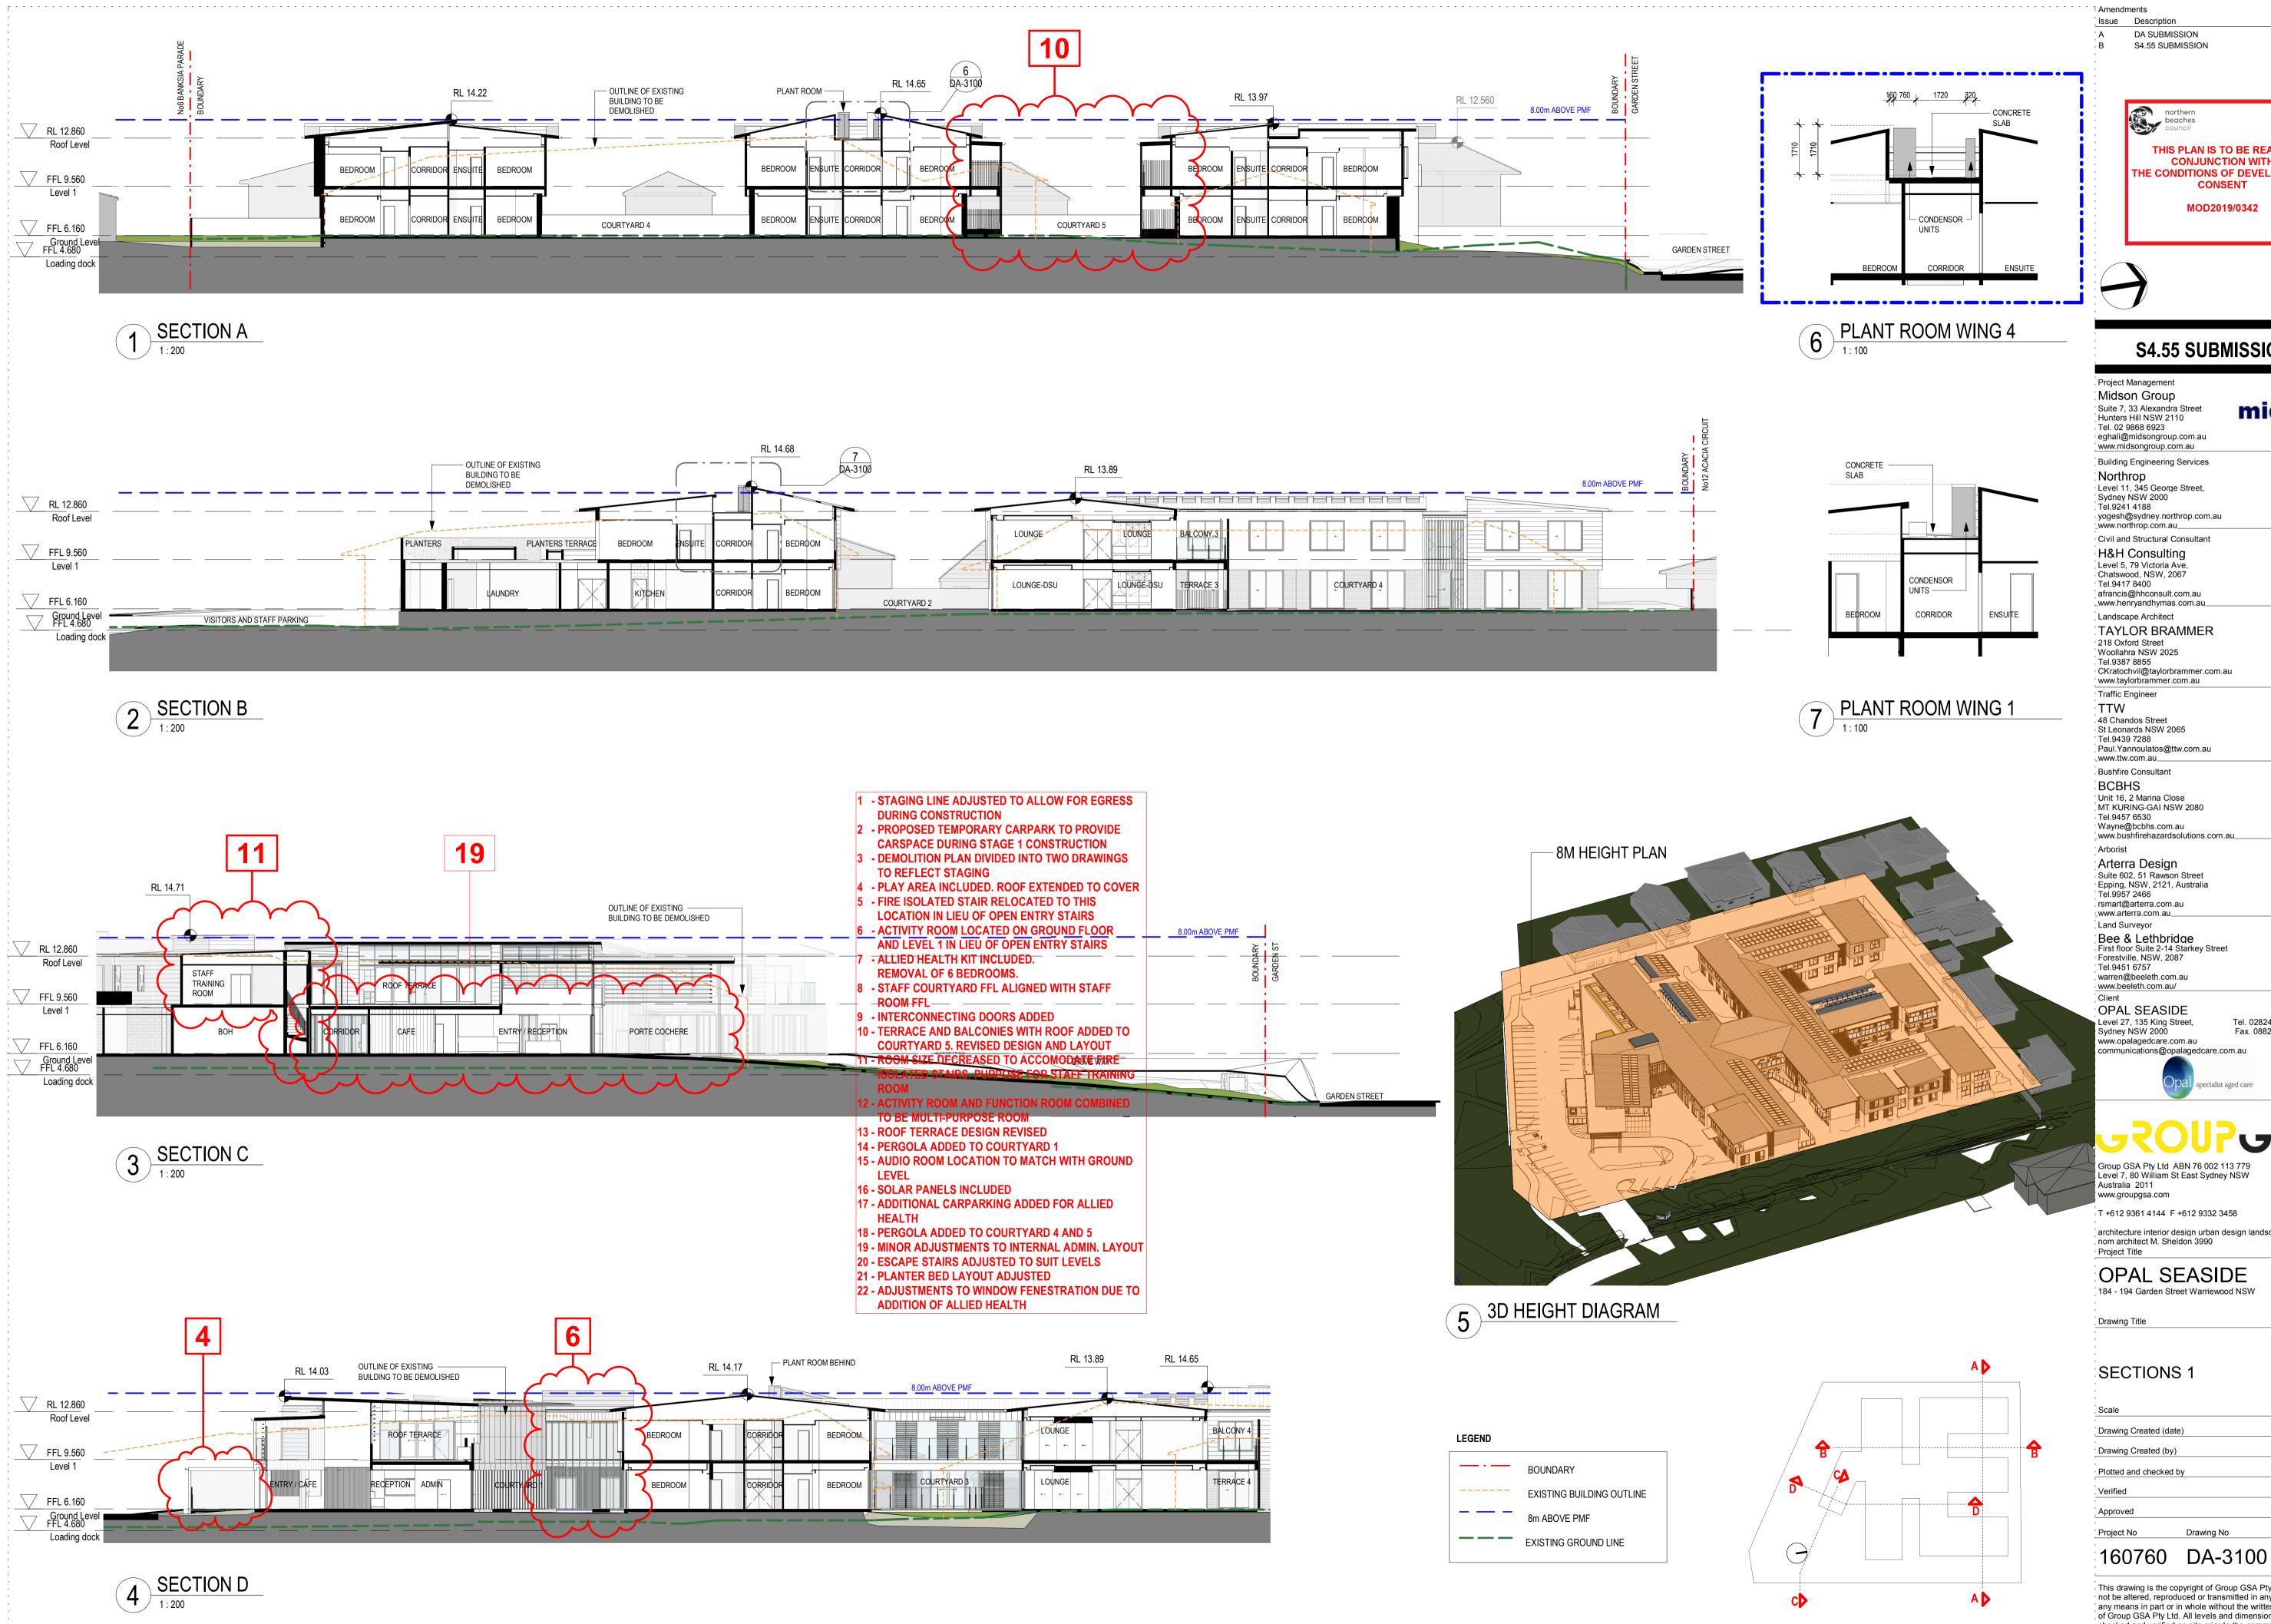

THIS PLAN IS TO BE READ IN **CONJUNCTION WITH** THE CONDITIONS OF DEVELOPMENT CONSENT MOD2019/0342

Date

23/03/17

25/06/19

### **S4.55 SUBMISSION**

Midson Group midson Suite 7, 33 Alexandra Street Hunters Hill NSW 2110 eghali@midsongroup.com.au

Building Engineering Services Northrop Level 11, 345 George Street, Sydney NSW 2000 Tel.9241 4188 yogesh@sydney.northrop.com.au

\_www.northrop.com.au\_\_ Civil and Structural Consultant H&H Consulting

Level 5, 79 Victoria Ave, Chatswood, NSW, 2067 Tel.9417 8400 afrancis@hhconsult.com.au \_www.henryandhymas.com.au\_

Landscape Architect TAYLOR BRAMMER 218 Oxford Street Woollahra NSW 2025 Tel.9387 8855

CKratochvil@taylorbrammer.com.au www.taylorbrammer.com.au

48 Chandos Street St Leonards NSW 2065 Tel.9439 7288

Bushfire Consultant Unit 16, 2 Marina Close MT KURING-GAI NSW 2080

\_www.bushfirehazardsolutions.com.a Arterra Design Suite 602, 51 Rawson Street

Tel.9957 2466 rsmart@arterra.com.au \_www.arterra.com.au\_ Land Surveyor Bee & Lethbridge First floor Suite 2-14 Starkey Street

Tel.9451 6757 warren@beeleth.com.au www.beeleth.com.au/

OPAL SEASIDE Level 27, 135 King Street, Tel. 028241 1600 Fax. 0882411690

communications@opalagedcare.com.au specialist aged care

Group GSA Pty Ltd ABN 76 002 113 779 Level 7, 80 William St East Sydney NSW

www.groupgsa.com T +612 9361 4144 F +612 9332 3458

architecture interior design urban design landscape

nom architect M. Sheldon 3990 Project Title

OPAL SEASIDE 184 - 194 Garden Street Warriewood NSW


Drawing Title

### SECTIONS 1


Drawing Created (date)		01/18/17	
Drawing Created	(by)	KM	
Plotted and chec	ked by	AY	
Verified		GB	
Approved		BG	
Project No	Drawing No	Issue	

This drawing is the copyright of Group GSA Pty Ltd and may not be altered, reproduced or transmitted in any form or by any means in part or in whole without the written permission of Group GSA Pty Ltd. All levels and dimensions are to be checked and verified on site prior to the commencement of any work, making of shop drawings or fabrication of

<sup>⊥</sup> components. Do not scale drawings. Use figured Dimensions.

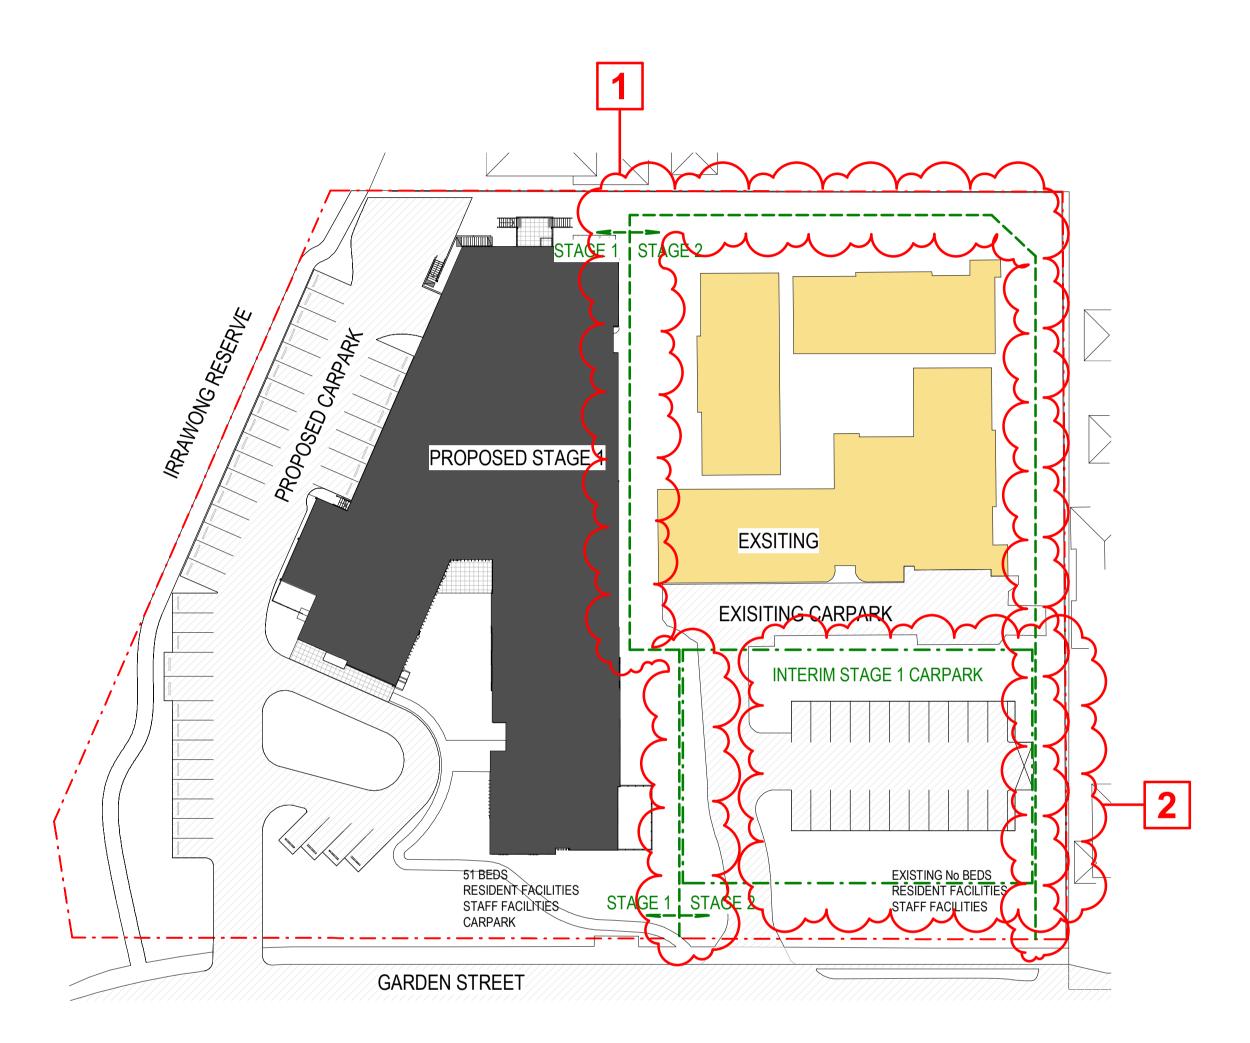

STAGE 1 DIAGRAM

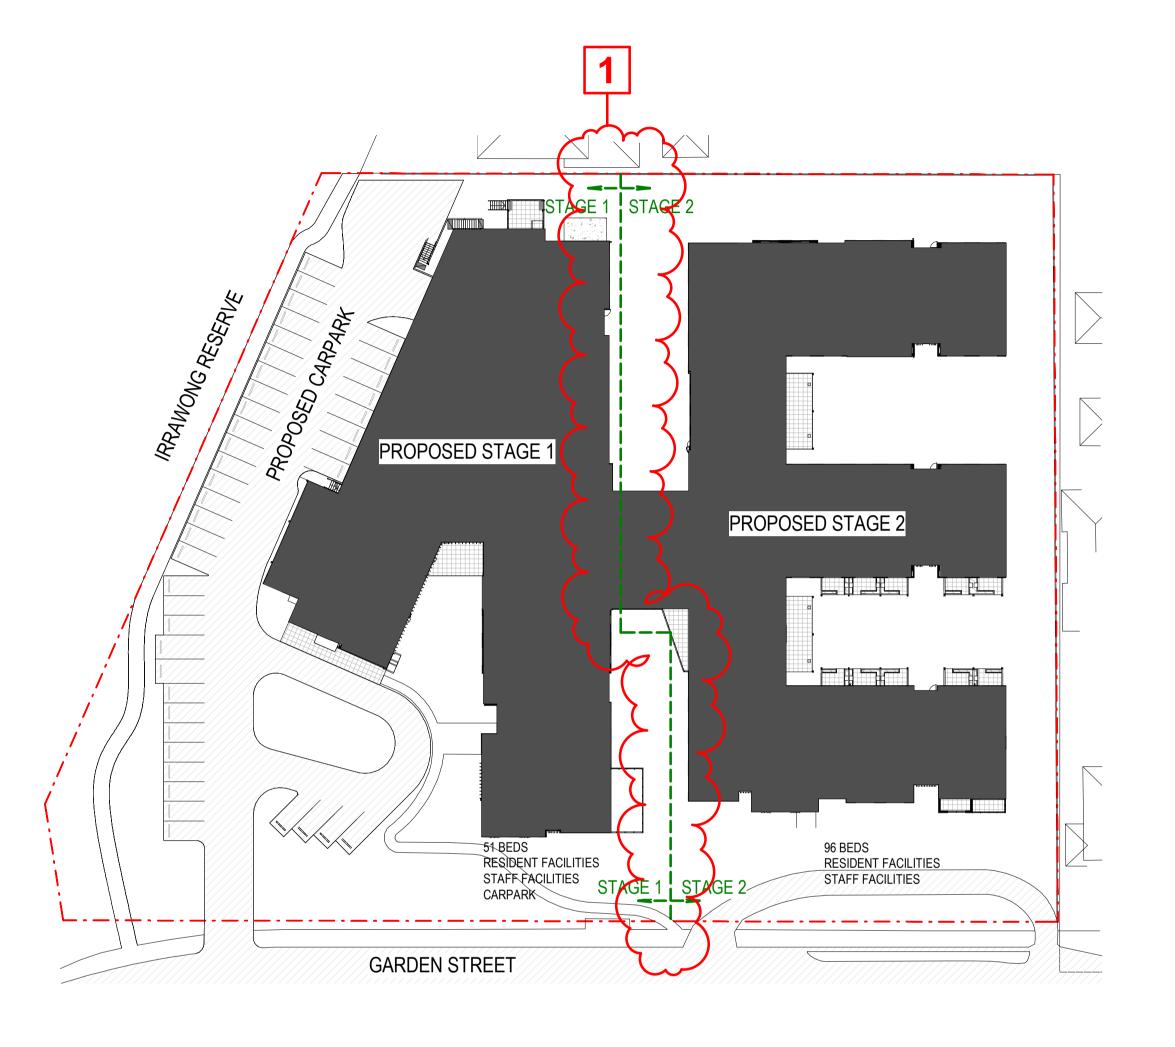

2 STAGE DIAGRAM 2

- 1 STAGING LINE ADJUSTED TO ALLOW FOR EGRESS **DURING CONSTRUCTION**
- 2 PROPOSED TEMPORARY CARPARK TO PROVIDE
- CARSPACE DURING STAGE 1 CONSTRUCTION
- DEMOLITION PLAN DIVIDED INTO TWO DRAWINGS TO REFLECT STAGING
- 4 PLAY AREA INCLUDED. ROOF EXTENDED TO COVER
- 5 FIRE ISOLATED STAIR RELOCATED TO THIS LOCATION IN LIEU OF OPEN ENTRY STAIRS
- 6 ACTIVITY ROOM LOCATED ON GROUND FLOOR
- AND LEVEL 1 IN LIEU OF OPEN ENTRY STAIRS
- ALLIED HEALTH KIT INCLUDED. REMOVAL OF 6 BEDROOMS.
- 8 STAFF COURTYARD FFL ALIGNED WITH STAFF
- **ROOM FFL** 9 - INTERCONNECTING DOORS ADDED
- 10 TERRACE AND BALCONIES WITH ROOF ADDED TO **COURTYARD 5. REVISED DESIGN AND LAYOUT**
- 11 ROOM SIZE DECREASED TO ACCOMODATE FIRE **ISOLATED STAIRS. PURPOSE FOR STAFF TRAINING**
- 12 ACTIVITY ROOM AND FUNCTION ROOM COMBINED
- TO BE MULTI-PURPOSE ROOM
- 13 ROOF TERRACE DESIGN REVISED
- 14 PERGOLA ADDED TO COURTYARD 1 15 - AUDIO ROOM LOCATION TO MATCH WITH GROUND
- LEVEL 16 - SOLAR PANELS INCLUDED
- 17 ADDITIONAL CARPARKING ADDED FOR ALLIED
- HEALTH
- 18 PERGOLA ADDED TO COURTYARD 4 AND 5
- 19 MINOR ADJUSTMENTS TO INTERNAL ADMIN. LAYOUT 20 - ESCAPE STAIRS ADJUSTED TO SUIT LEVELS
- 21 PLANTER BED LAYOUT ADJUSTED
- 22 ADJUSTMENTS TO WINDOW FENESTRATION DUE TO ADDITION OF ALLIED HEALTH

Issue Description ' A DA SUBMISSION B S4.55 SUBMISSION



THIS PLAN IS TO BE READ IN CONJUNCTION WITH THE CONDITIONS OF DEVELOPMENT CONSENT

MOD2019/0342

midson

23/03/17

25/06/19



#### **S4.55 SUBMISSION**

Project Management Midson Group

Suite 7, 33 Alexandra Street Hunters Hill NSW 2110 Tel. 02 9868 6923 eghali@midsongroup.com.au

www.midsongroup.com.au Building Engineering Services

Northrop Level 11, 345 George Street, Sydney NSW 2000 Tel.9241 4188

yogesh@sydney.northrop.com.au www.northrop.com.au\_\_ Civil and Structural Consultant

H&H Consulting Level 5, 79 Victoria Ave, Chatswood, NSW, 2067 Tel.9417 8400 afrancis@hhconsult.com.au \_www.henryandhymas.com.au\_

Landscape Architect TAYLOR BRAMMER 218 Oxford Street Woollahra NSW 2025

Tel.9387 8855 CKratochvil@taylorbrammer.com.au www.taylorbrammer.com.au Traffic Engineer TTW

48 Chandos Street St Leonards NSW 2065 Tel.9439 7288 Paul.Yannoulatos@ttw.com.au

\_www.ttw.com.au\_\_

Bushfire Consultant BCBHS Unit 16, 2 Marina Close MT KURING-GAI NSW 2080 Tel.9457 6530

Wayne@bcbhs.com.au www.bushfirehazardsolutions.com.a ' Arborist

: Arterra Design Suite 602, 51 Rawson Street Epping, NSW, 2121, Australia Tel.9957 2466 rsmart@arterra.com.au \_www.arterra.com.au\_\_

Land Surveyor Bee & Lethbridge First floor Suite 2-14 Starkey Street Forestville, NSW, 2087

Tel.9451 6757 warren@beeleth.com.au www.beeleth.com.au/

OPAL SEASIDE Level 27, 135 King Street,

Tel. 028241 1600 Sydney NSW 2000 Fax. 0882411690 www.opalagedcare.com.au communications@opalagedcare.com.au





Group GSA Pty Ltd ABN 76 002 113 779 Level 7, 80 William St East Sydney NSW Australia 2011 www.groupgsa.com

T +612 9361 4144 F +612 9332 3458

architecture interior design urban design landscape nom architect M. Sheldon 3990 Project Title

OPAL SEASIDE 184 - 194 Garden Street Warriewood NSW

Drawing Title

STAGING DIAGRAM

02/23/17 Drawing Created (date) KM Drawing Created (by) Plotted and checked by Verified Approved Drawing No

160760 DA-4001

B≥

This drawing is the copyright of Group GSA Pty Ltd and may not be altered, reproduced or transmitted in any form or by any means in part or in whole without the written permission of Group GSA Pty Ltd. All levels and dimensions are to be checked and verified on site prior to the commencement of any work, making of shop drawings or fabrication of

components. Do not scale drawings. Use figured Dimensions.

## OPAL SEASIDE

## DEVELOPMENT APPLICATION S4.55

PREPARED FOR: OPAL AGED CARE

PREPARED BY:
TAYLOR BRAMMER LANDSCAPE ARCHITECTS PTY LTD

### **DRAWING LIST**

DRAWING NO.	DRAWING TITLE	SCALE
LA00	COVER SHEET, PLANTING SCHEDULE, EXISTING TREE SCHEDULE	1:500 @ A1
LA02	LANDSCAPE PLAN- GROUND FLOOR	1:200 @ A1
LA03	PLANTING PLAN- GROUND FLOOR	1:200 @ A1
LA04	LANDSCAPE SECTIONS	1:200 @ A1
LA05	LANDSCAPE SECTIONS	1:200 @ A1
LA06	LANDSCAPE PLAN - LEVEL 1	1:200 @ A1
LD02	STANDARD DETAILS	NTS @ A1

### Landscape Character







Timber walkway

Signs reused from existing courtyards














PLANT SCHEDULE - OPAL SEASIDE

Code	Species	Common Name	Height	Size	Qty
TREES					
An-co	Angophora costata	Sydney Red Gum	7m	100L	5
Co-su	Corymbia 'Summer red'	Red flow ering gum	5m	100L	6
Cy-co	Cyathea cooperii	Coin Spot Tree Fern	5m	75L	8
El-eu	Elaeocarpus Reticulatus	Eumindi quandong	15m	400L	1
⊟-eu ⊟-re	Elaeocarpus Reticulatus	Blueberry Ash	12m	75L	7
Eu-ca	Eucalyptus caesia	Silver Princess	6-9m	100L	3
	Eucalyptus punctata	The state of the s	12m	100L	4
Eu-pu		Grey Gum	The second secon		-
La-in	Lagerstroemia indica	Crepe Myrtle	4m	100L	6
Pi-ch	Pistacia chinensis	Chinese Pistachio	15m	400L	4
Pl-ru	Plumeria rubra	Frangipani	6m	75L	3
Tr-la	Tristanopsis laurina 'Luscious'	Water Gum	7-12m	100L	1
Ul-lo	Ulmus parvifolia	Ulmus parvifolia	10m	400L	1
Wa-fl	Waterhousia floribunda	Weeping Lilly Pilly	11-15m	100L	3
SHRUBS					
Ac-ho	Acacia howittii	sticky w attle	2m	300mm	38
Ad-se	Adenanthos sericeus	Wooly Bush	3m	300mm	20
As-au	Asplenium australasicum	Birds Nest Fern	1.7m	300mm	12
Ca-sa	Camelia sasangua	Camelia	2M	300MM	9
Co-fr	Cordyline fruticosa 'rubra'	Pink Cordyline	1.5m	300mm	40
Cy-re	Cycas revoluta	Cycad	1.4m	45L	2
Ec-ca	Echium candicans	Pride of Madeira	1.5m	45L	17
Ga-fl	Gardenia florida	Cape Jasmine	1.5m	300mm	140
Lo-ka	Lomandra 'Katie Bells'	Lomandra	1.5m	200mm	36
Lo-pl	Loropetalum chinense 'Plum Delight'	Chinese Fringe Flower	1.8m	200mm	22
Mu-pa	Murraya "Min-a-min"	Orange Jessamine	1m	300mm	43
	The state of the s		3m	300mm	23
Sy-au	Syzygium Australe 'Bronze Hedgemaster'	Hedge Master Lilly Pilly			
Sy-bb	Syzigium australe 'Baby Boomer'	Lilly Pilly	1.5m	300mm	27
Sy-ca	Syzygium 'Cascade'	Lilly Pilly	2-3m	300mm	71
We-fr	Westringa fruticosa	Coastal rosemary	1.5m	300mm	104
We-na	Westringia Naringa	Coastal rosemary	1.5m	45L	87
Yu-el	Yucca elephantipes	Spineless yucca	2.5m	300mm	20
Za-fu	Zamia furfuracea	Cardboard Palm	1m	45L	34
GROUNDCO	VERS				
Sc-ae	Scaevola aemula' Bombay White'	Scaevola	0.3m	300mm	144
At-nu	Atriplex nummularia	Old Man Saltbush	0.4m	150mm	177
Ca-gl	Carpobrotus glaucescens	Pig face	0.2m	150mm	268
Cr-pe	Crinum pedunculatum	Swamp Lily	0.8m	150mm	22
De-sp	Dendrobium speciosum	Rock Lilly	0.3m	300mm	18
Di-ca	Dianella 'Tassie Red'	Dianella var	0.3m	150mm	509
Di-ca Di-mo	Diplarrena moraea	White iris	0.5	200mm	15
Di-mo Di-si	Dipiarrena moraea Dichondra 'Silver Falls'	Kidney weed	0.5 0.5m	150mm	437
Gr-su	The state of the s		0.5111	150mm	250
	Grevillea juniperina x rhyolitica 'Sunkissed'	Mounding grevillea	0.5	500 8000 5000	
Ha-me	Hardenbergia violacea 'Meema'	False Sarsparilla	0.5m	150mm	250
Li-mu Managa	Liriope Muscari	Lilyturf	0.5m	150mm	304
Ma-sa	Mandevilla sanderi	Rock Trumpet	climber	150mm	40
Mi-st	Microlaena stipoides	Wheeping grass	0.7m	150mm	15
Pe-le	Persoonia levis	Broad-leaved Geebung	1m	300mm	10
St-vi	Stackhousia viminea	Creamy candles	0.7m	300mm	27
NOTE:					
NO IE.					


Planting characters

Client: Opal Aged Care




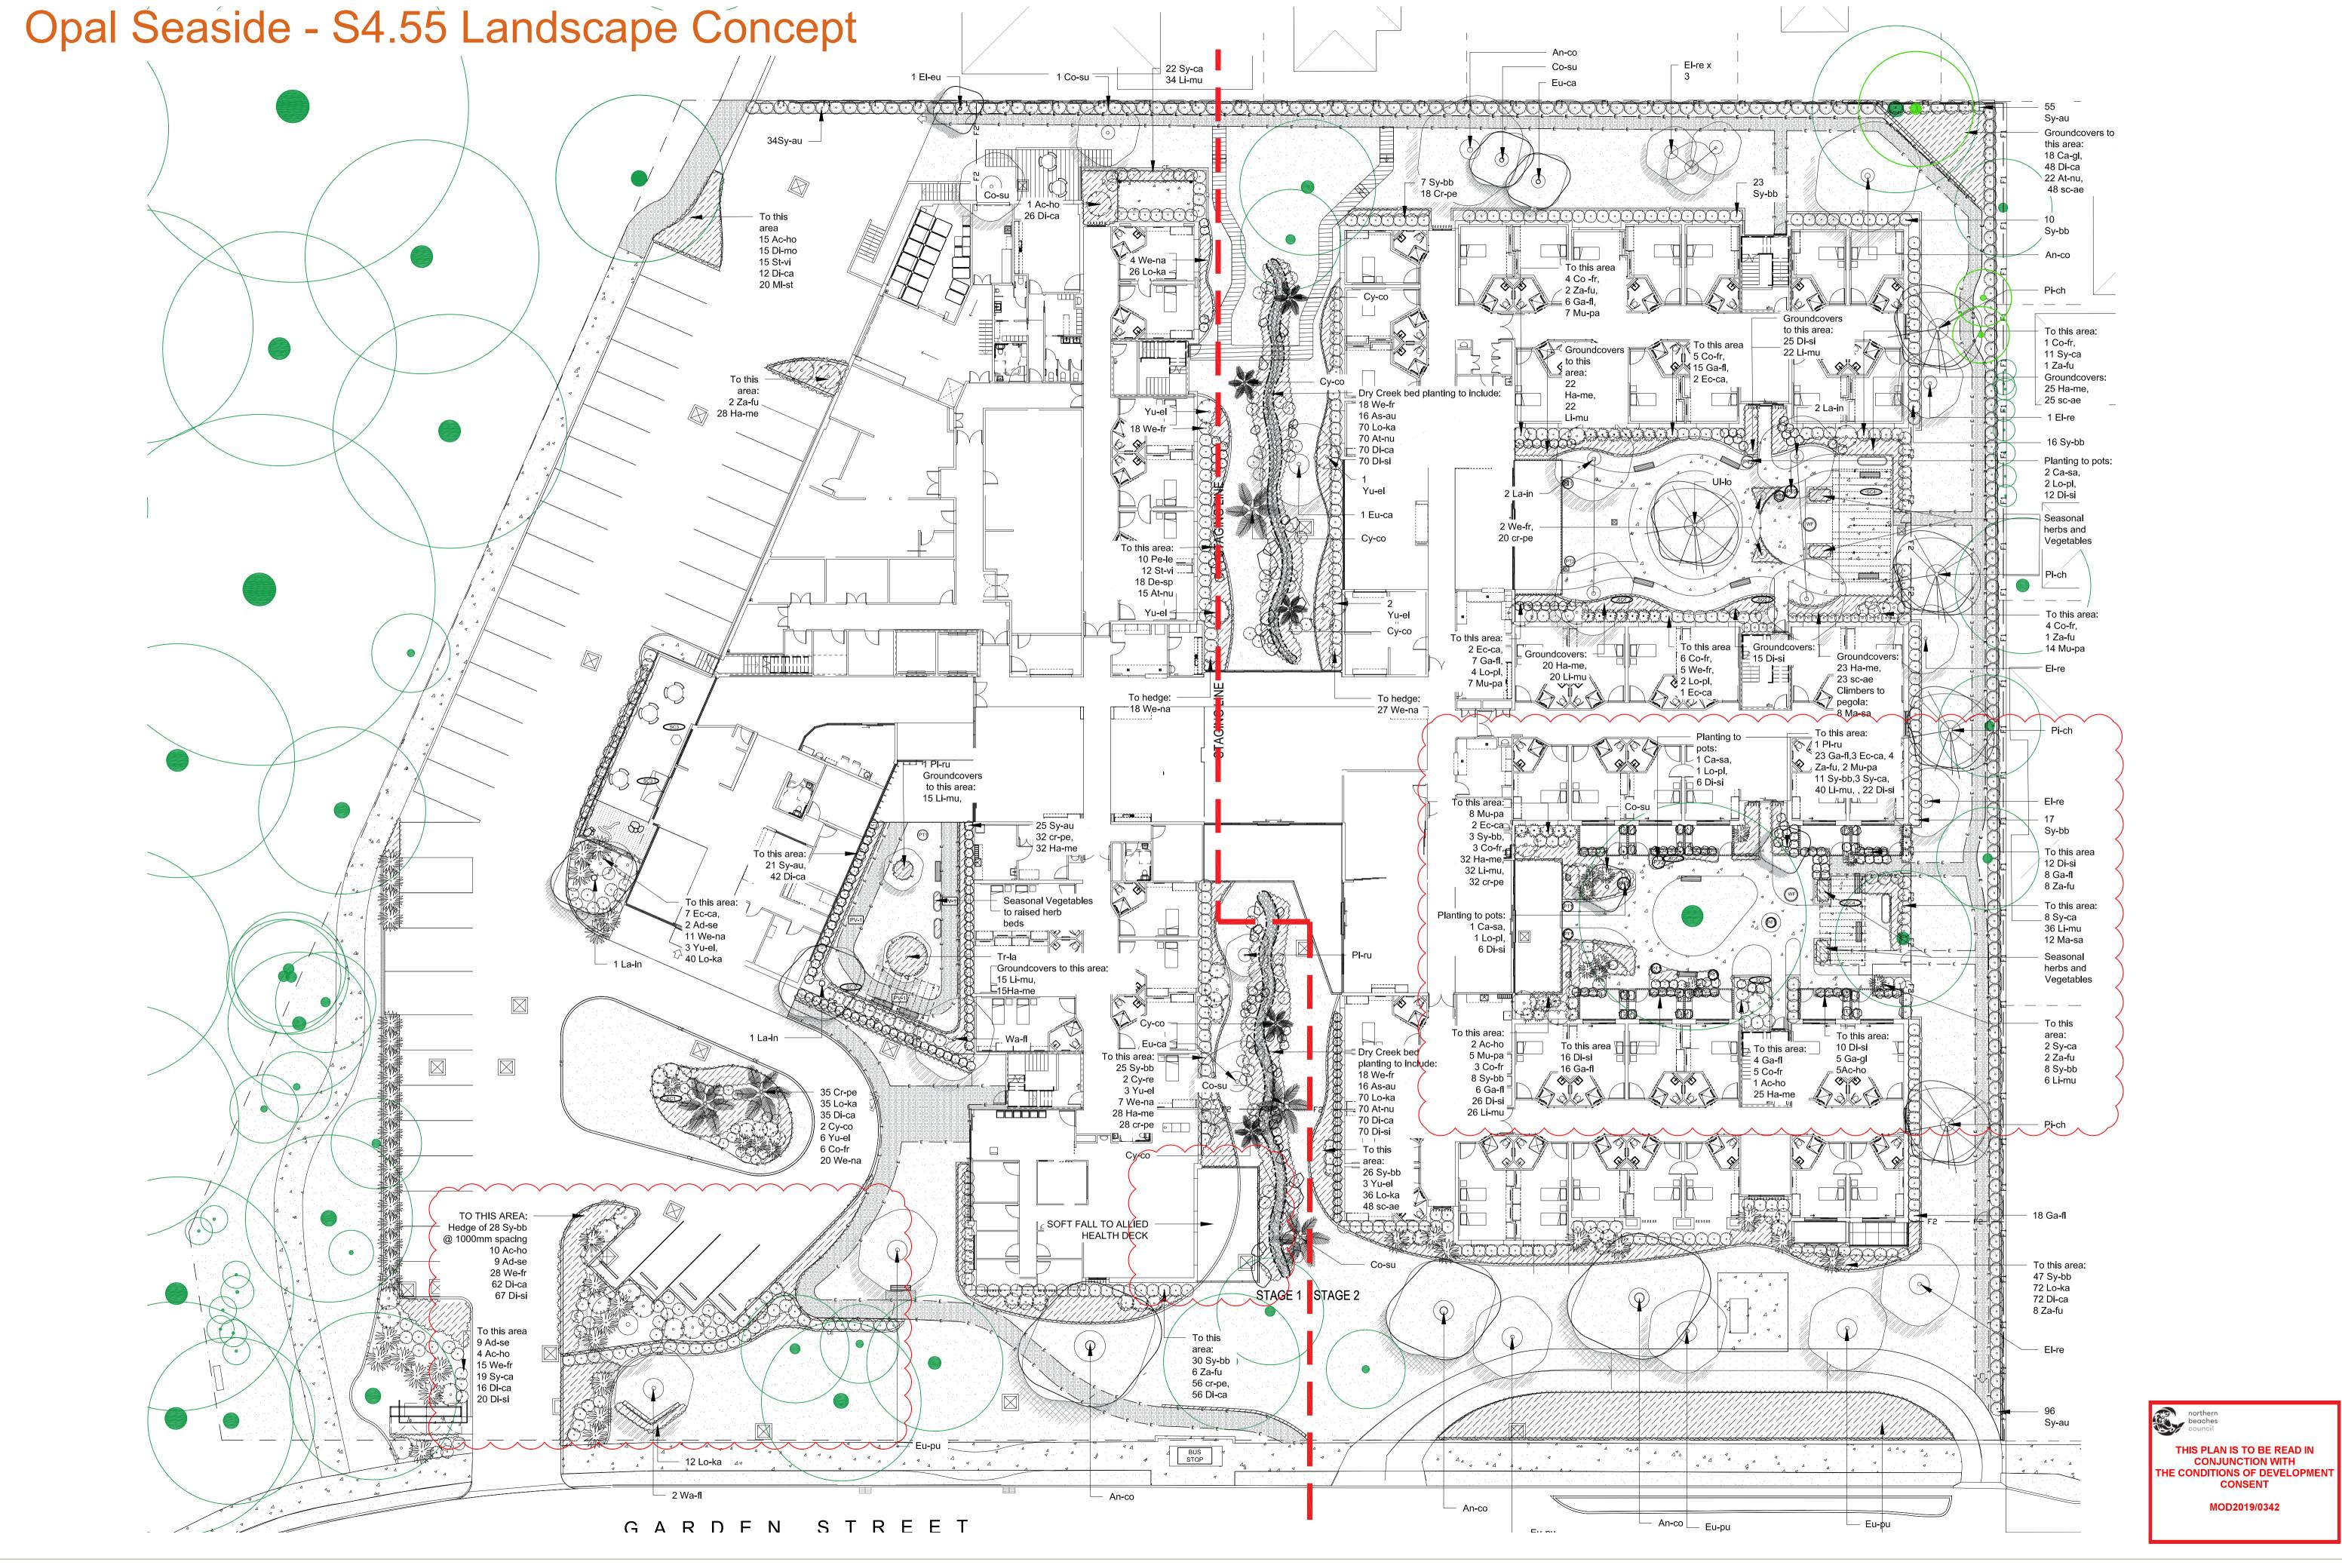

# Opal Seaside - S4.55 Landscape Concept

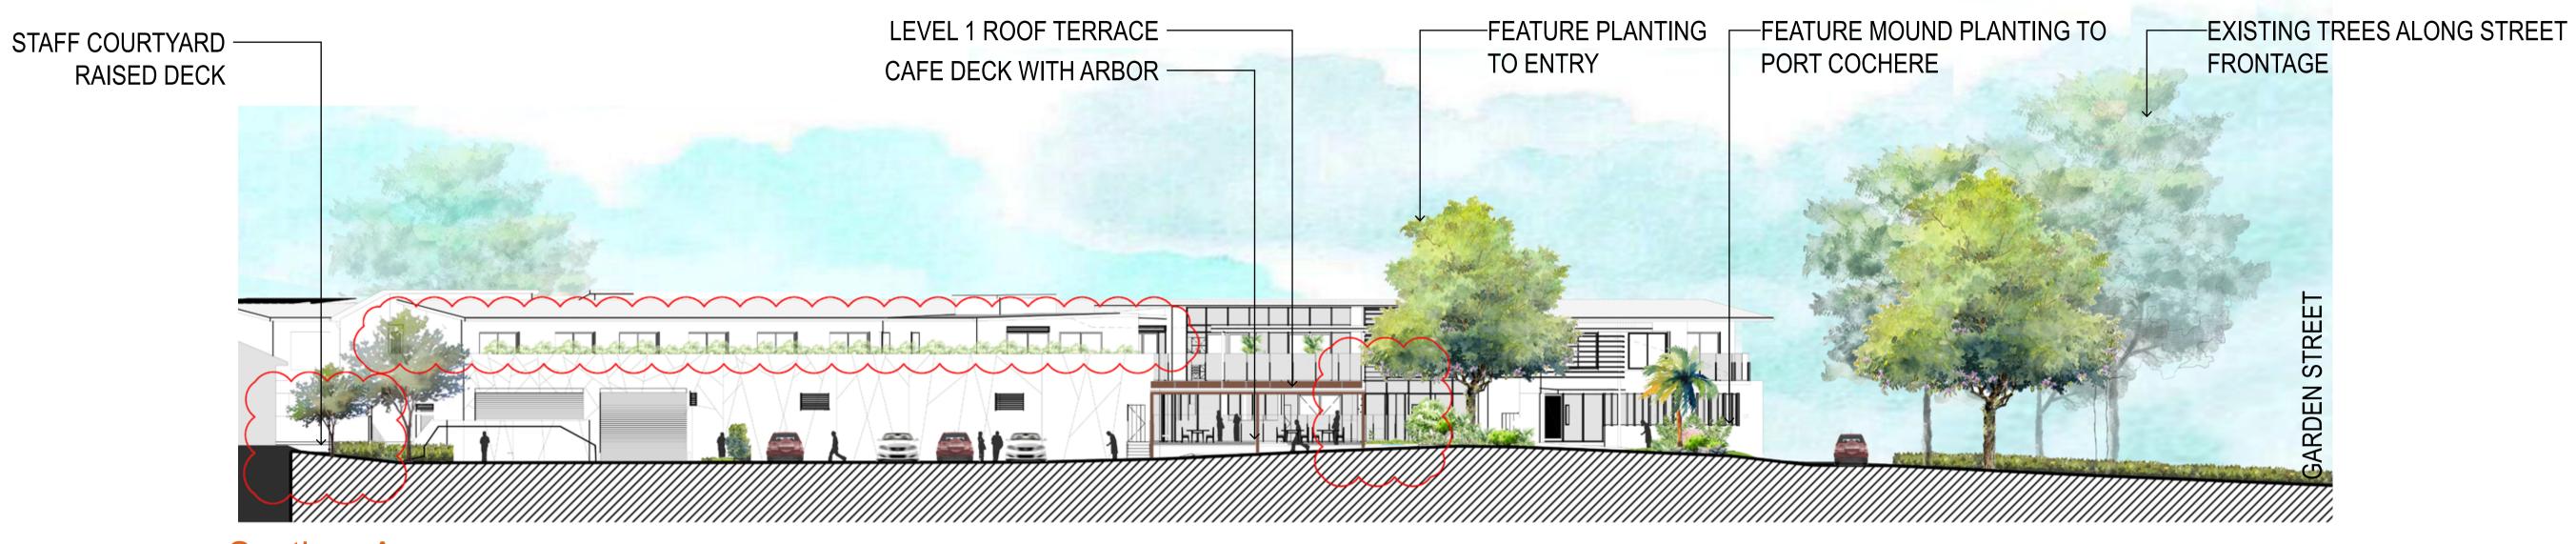


Section\_A 1:200@A1

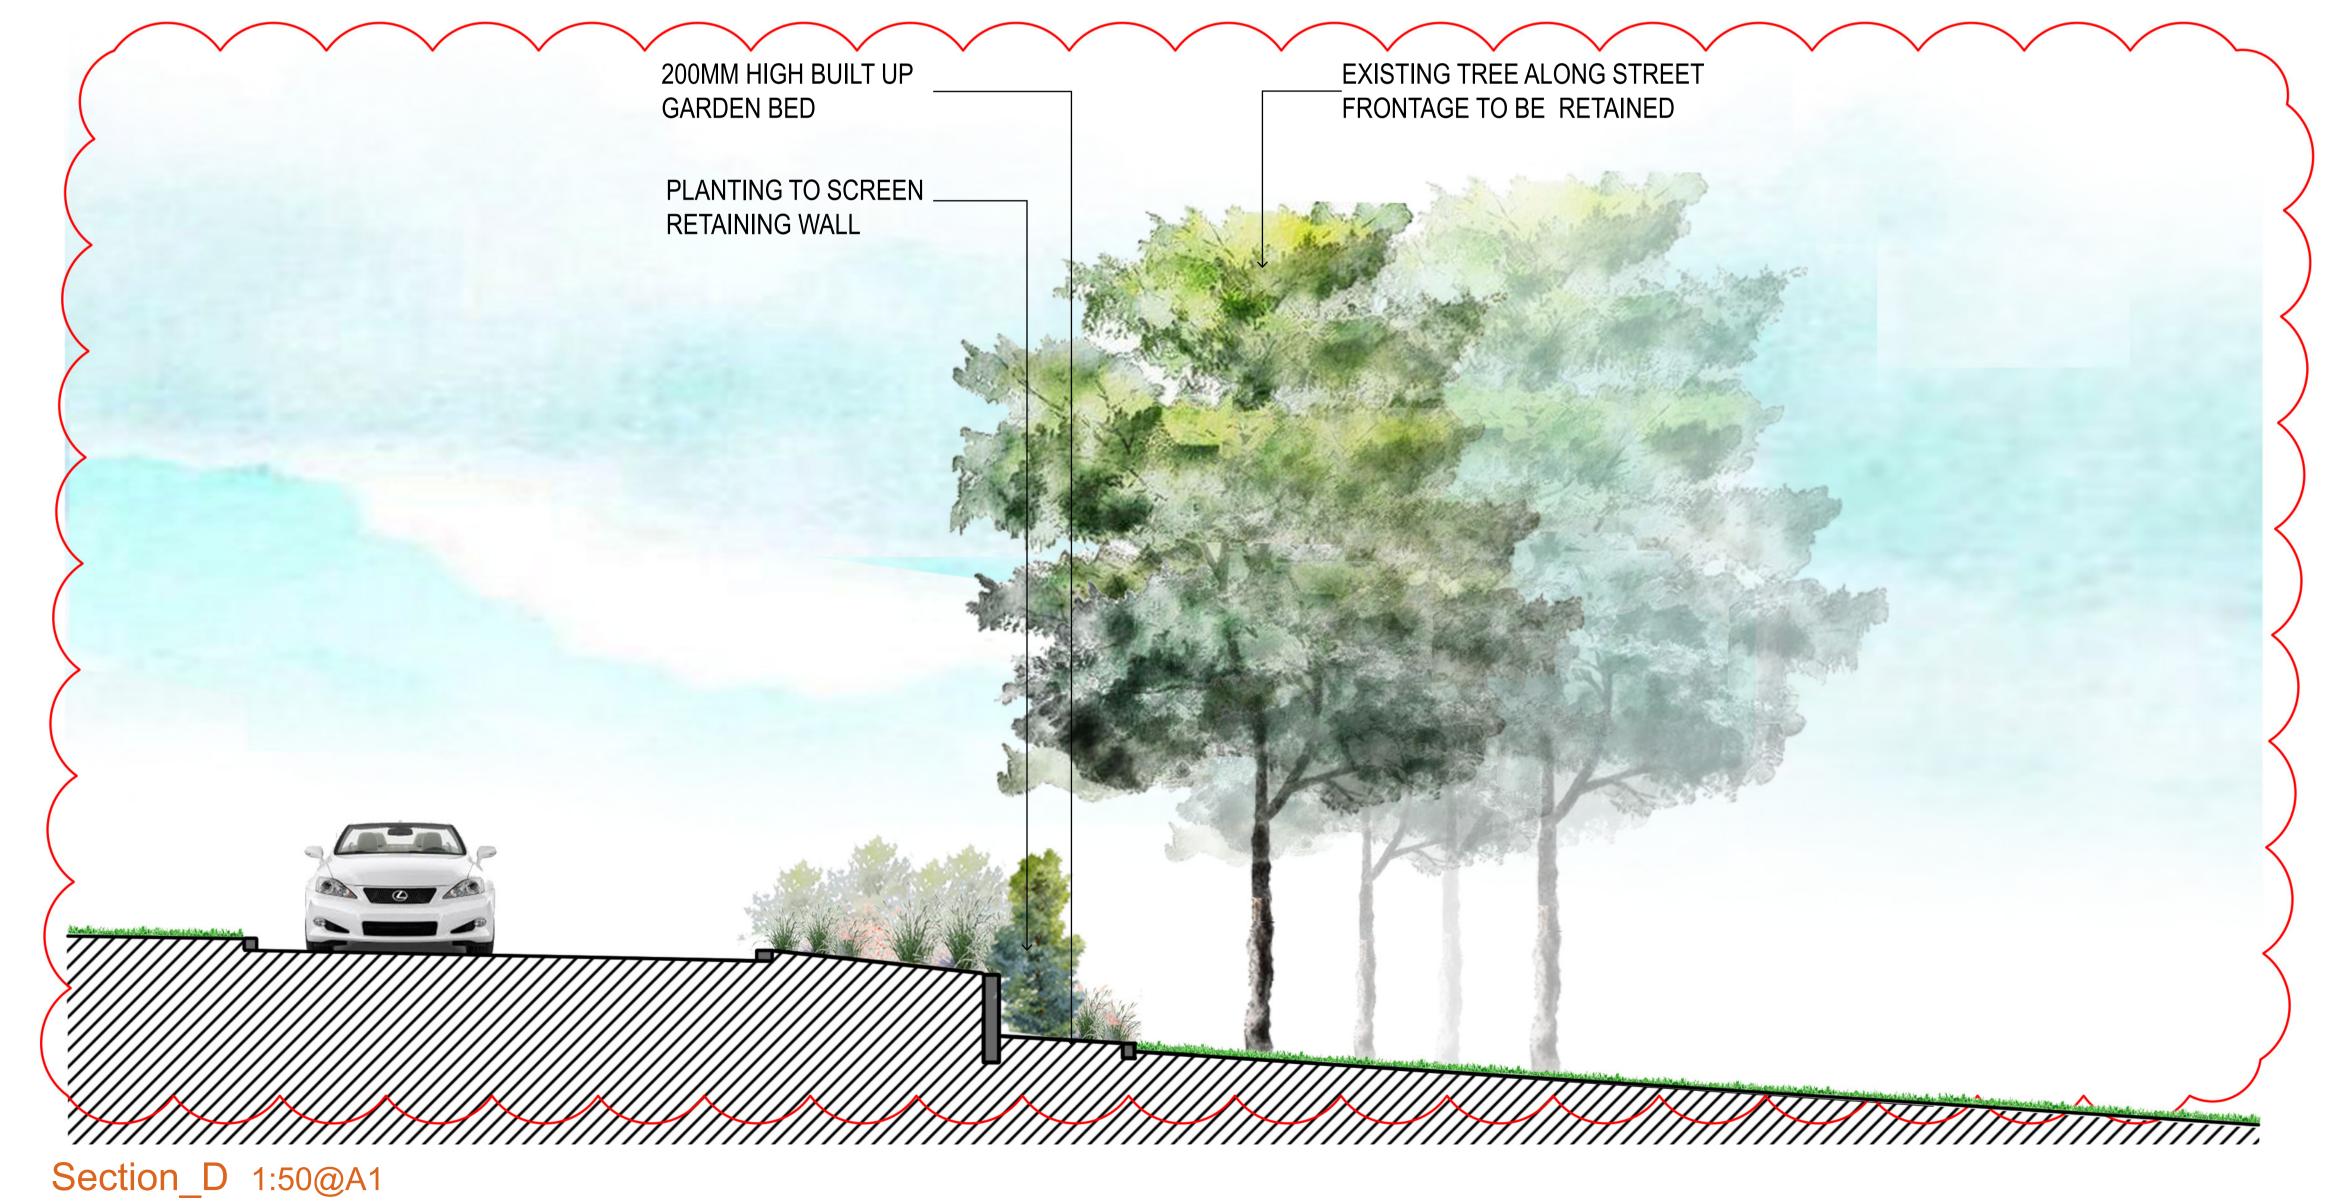


CONJUNCTION WITH
THE CONDITIONS OF DEVELOPMENT
CONSENT

Project No: 16-204s Client: Opal Aged Care

# Opal Seaside - S4.55 Landscape Concept

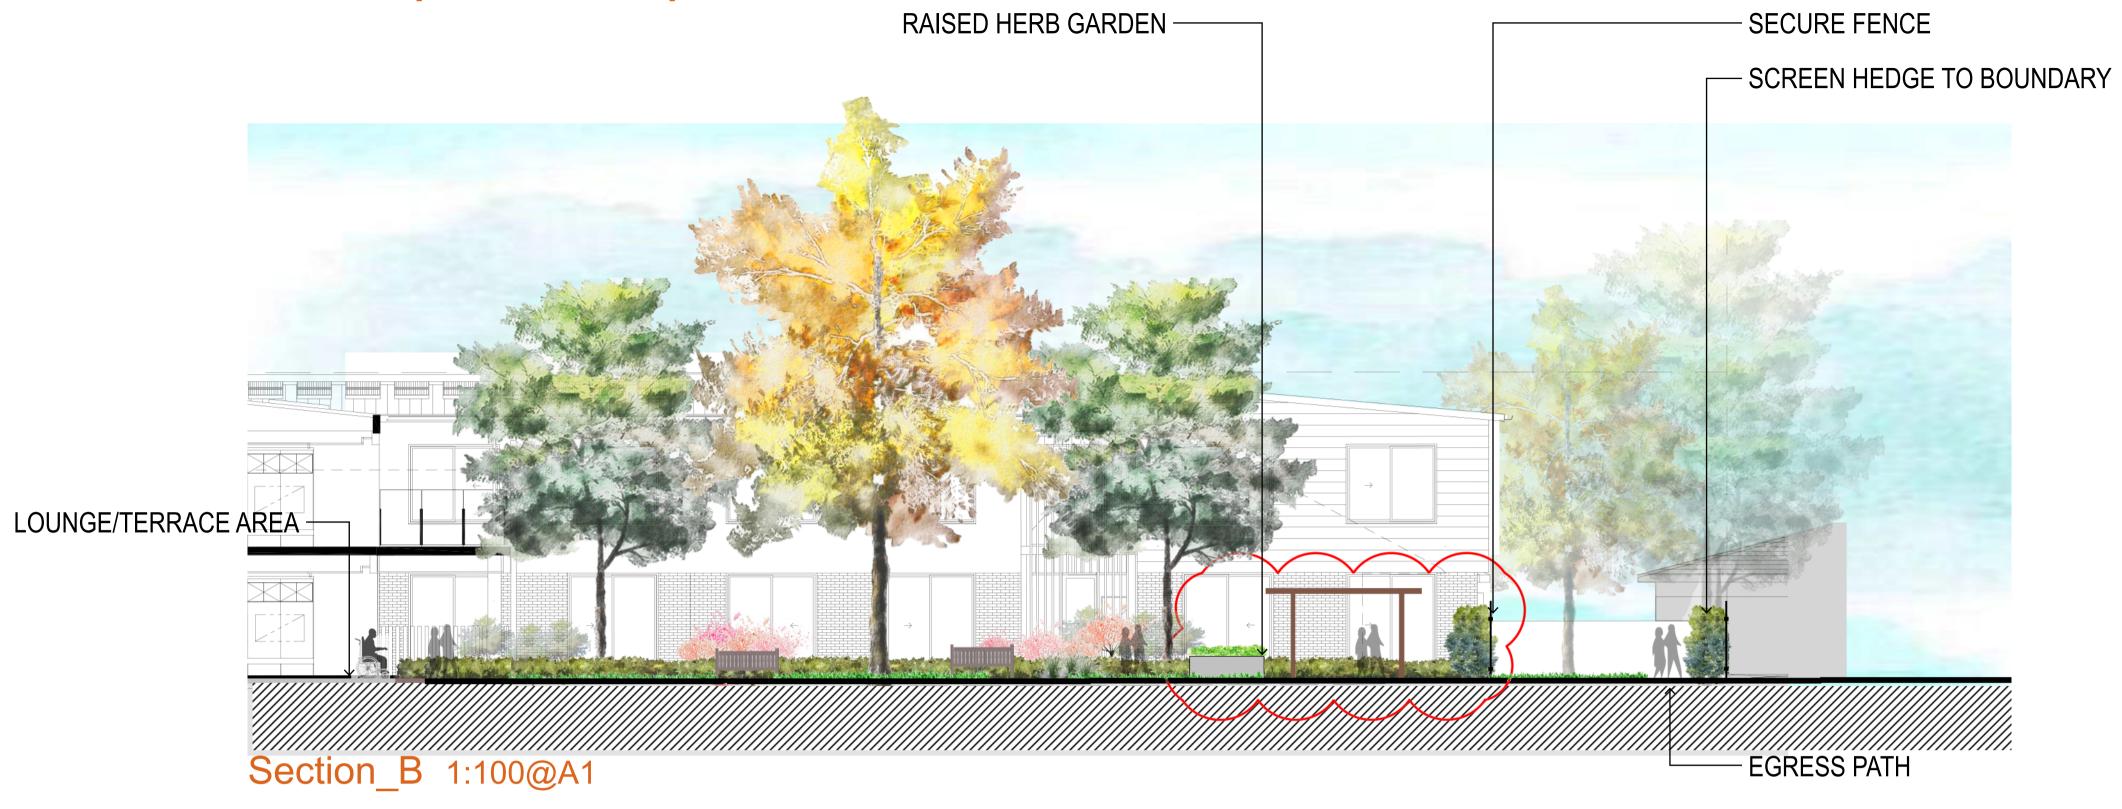

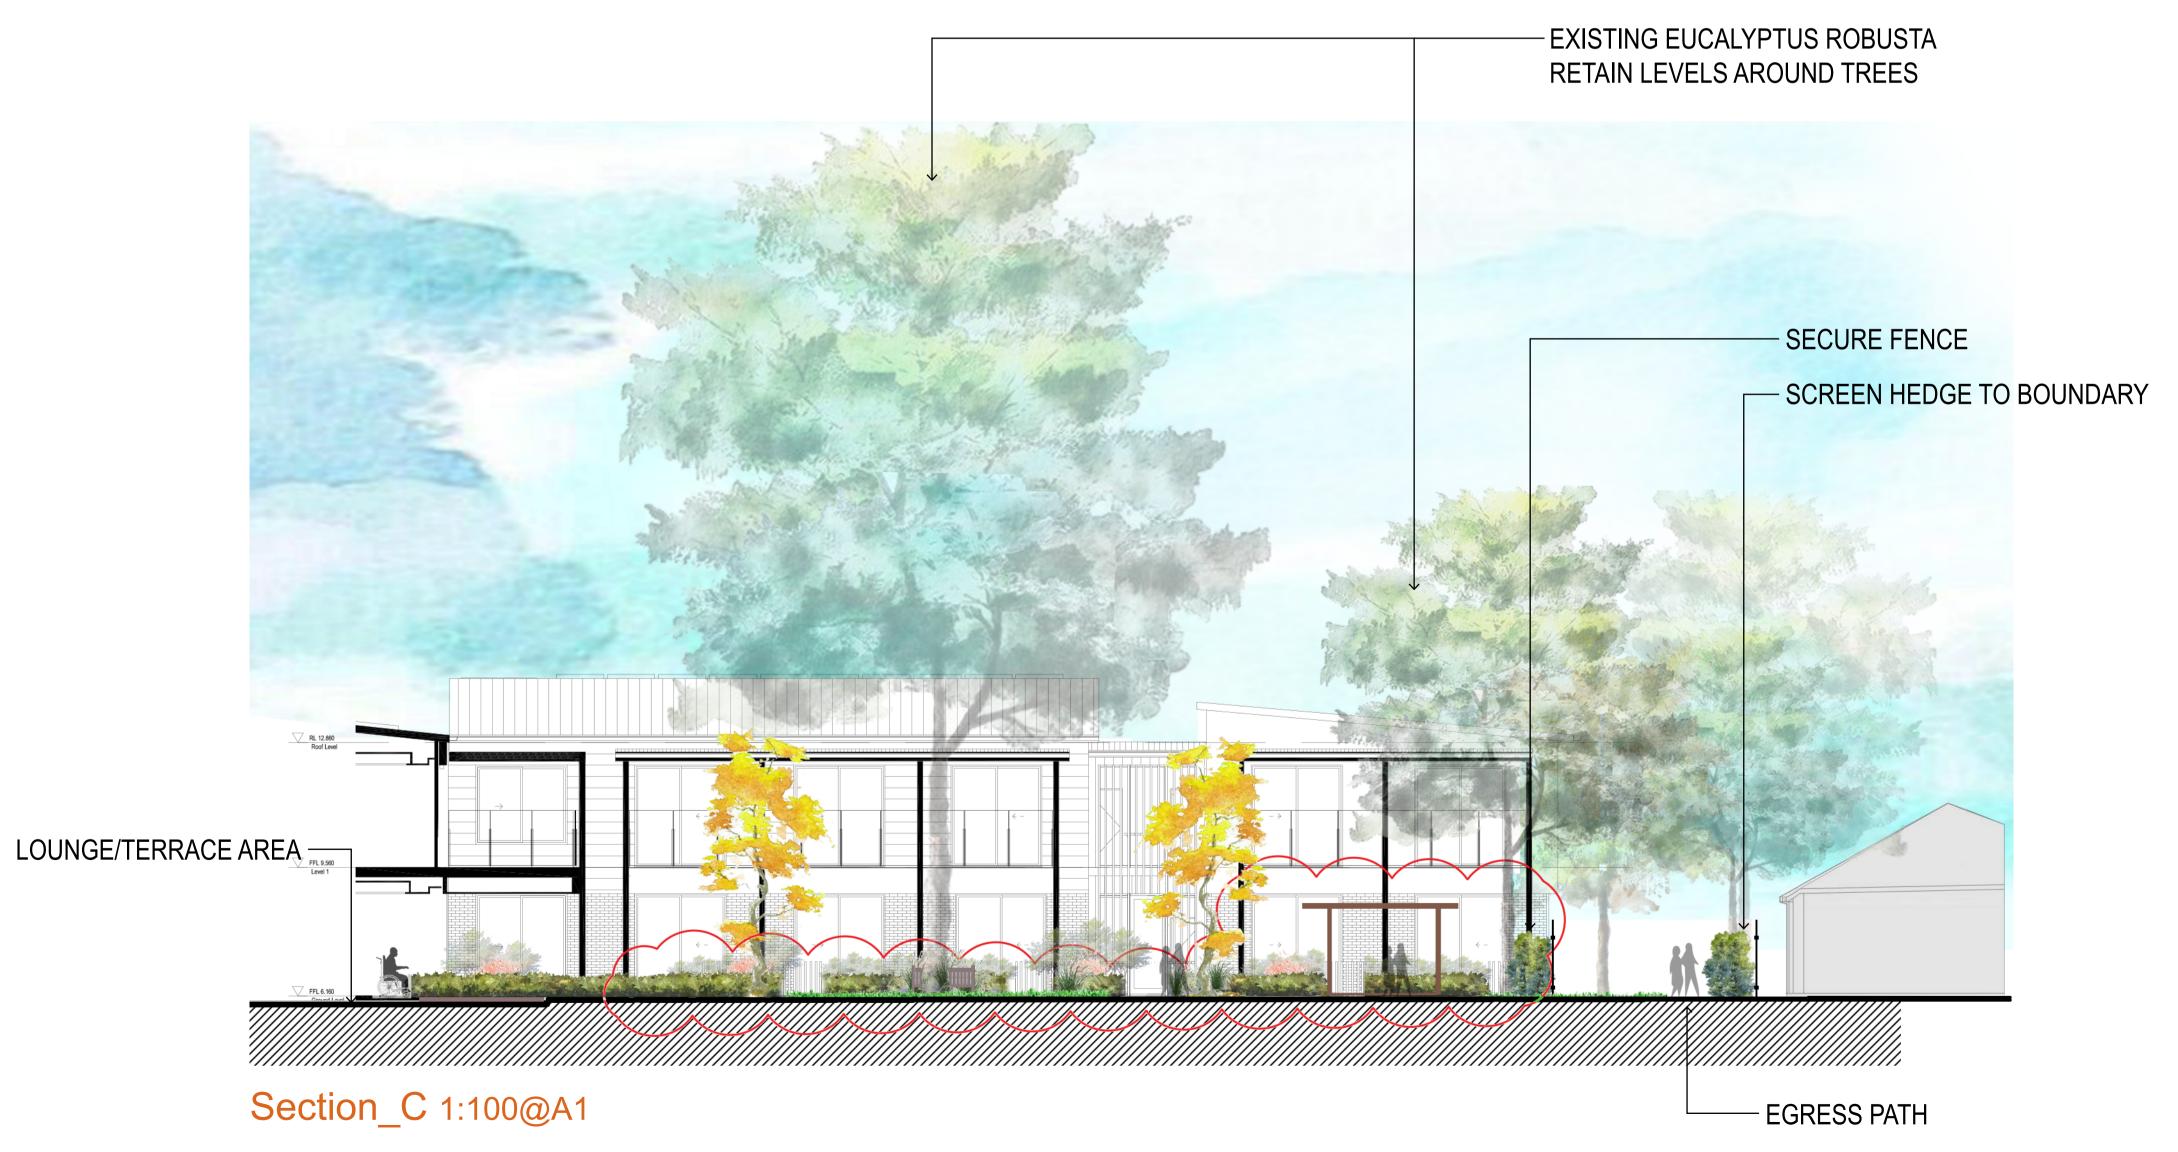



Date: 24.06.2019

# Opal Seaside - S4.55 Landscape Concept



### Design Elements

- Roof Terrace overlooking Irrawong reserve
- B Screen planting to mechanical plant area
- Roof terraces overlooking courtyards below
- Gravel mulch to provide visual amenity to terraces

### Design Precedents



Raised planter troughs to roof terrace





Feature plants to small terraces





Date: 24.06.2019

Project: OPAL Seaside

Project No: 16-204s Client: Opal Aged Care

