SARGOOD CENTRE - SECTION 96

ARCHITECTURAL DRAWING SET FOR: SARGOOD CENTRE


1 BRISSENDEN AVENUE COLLAROY NSW 2079

CLIENT: SARGOOD

DA-000	COVERSHEET & LOCATION PLAN	NTS
DA-001	SITE PLAN	1:200
DA-002	SITE ANALYSIS PLAN	1:200
DA-100	BASEMENT FLOOR PLAN	1:200
DA-101	LEVEL 1 FLOOR PLAN	1:200
DA-102	LEVEL 2 FLOOR PLAN	1:200
DA-501	ELEVATIONS	1:200
DA-601	SECTIONS	1:200
DA-901	SHADOW DIAGRAMS AUTUMN EQUINOX	1:500
DA-902	SHADOW DIAGRAMS WINTER SOLSTICE	1:500
DA-903	SHADOW DIAGRAMS SUMMER SOLSTICE	1:500
DRAWING	OVERLAYS	
DA-110	BASEMENT FLOOR PLAN. S96 OVERLAY	1:200
DA-111	LEVEL 1 FLOOR PLAN. S96 OVERLAY	1:200
DA-112	LEVEL 2 FLOOR PLAN. S96 OVERLAY	1:200
DA-511	ELEVATIONS. S96 OVERLAY	1:200
DA-611	SECTIONS. S96 OVERLAY	1:200






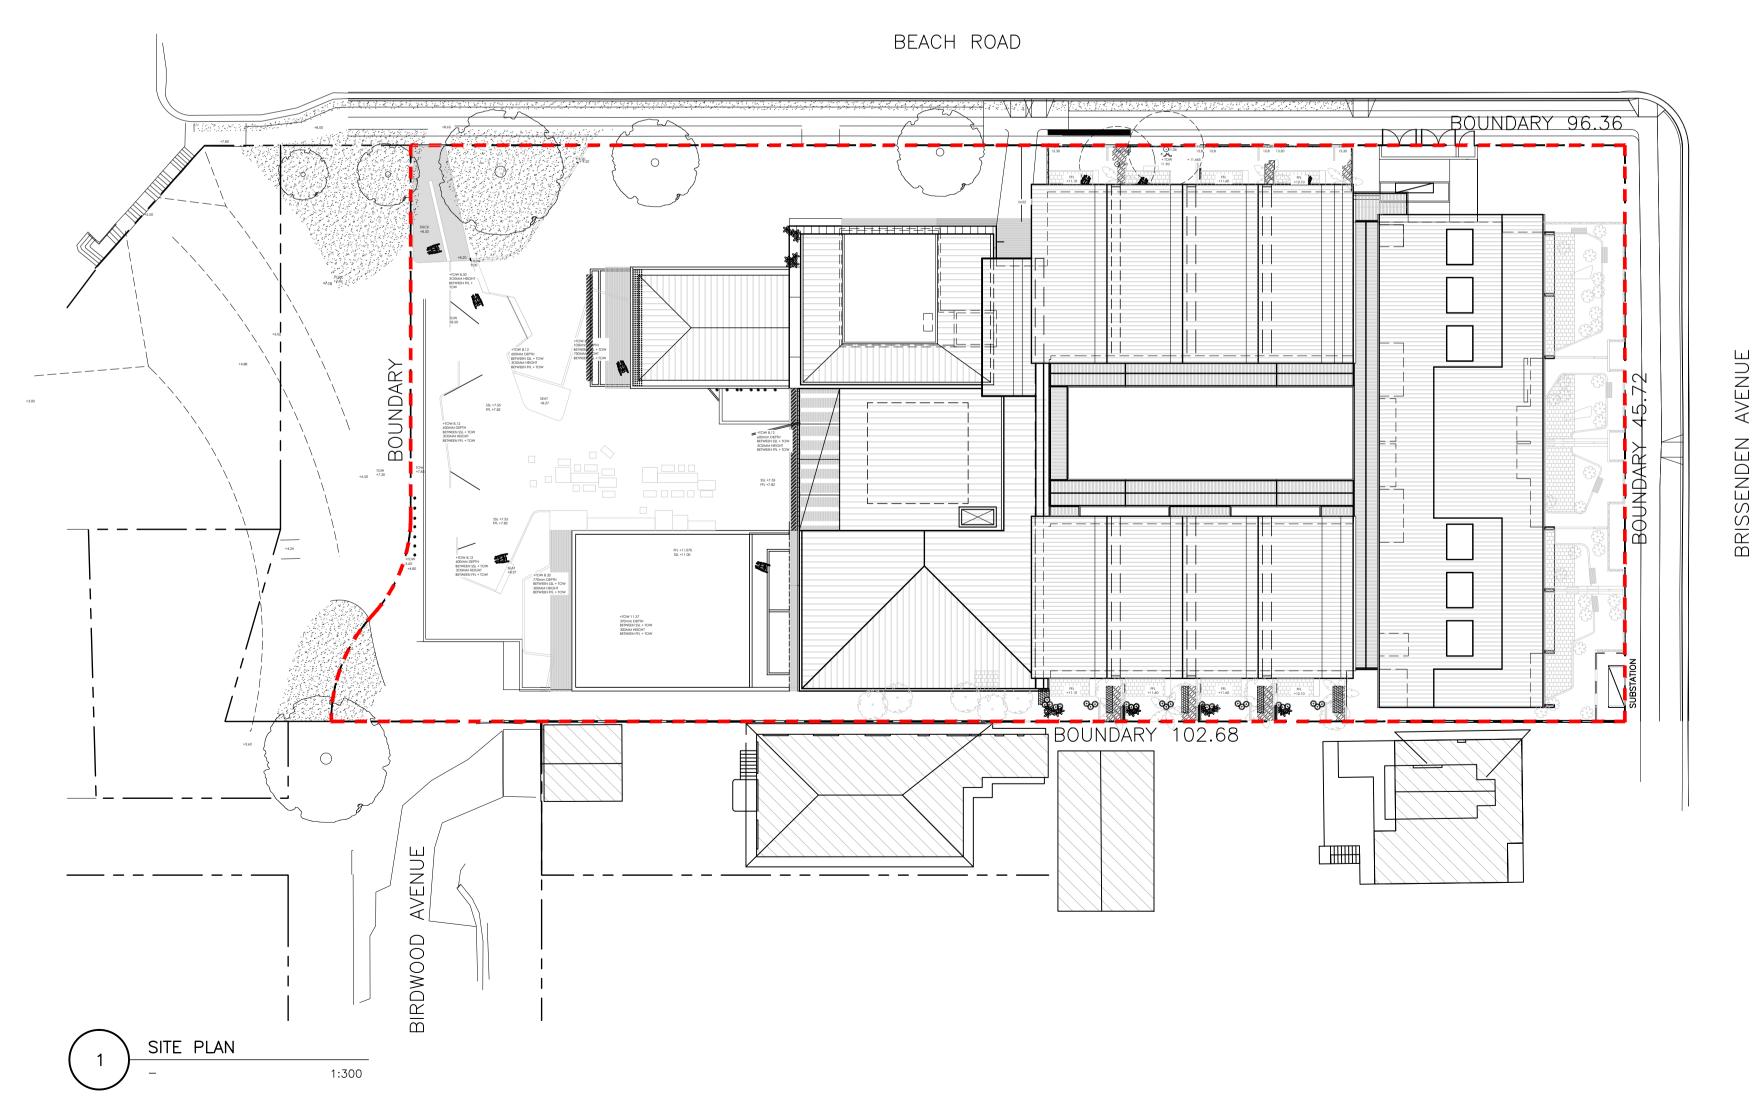



PRELIMINARY ISSUED FOR REVIEW
ISSUED FOR COUNCIL PRE-DA
ISSUED FOR CLIENT REVIEW
GENERAL UPDATE
95% REVIEW
ISSUE FOR SECTION 96
ISSUE FOR SECTION 96
ISSUE FOR SECTION 96 APPLICATION



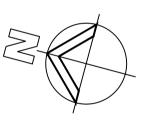






SARGOOD CENTRE 1 Brissenden Avenue Collaroy NSW 2097

COVER SHEET


Drawing No.		Issue
DA-000		8
Scale		Drawing Size
1:300		A1
Project No.	Date	Drawn By
1148	JULY 2012	RG

1148_SARGOOD/DWG FILES/PLOT

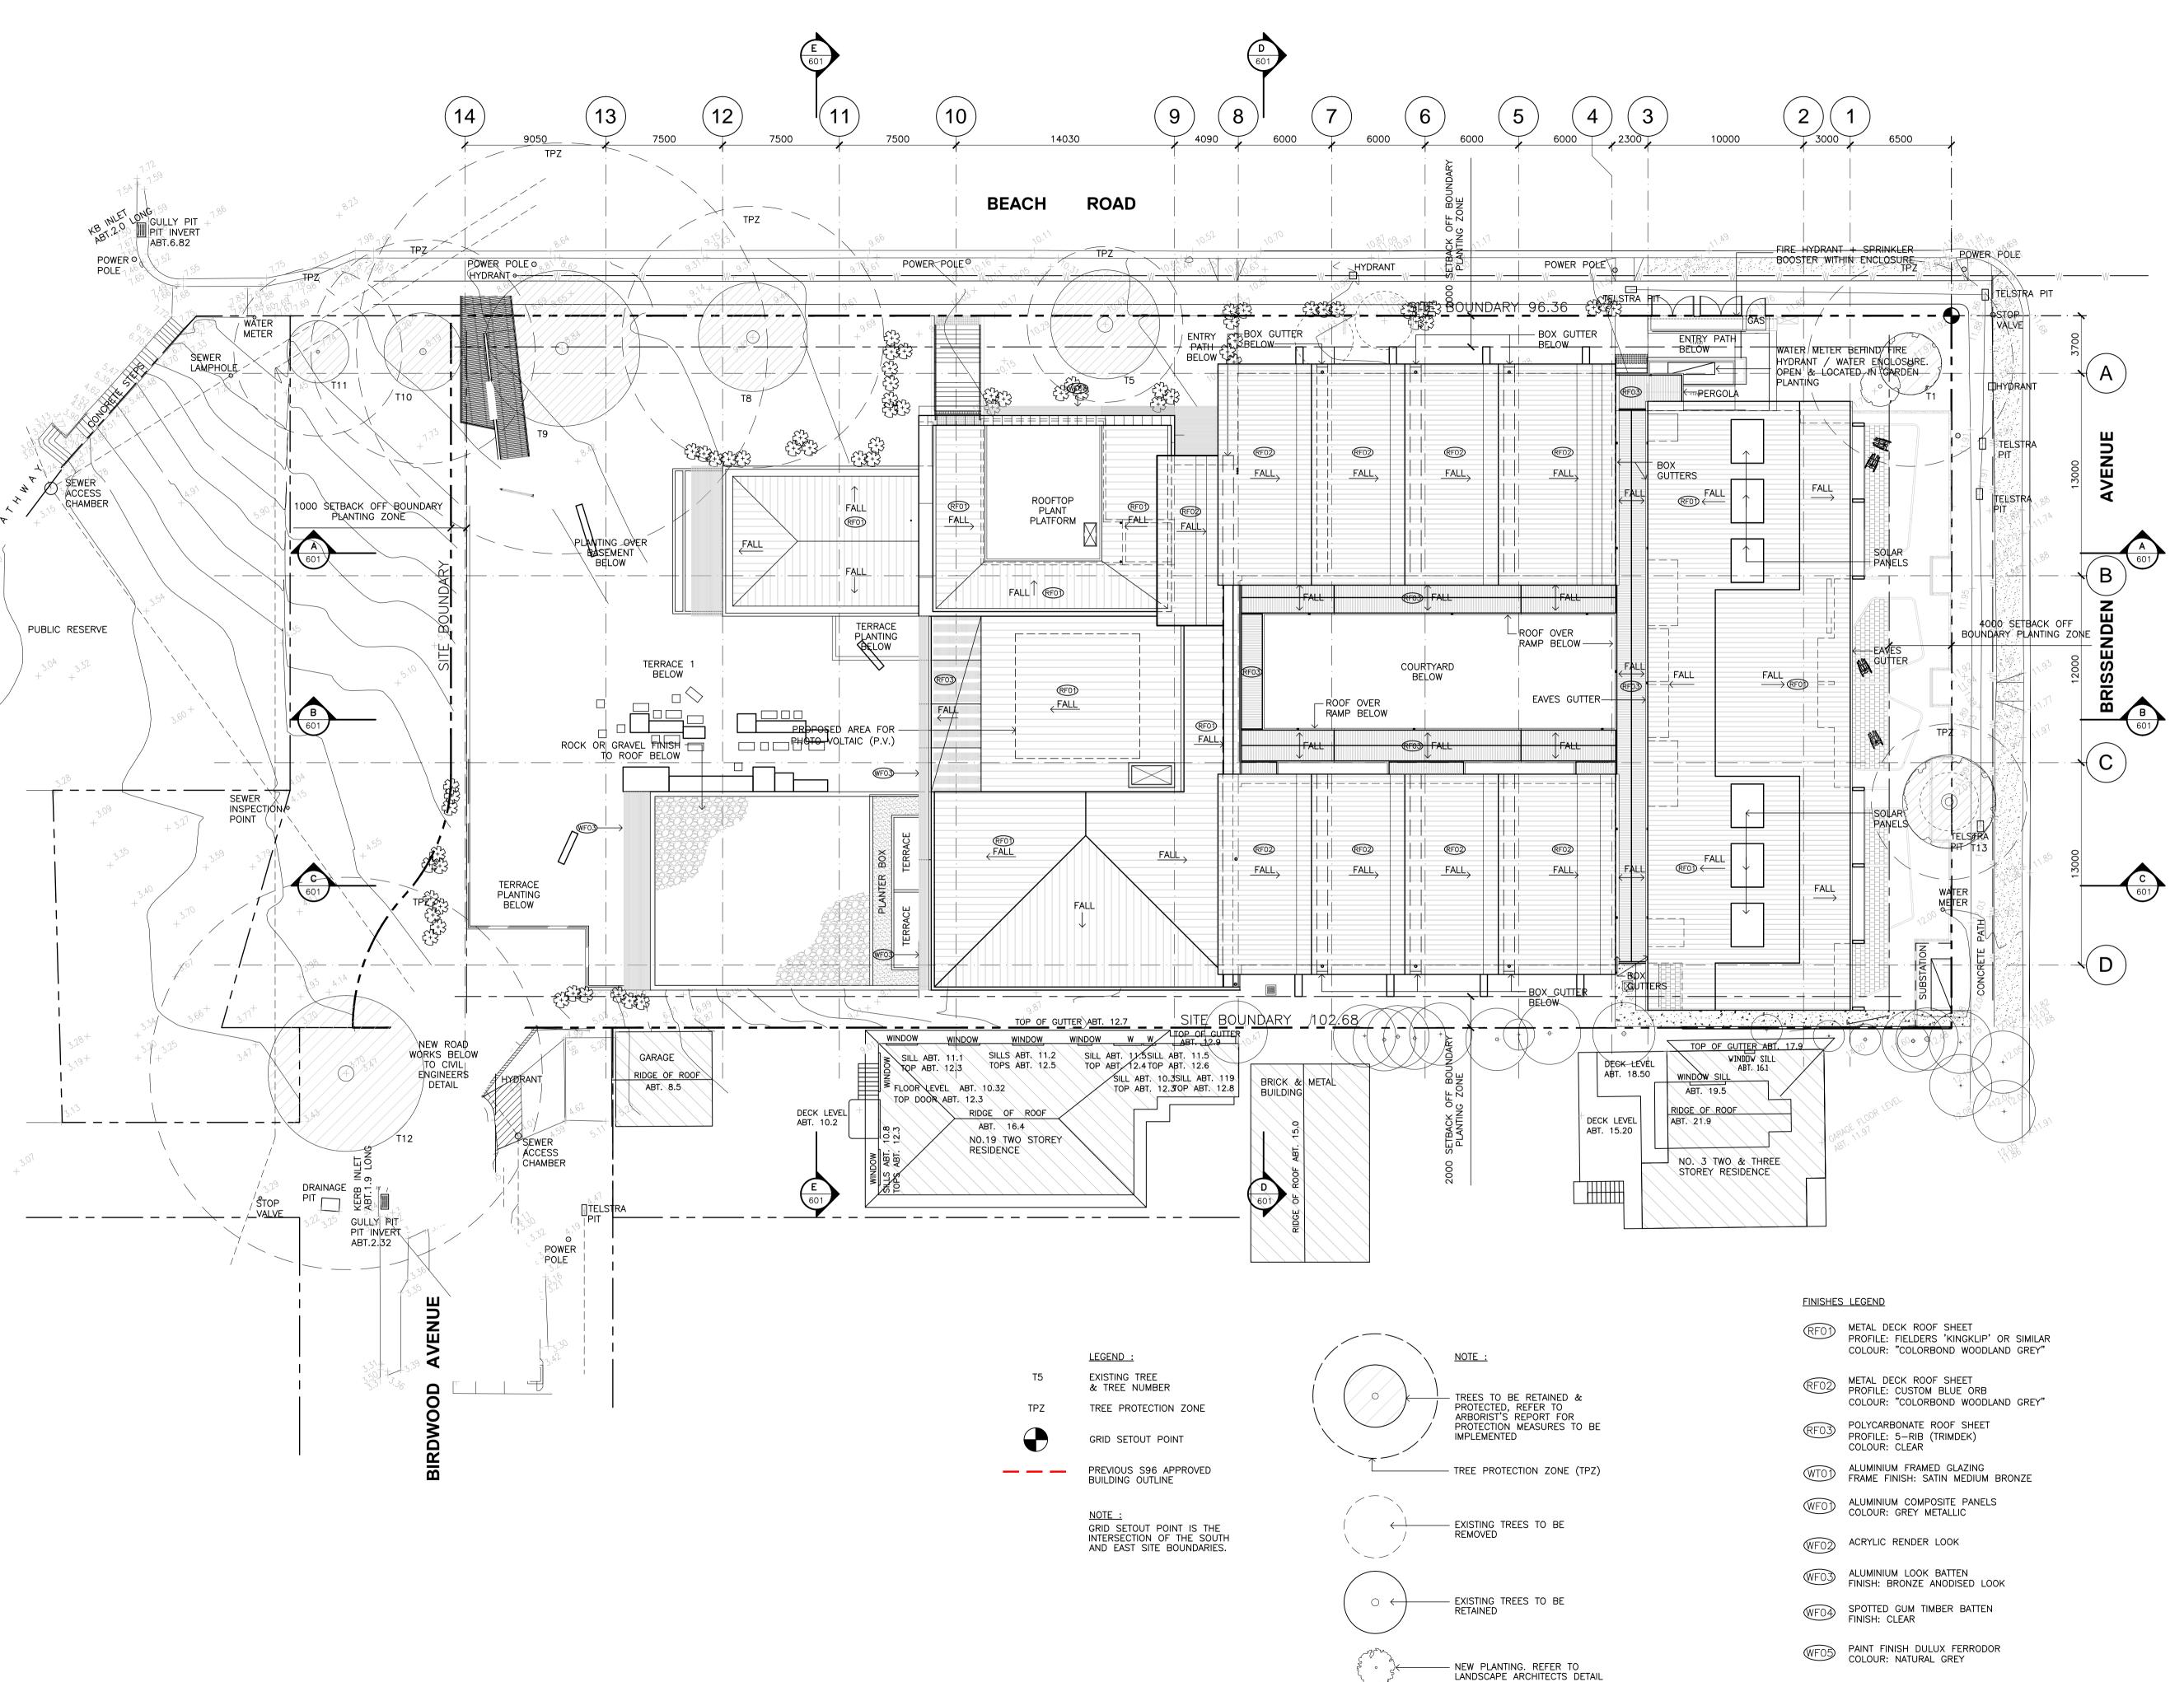

 PRELIMINARY ISSUED FOR REVIEW **CLIENT REVIEW** 13.03.12 ISSUED FOR COUNCIL PRE-DA 27.03.12 ISSUED FOR CLIENT REVIEW 02.04.12 GENERAL UPDATE 11.04.12 COLOUR ADDED 16.04.12 ISSUED TO CONSULTANTS 27.04.12 95% REVIEW 11.05.12 ISSUE FOR FINAL REVIEW 29.06.12 ISSUE FOR SECTION 96 03.07.12 UPDATED FOR S96 APPLICATION 19.11.13 13.12.13 ISSUED FOR S96 APPLICATION ISSUED FOR S96 APPLICATION 29.01.14









Project

Client


SARGOOD CENTRE 1 Brissenden Avenue Collaroy NSW 2097

SITE PLAN

Drawing No.		Issue
DA-001		13
Scale		Drawing Size
1:200		A1
Project No.	Date	Drawn By
1148	JULY 2012	RG
CAD Poforonce		


CAD Reference

1148_SARGOOD/DWG FILES/PLOT

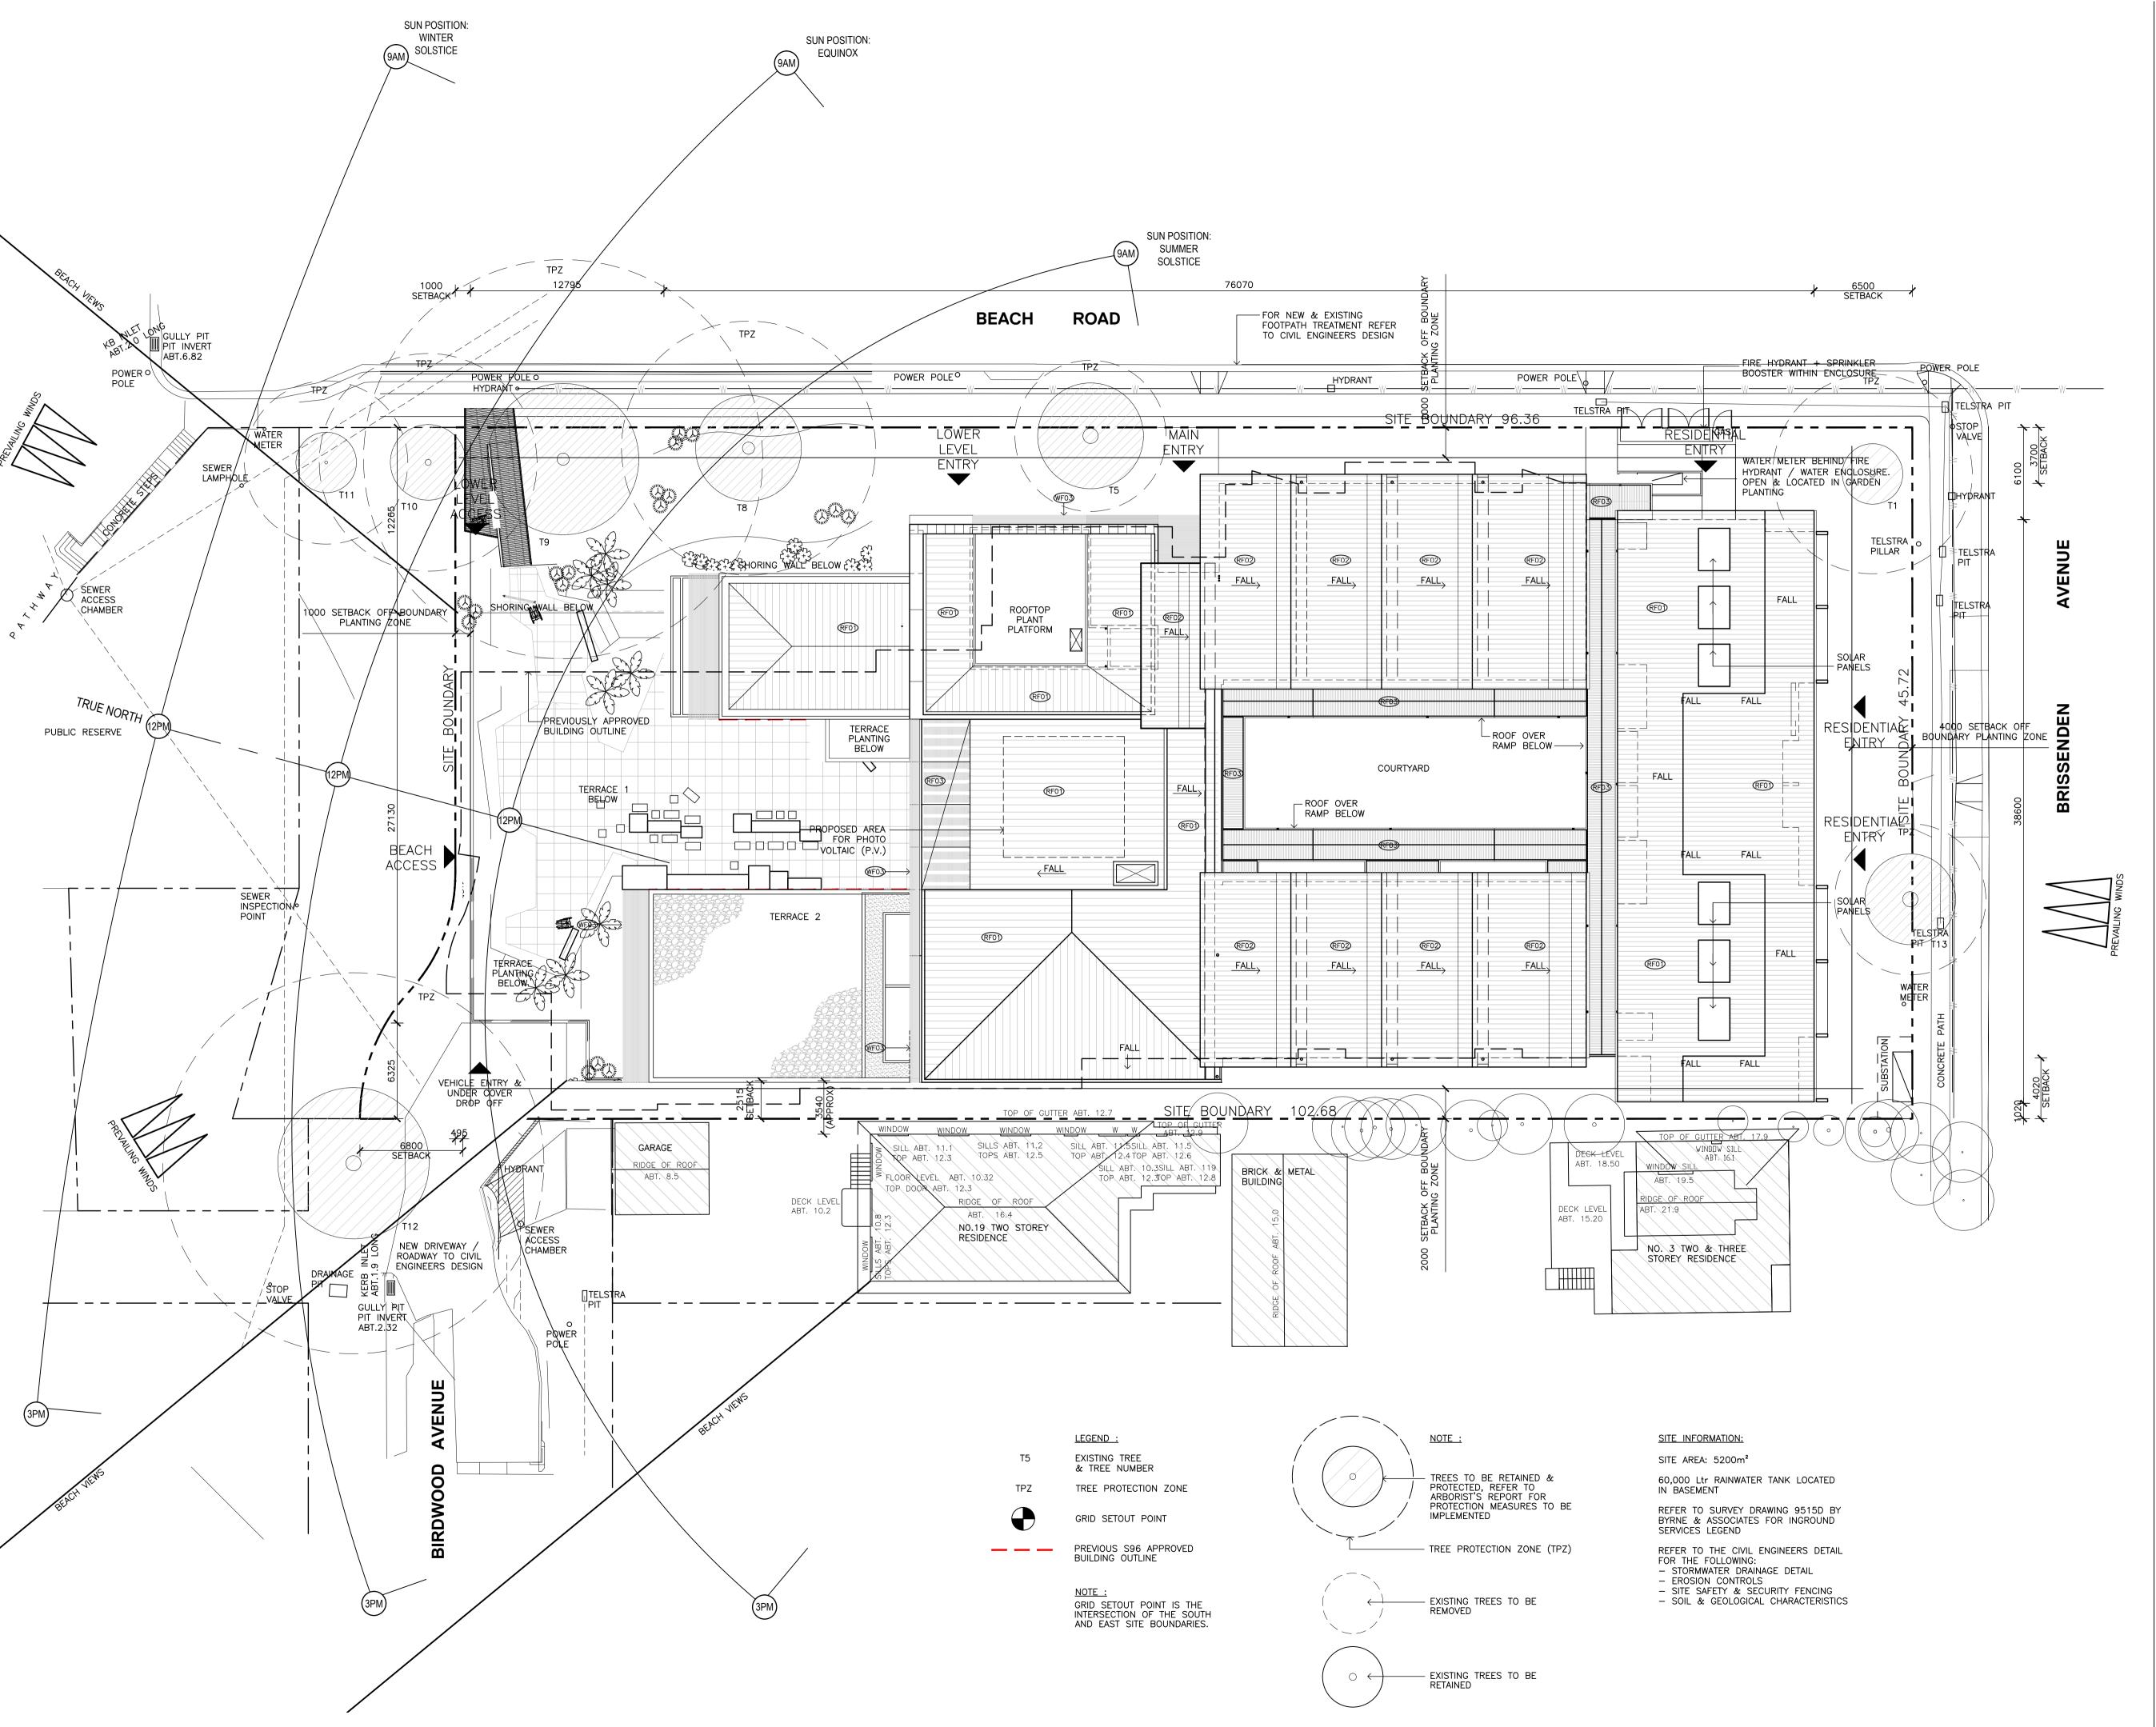

 IssueDescriptionDate1PRELIMINARY ISSUED FOR REVIEW24.05.122ISSUED FOR SECTION 96 APPLICATION03.07.123ISSUED FOR SECTION 96 APPLICATION13.12.134ISSUED FOR SECTION 96 APPLICATION29.01.14









Project

Client


SARGOOD CENTRE 1 Brissenden Avenue Collaroy NSW 2097


tle


SITE ANALYSIS PLAN

Drawing No. DA-002		Issue 4
Scale 1:200		Drawing Size
Project No. 1148	Date JULY 2012	Drawn By

1148_SARGOOD/DWG FILES/PLOT

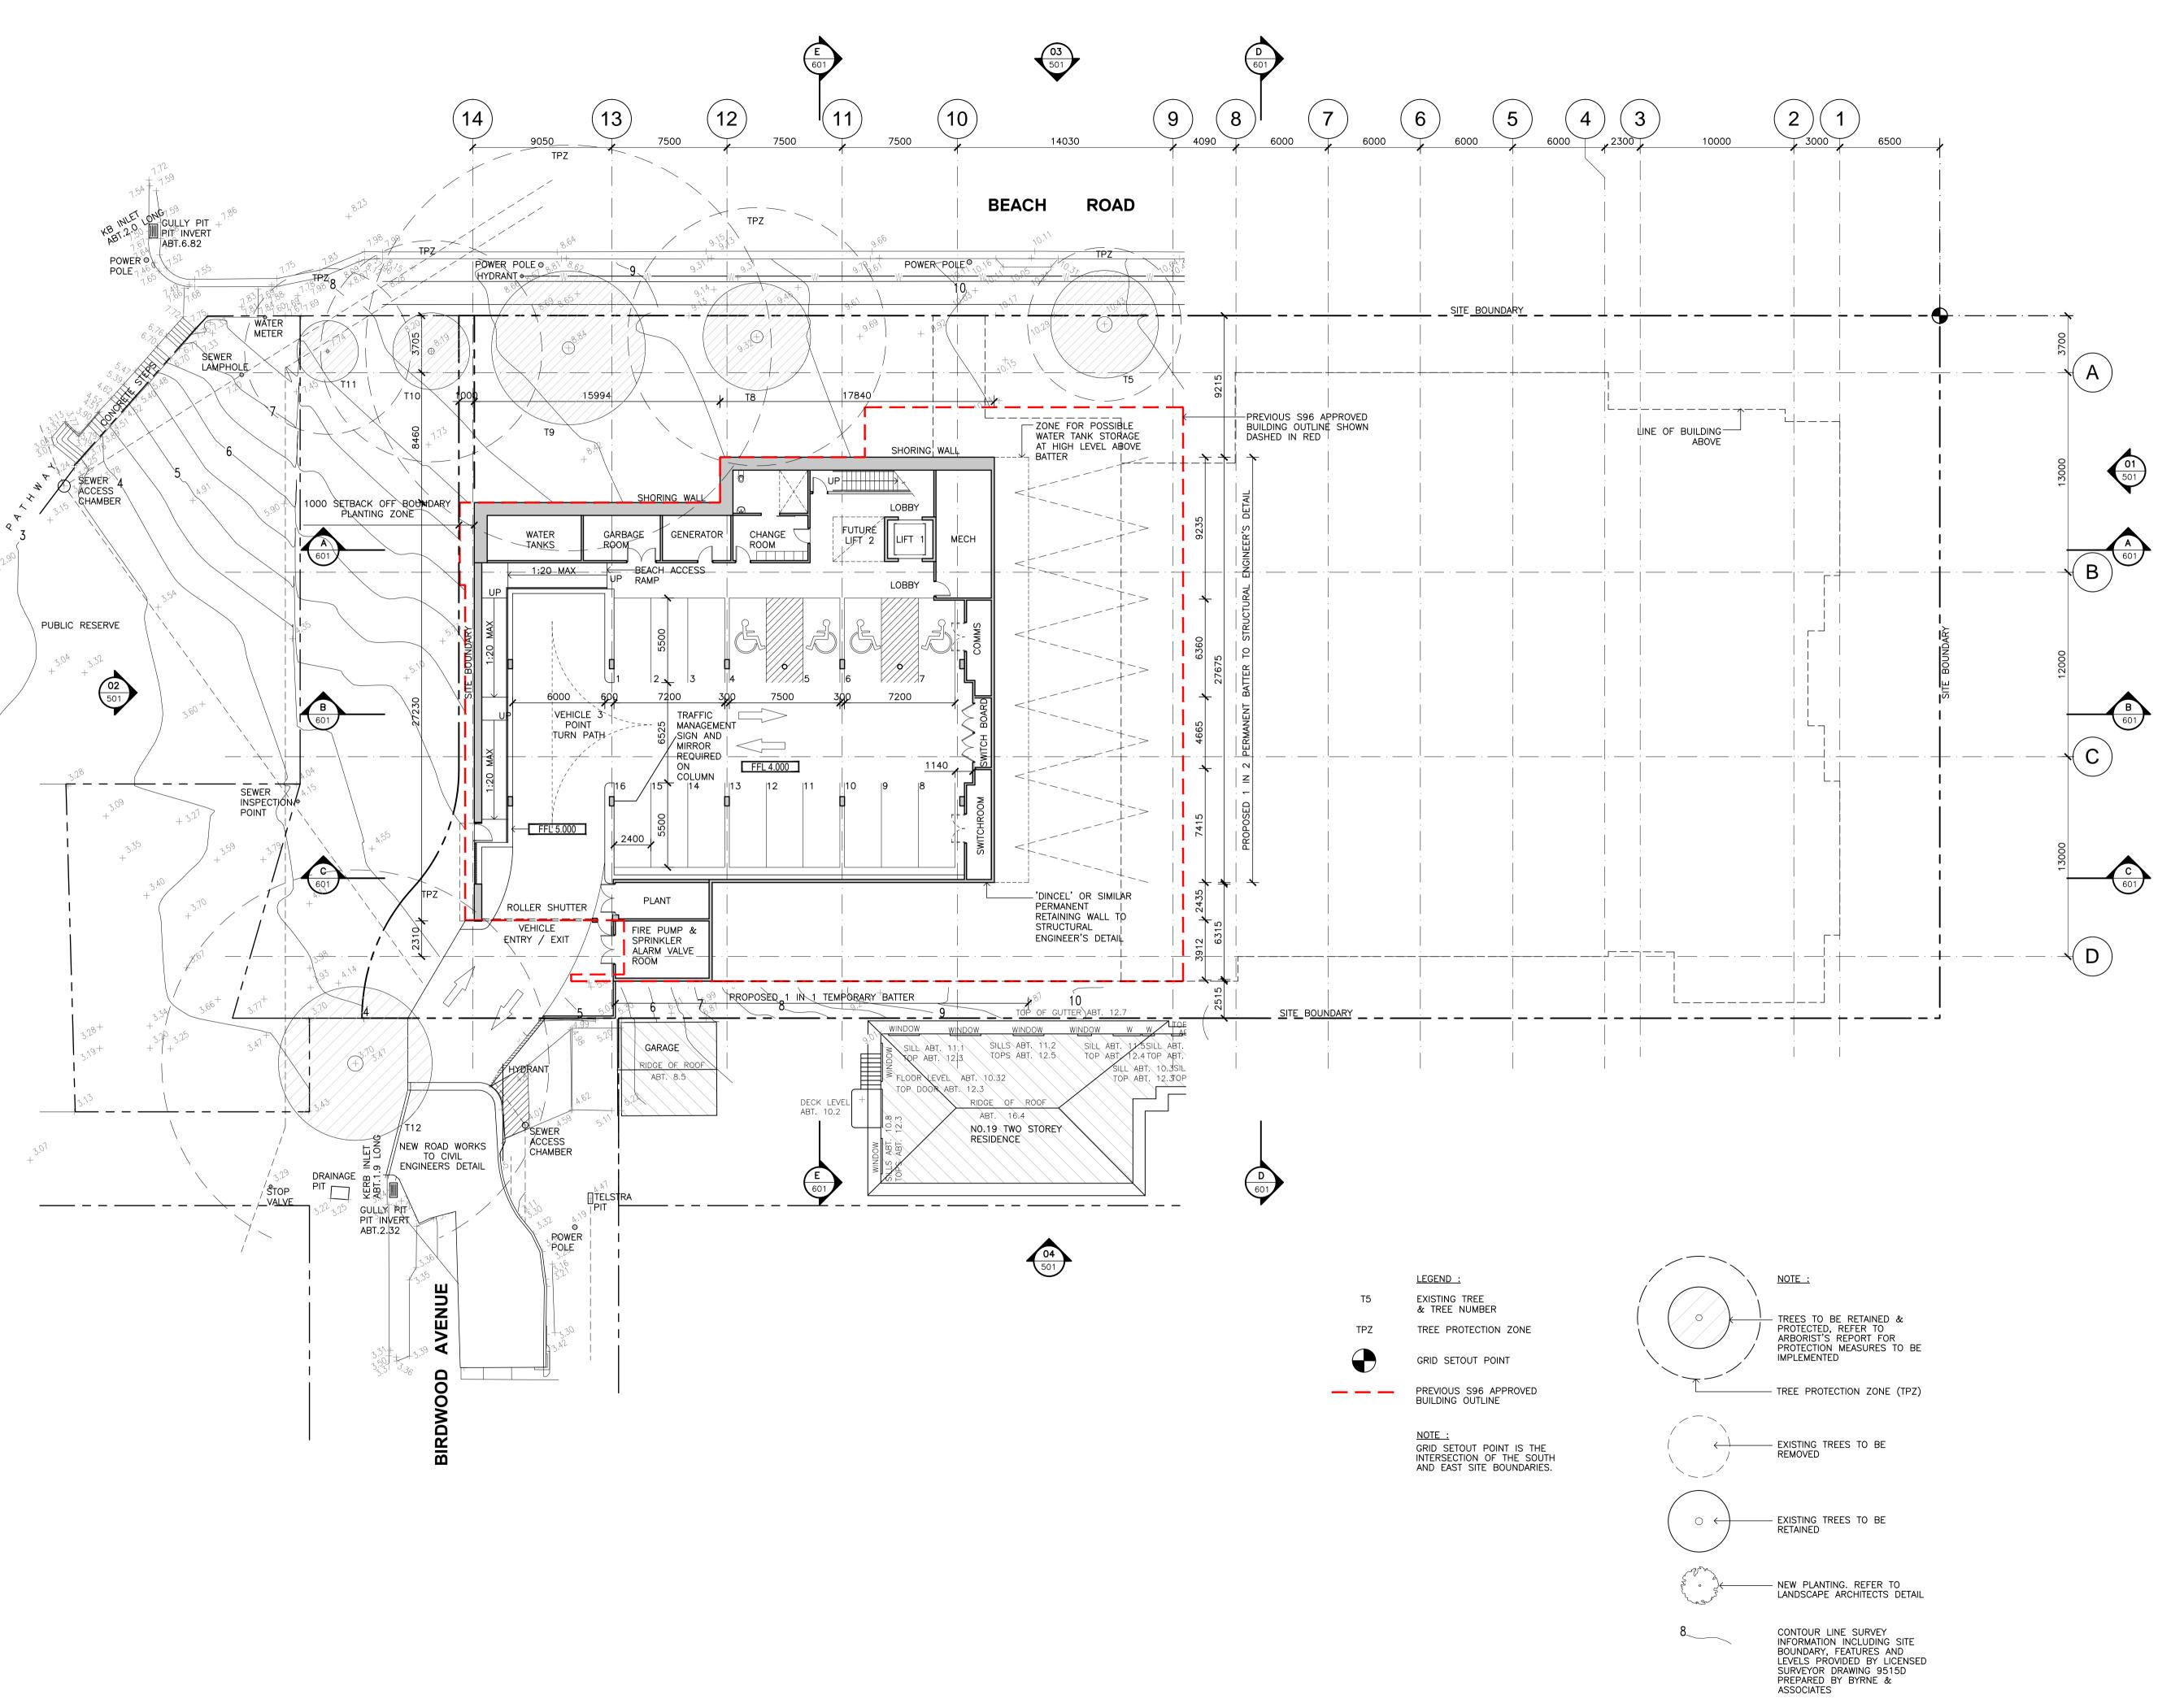

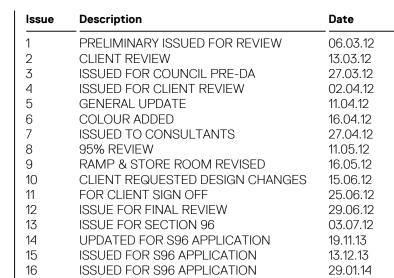

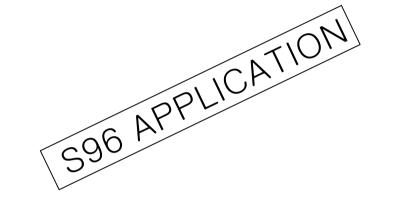



Client



Project


SARGOOD CENTRE 1 Brissenden Avenue Collaroy NSW 2097

Title


BASEMENT FLOOR PLAN

Drawing No. DA-100		Issue 16
Scale		Drawing Size
1:200		A1
Project No.	Date	Drawn By
1148	JULY 2012	RG

1148_SARGOOD/DWG FILES/PLOT

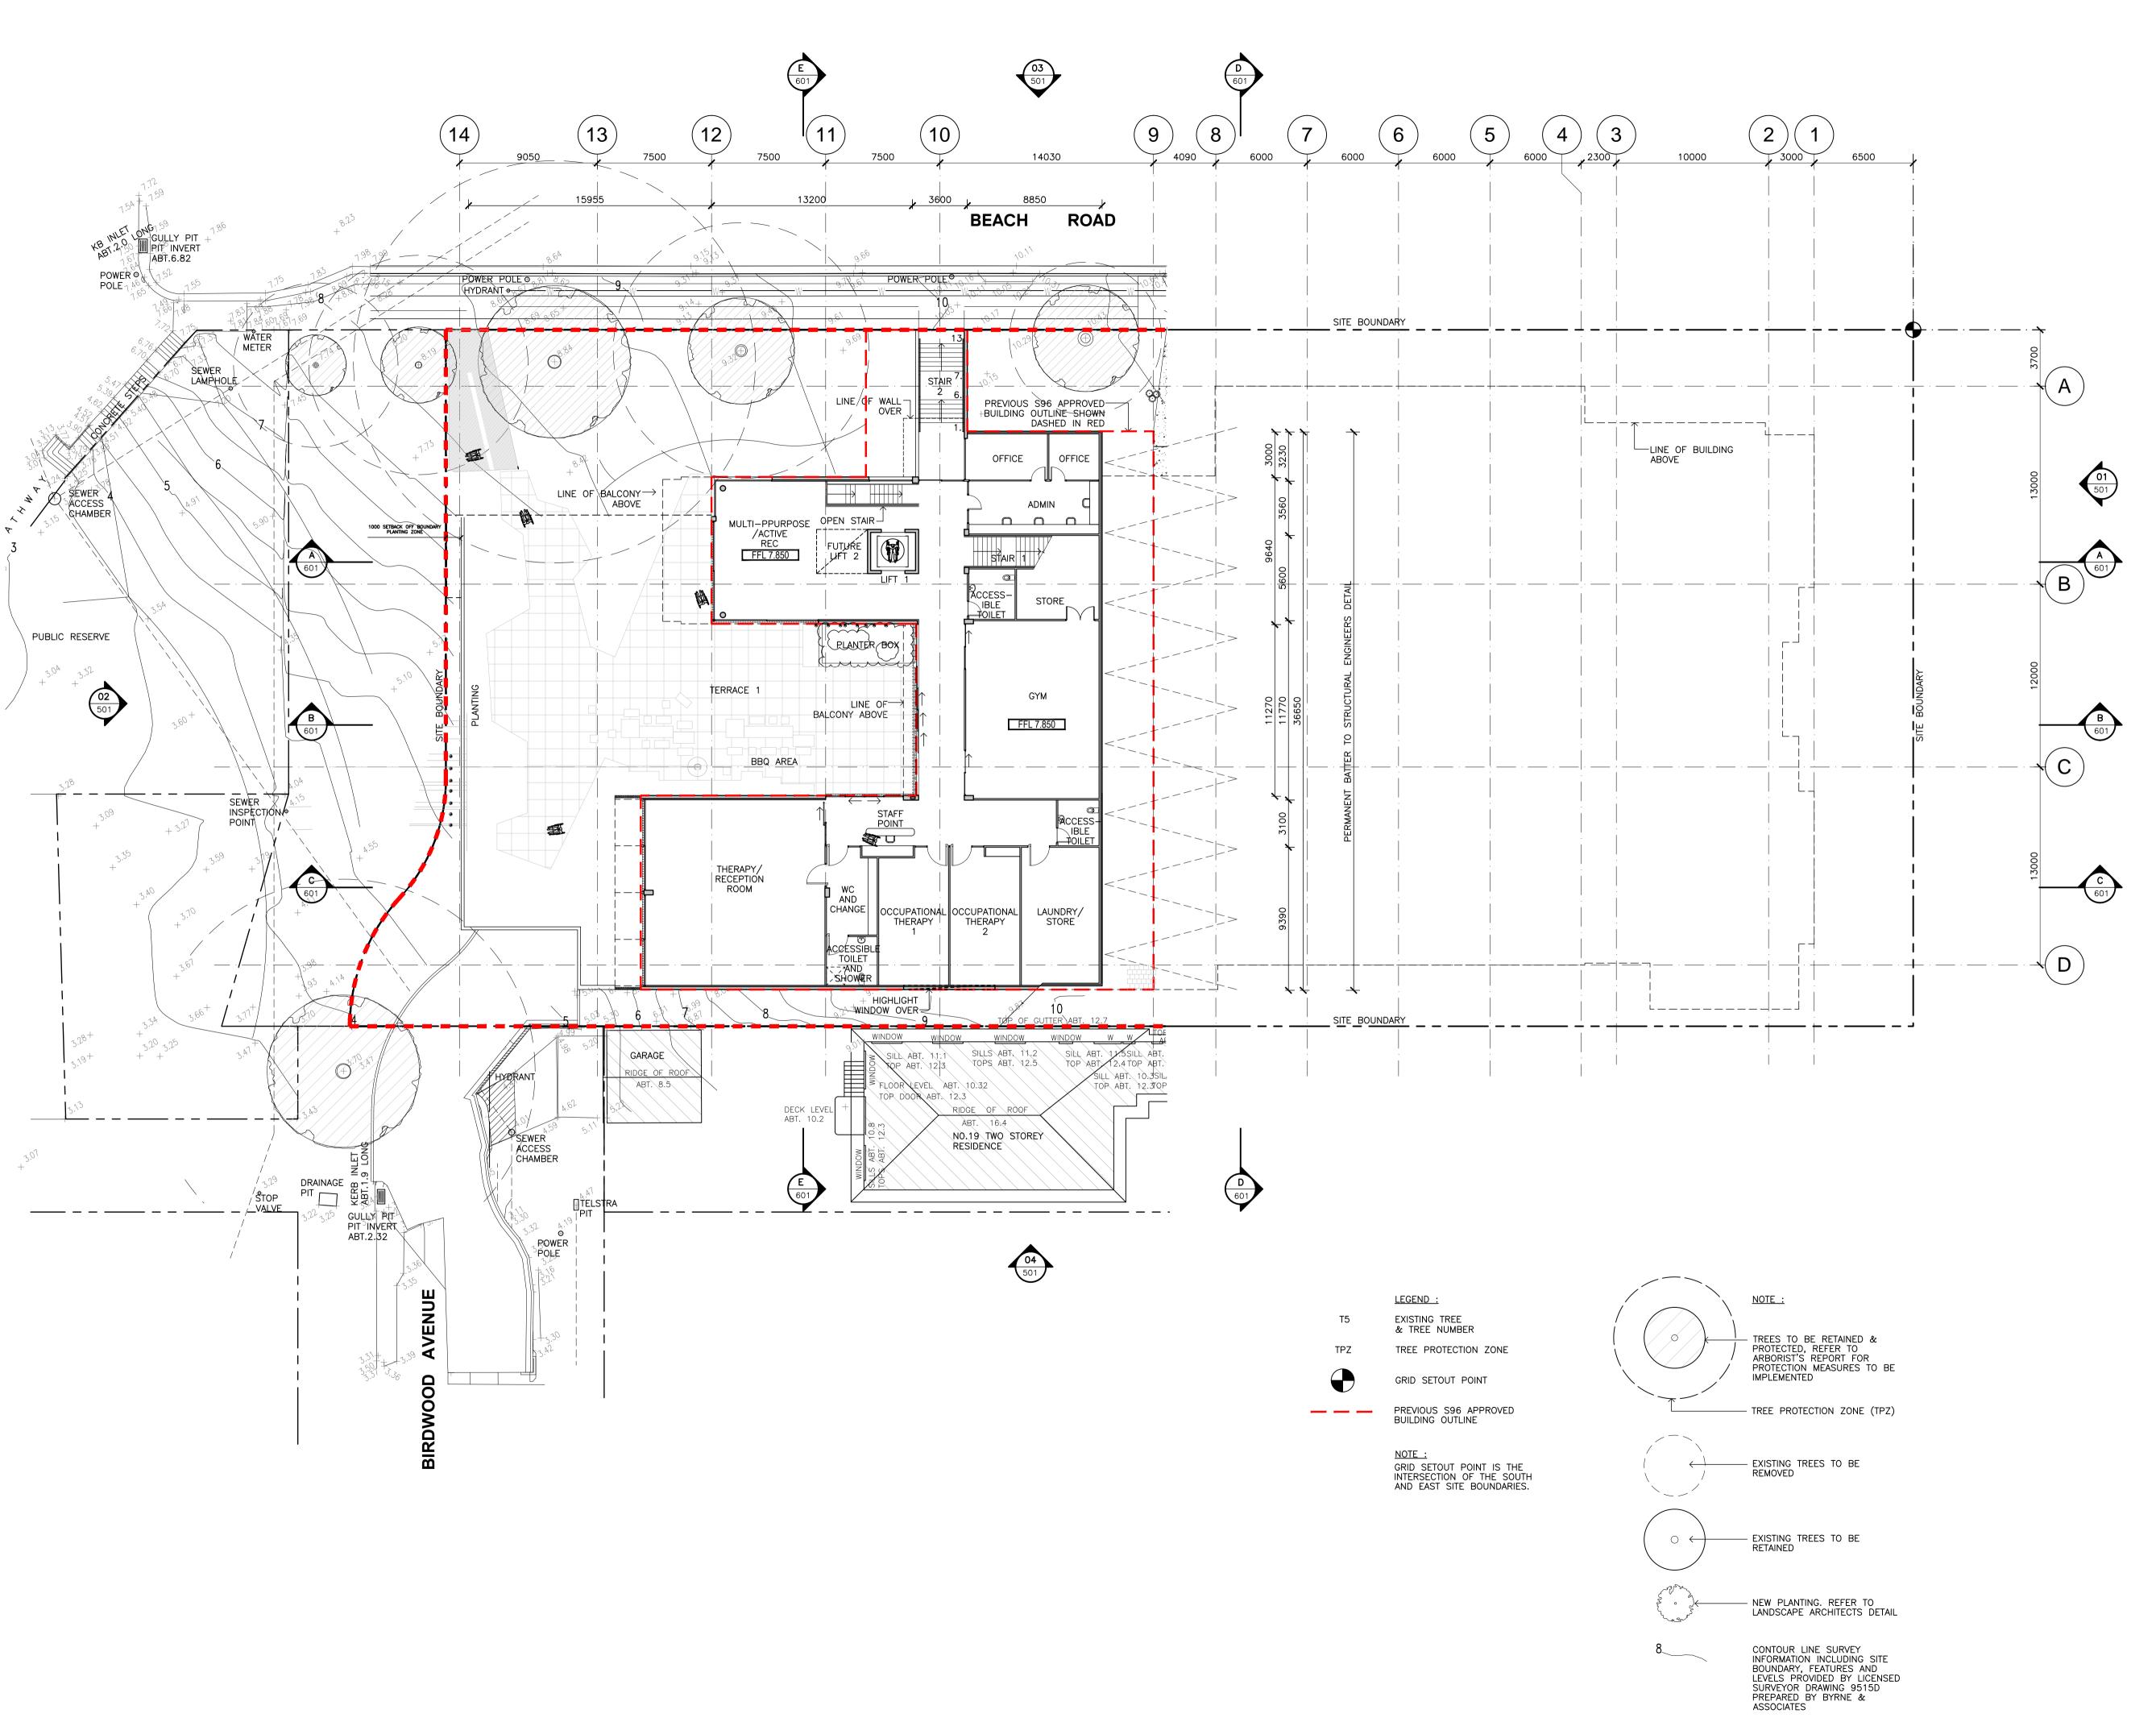

PRELIMINARY ISSUED FOR REVIEW CLIENT REVIEW 13.03.12 ISSUED FOR COUNCIL PRE-DA 27.03.12 ISSUED FOR CLIENT REVIEW 02.04.12 GENERAL UPDATE 11.04.12 16.04.12 27.04.12 27.04.12 21.05.12 COLOUR ADDED ISSUED TO CONSULTANTS 95% REVIEW REVISIONS AS CLOUDED CLIENT REQUESTED DESIGN CHANGES 18.06.12 FOR CLIENT SIGN OFF ISSUE FOR FINAL REVIEW 25.06.12 29.06.12 ISSUE FOR SECTION 96 03.07.12 UPDATED FOR S96 APPLICATION 19.07.12 ISSUED FOR S96 APPLICATION 13.12.12 ISSUED FOR S96 APPLICATION 29.01.13

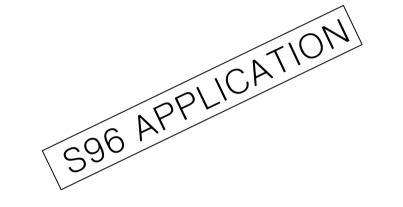



Client




Project


SARGOOD CENTRE 1 Brissenden Avenue Collaroy NSW 2097


LEVEL 1 FLOOR PLAN

Drawing No. DA-101		Issue 16
1:200		A1
Project No.	Date Date	Drawn By
1148	JULY 2012	RG

1148_SARGOOD/DWG FILES/PLOT

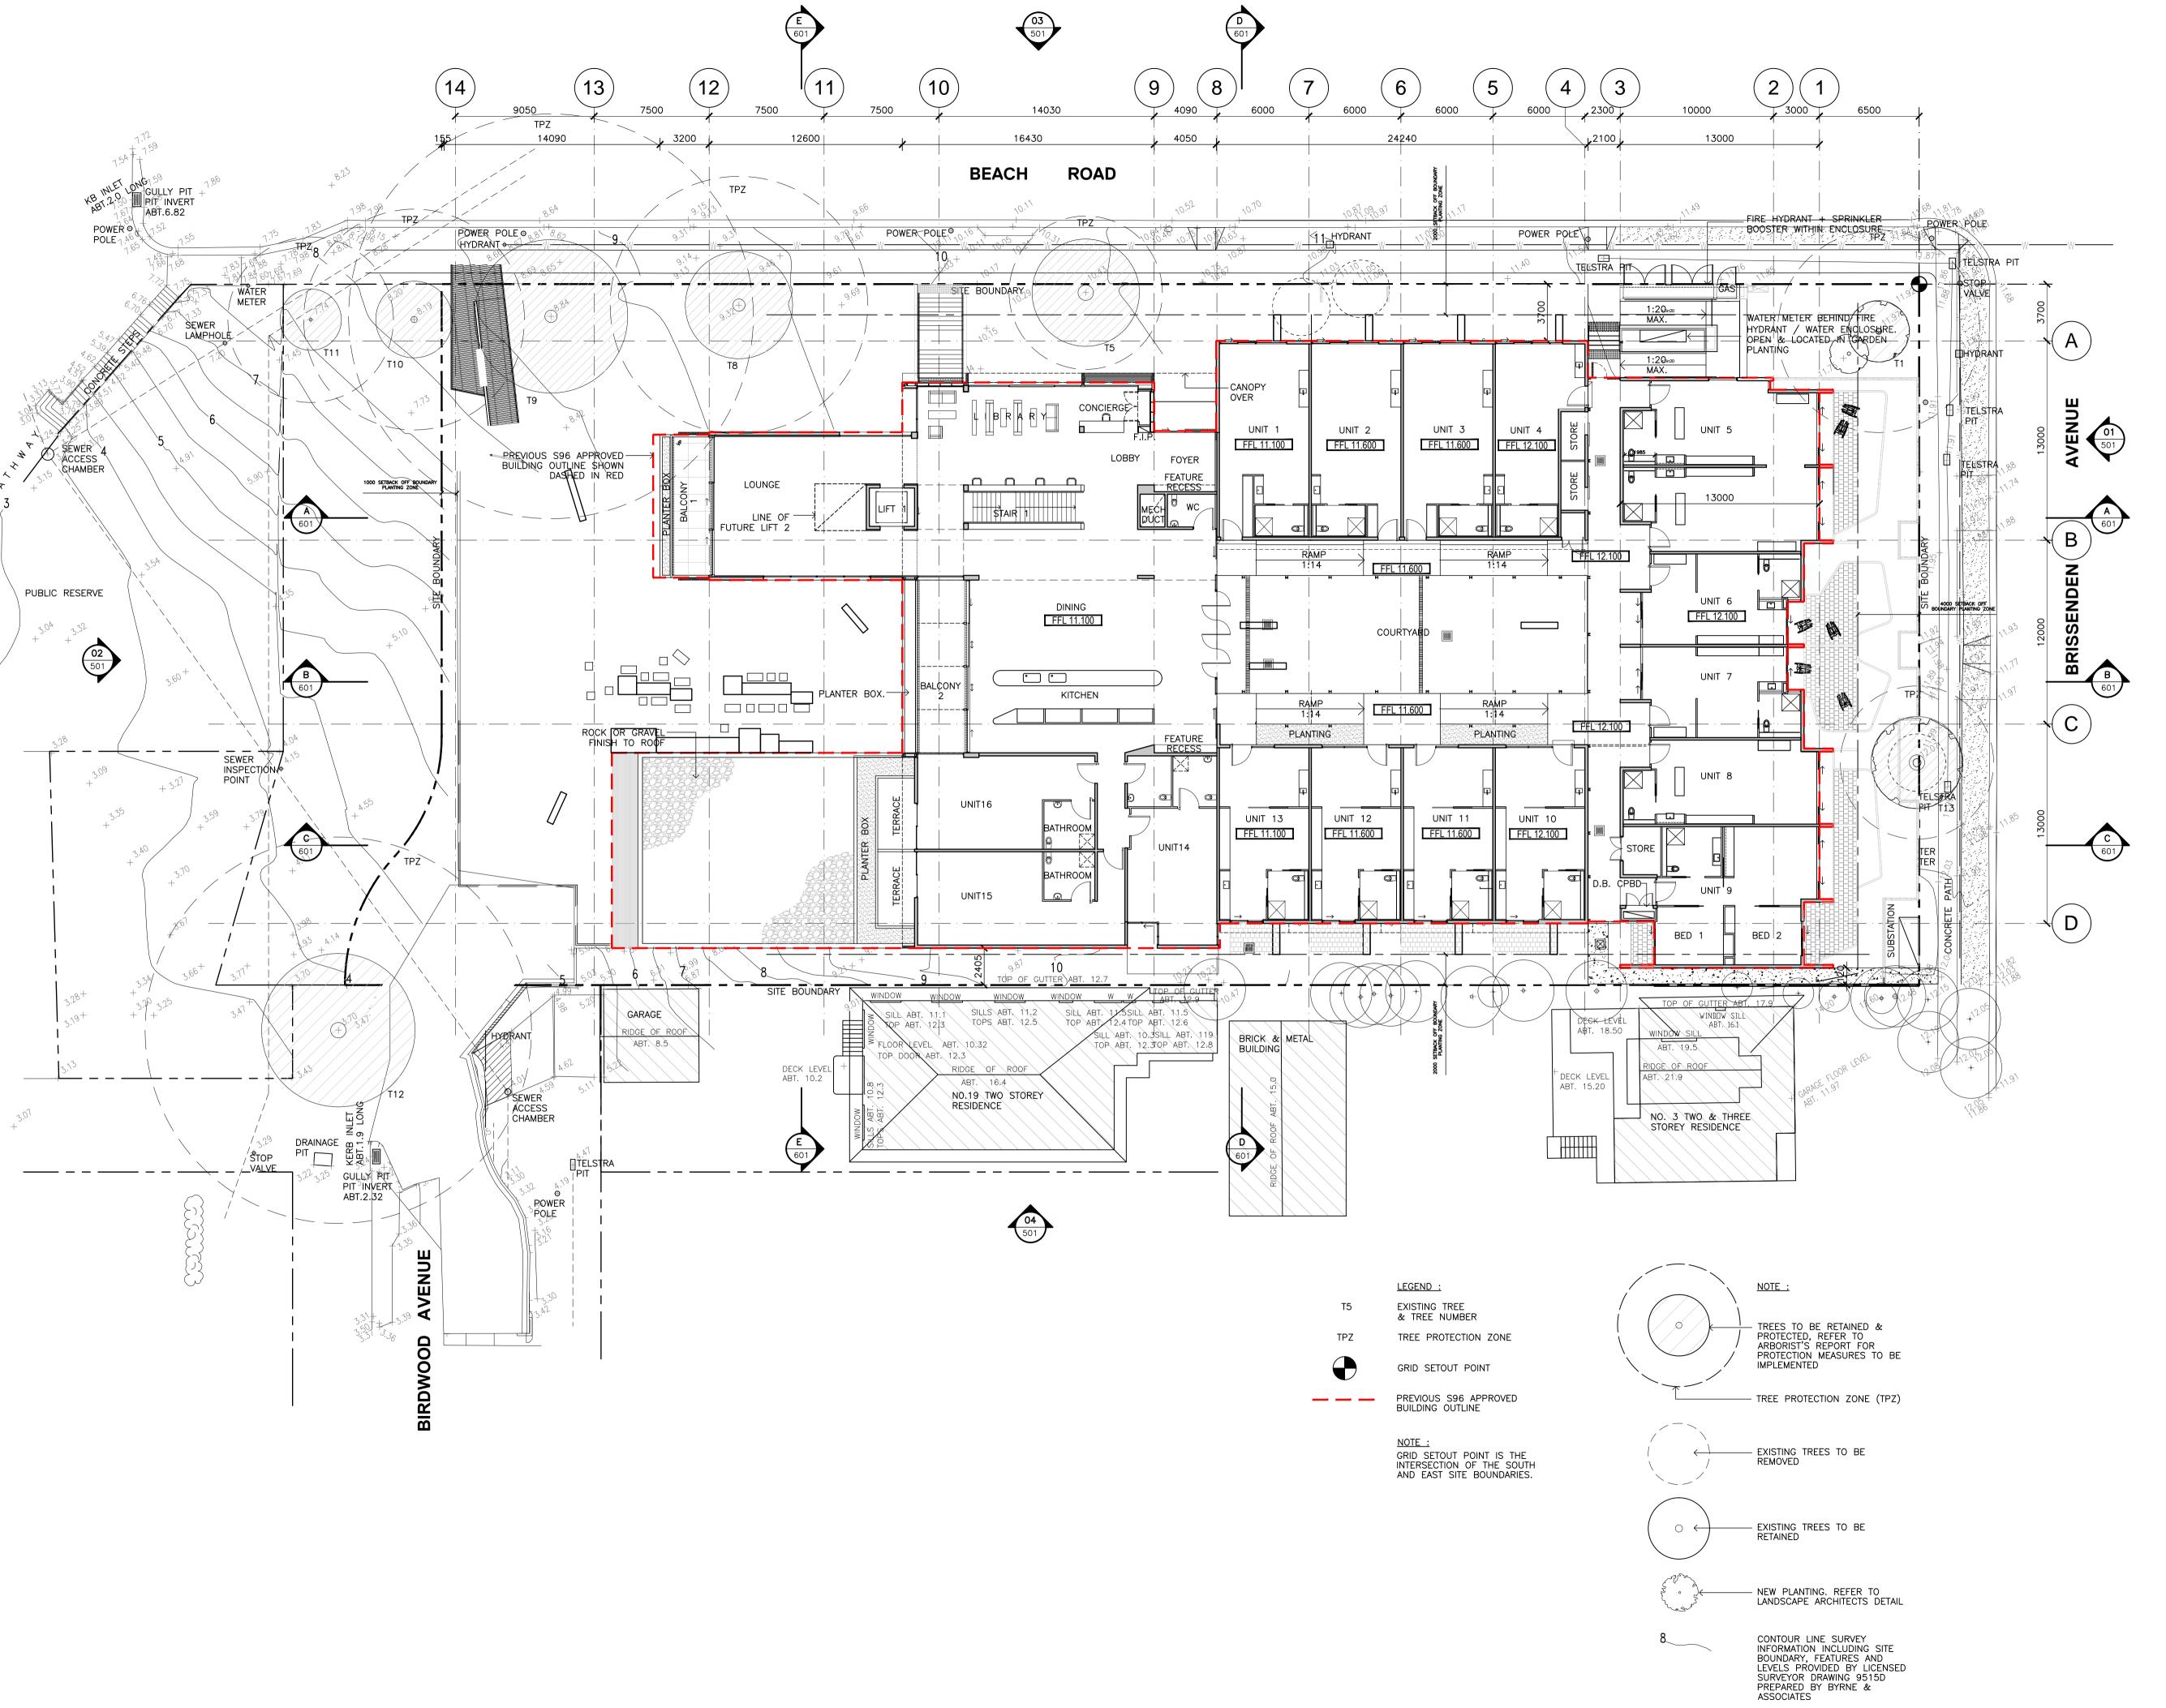

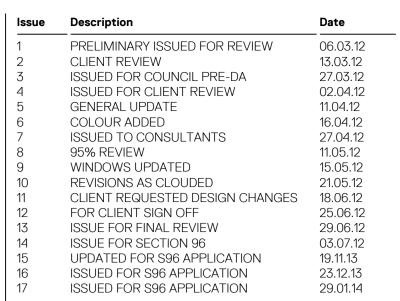

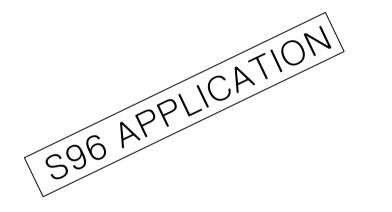





Project

Client

SARGOOD CENTRE 1 Brissenden Avenue Collaroy NSW 2097


LEVEL 2 FLOOR PLAN

Drawing No.		Issue
DA-102		17
Scale		Drawing Size
1:200		A1
Project No.	Date	Drawn By
1148	JULY 2012	RG

1148_SARGOOD/DWG FILES/PLOT

Dimensioned Drawings to take precedence over scaling. Contractor to verify all dimensions on site before construction. All inconsistencies to be reported to the Architect immediately.

This drawing and its contents remain the copyright of WMK Architecture Pty Ltd ©

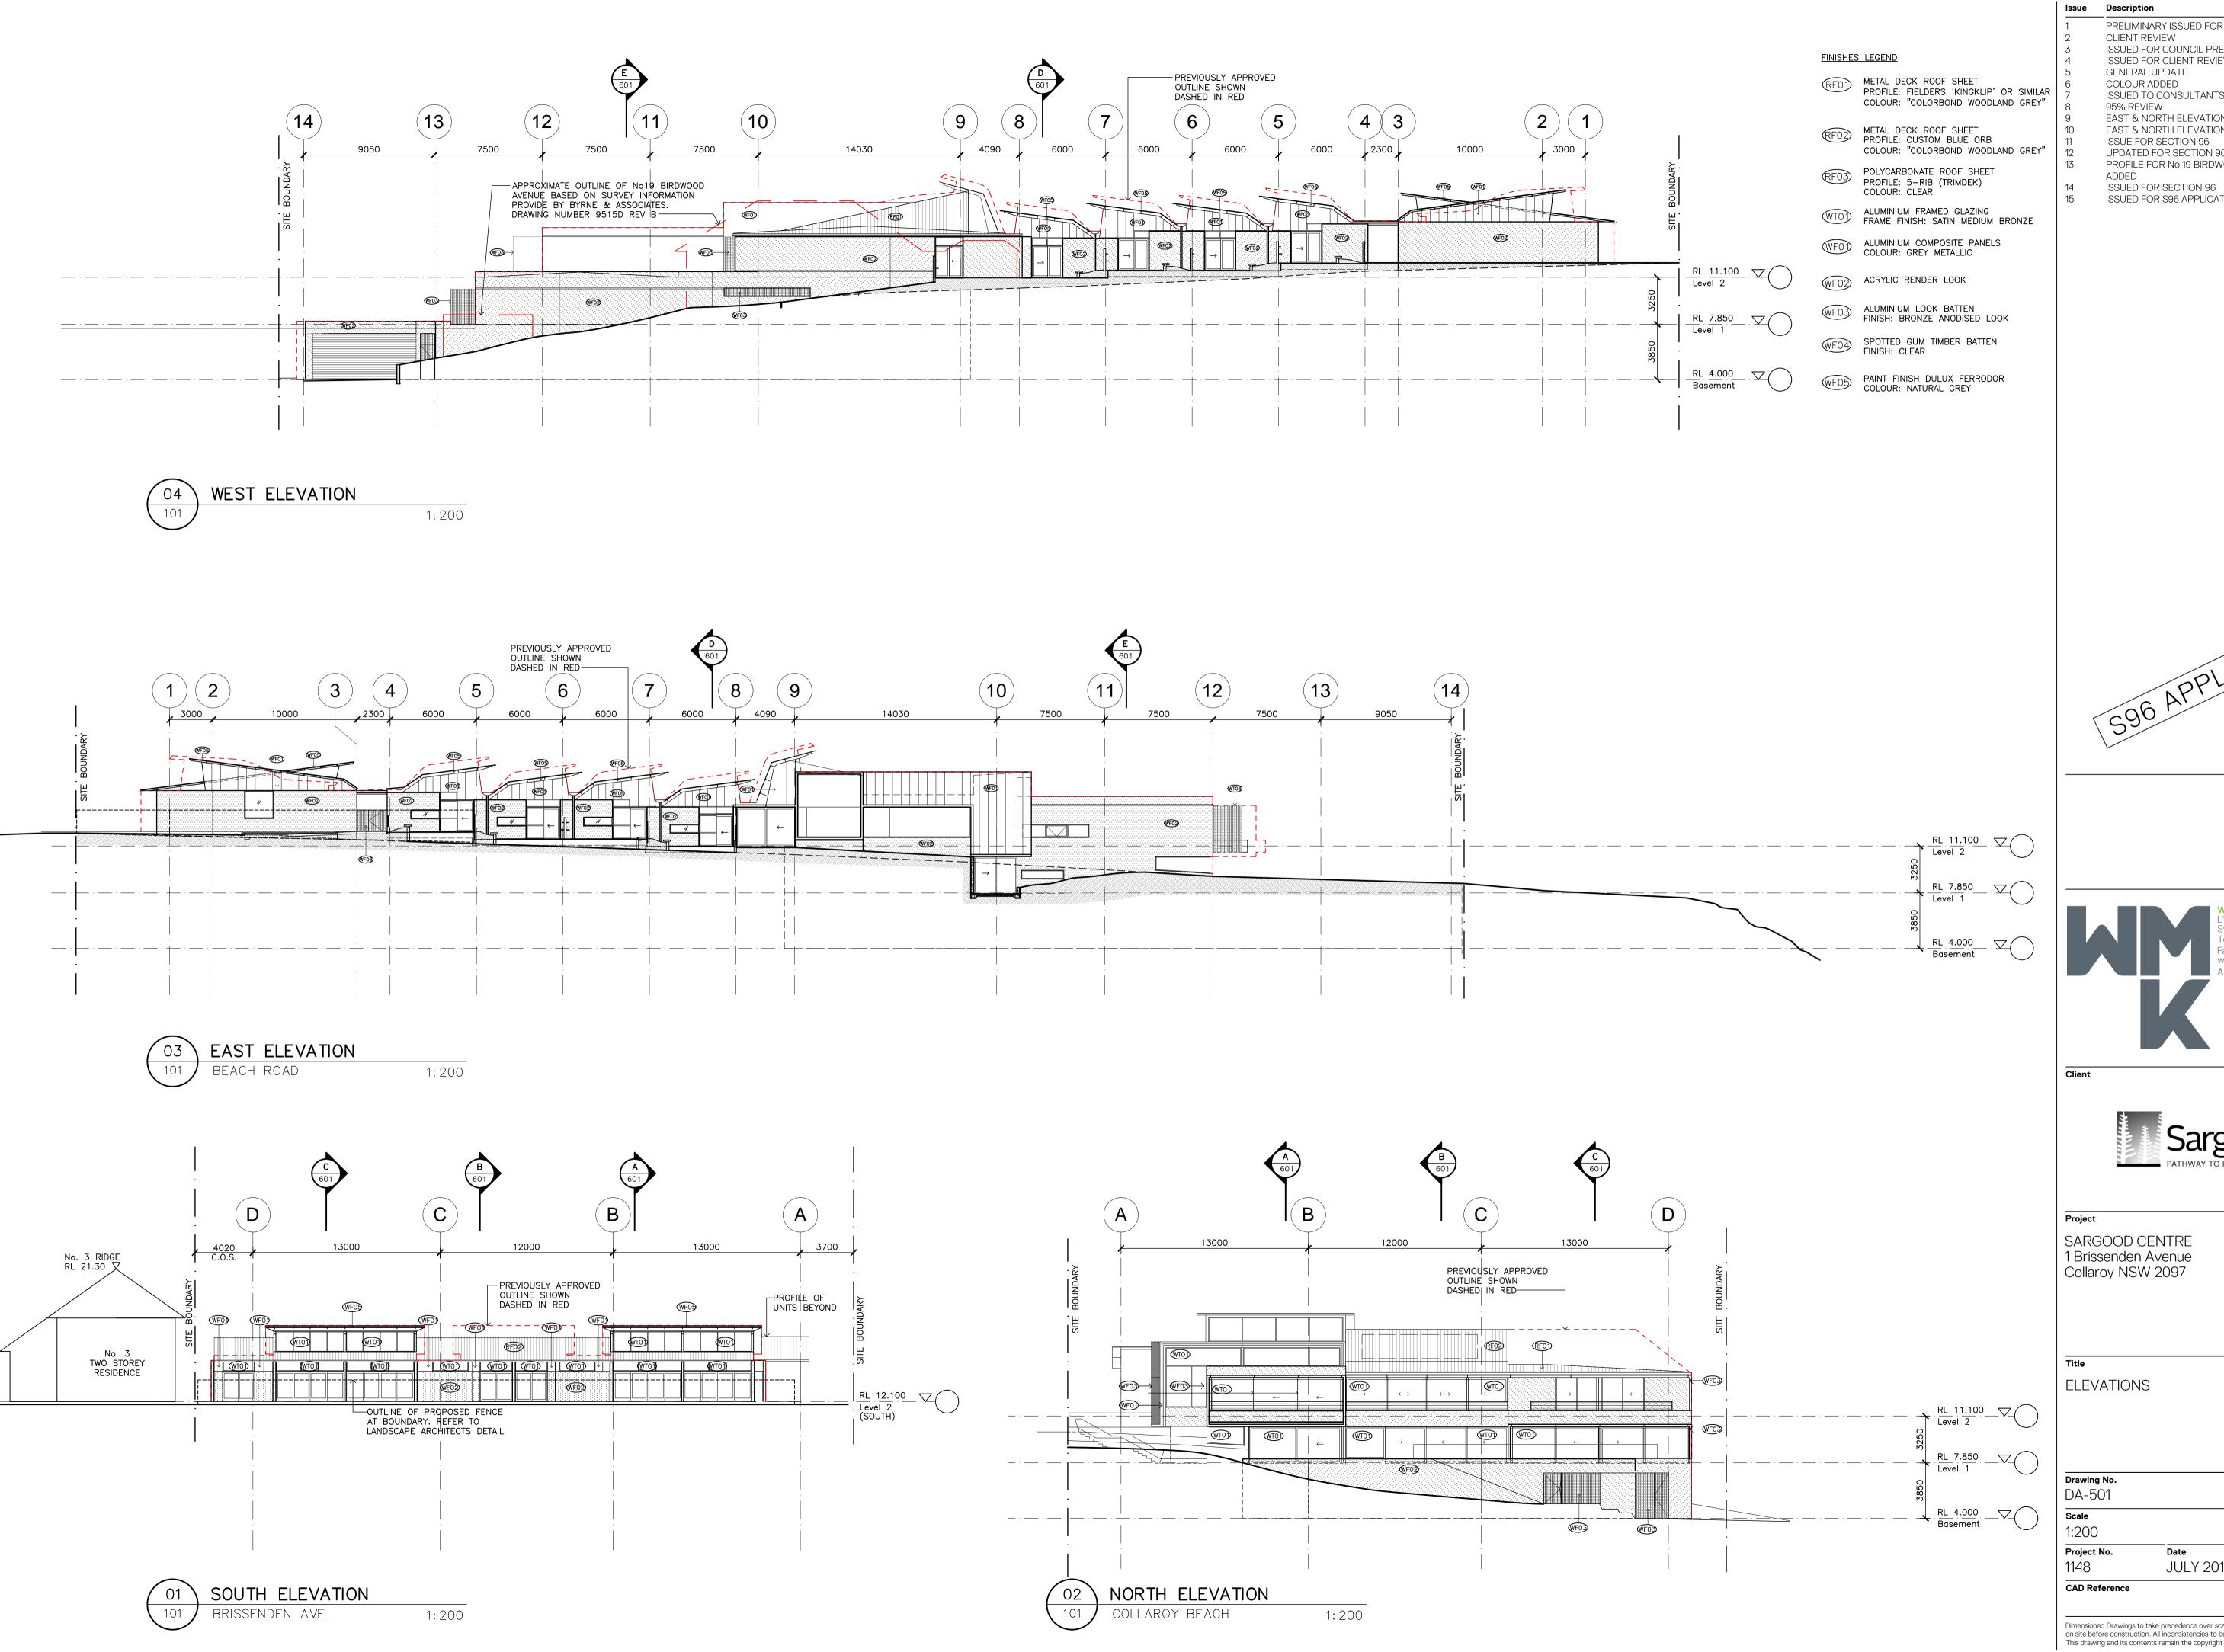

PRELIMINARY ISSUED FOR REVIEW 06.03.12 13.03.12 ISSUED FOR COUNCIL PRE-DA 27.03.12 ISSUED FOR CLIENT REVIEW 02.04.12 11.04.12 16.04.12 ISSUED TO CONSULTANTS 27.04.12 11.05.12 EAST & NORTH ELEVATION UPDATED 15.05.12 EAST & NORTH ELEVATION UPDATED 17.05.12 03.07.12 19.11.13 UPDATED FOR SECTION 96 PROFILE FOR No.19 BIRDWOOD AVE 10.12.13 13.12.13 ISSUED FOR S96 APPLICATION 29.01.14






15 **Drawing Size** Α1 Drawn By JULY 2012 KS


Dimensioned Drawings to take precedence over scaling. Contractor to verify all dimensions on site before construction. All inconsistencies to be reported to the Architect immediately.


This drawing and its contents remain the copyright of WMK Architecture Pty Ltd ©

Issue

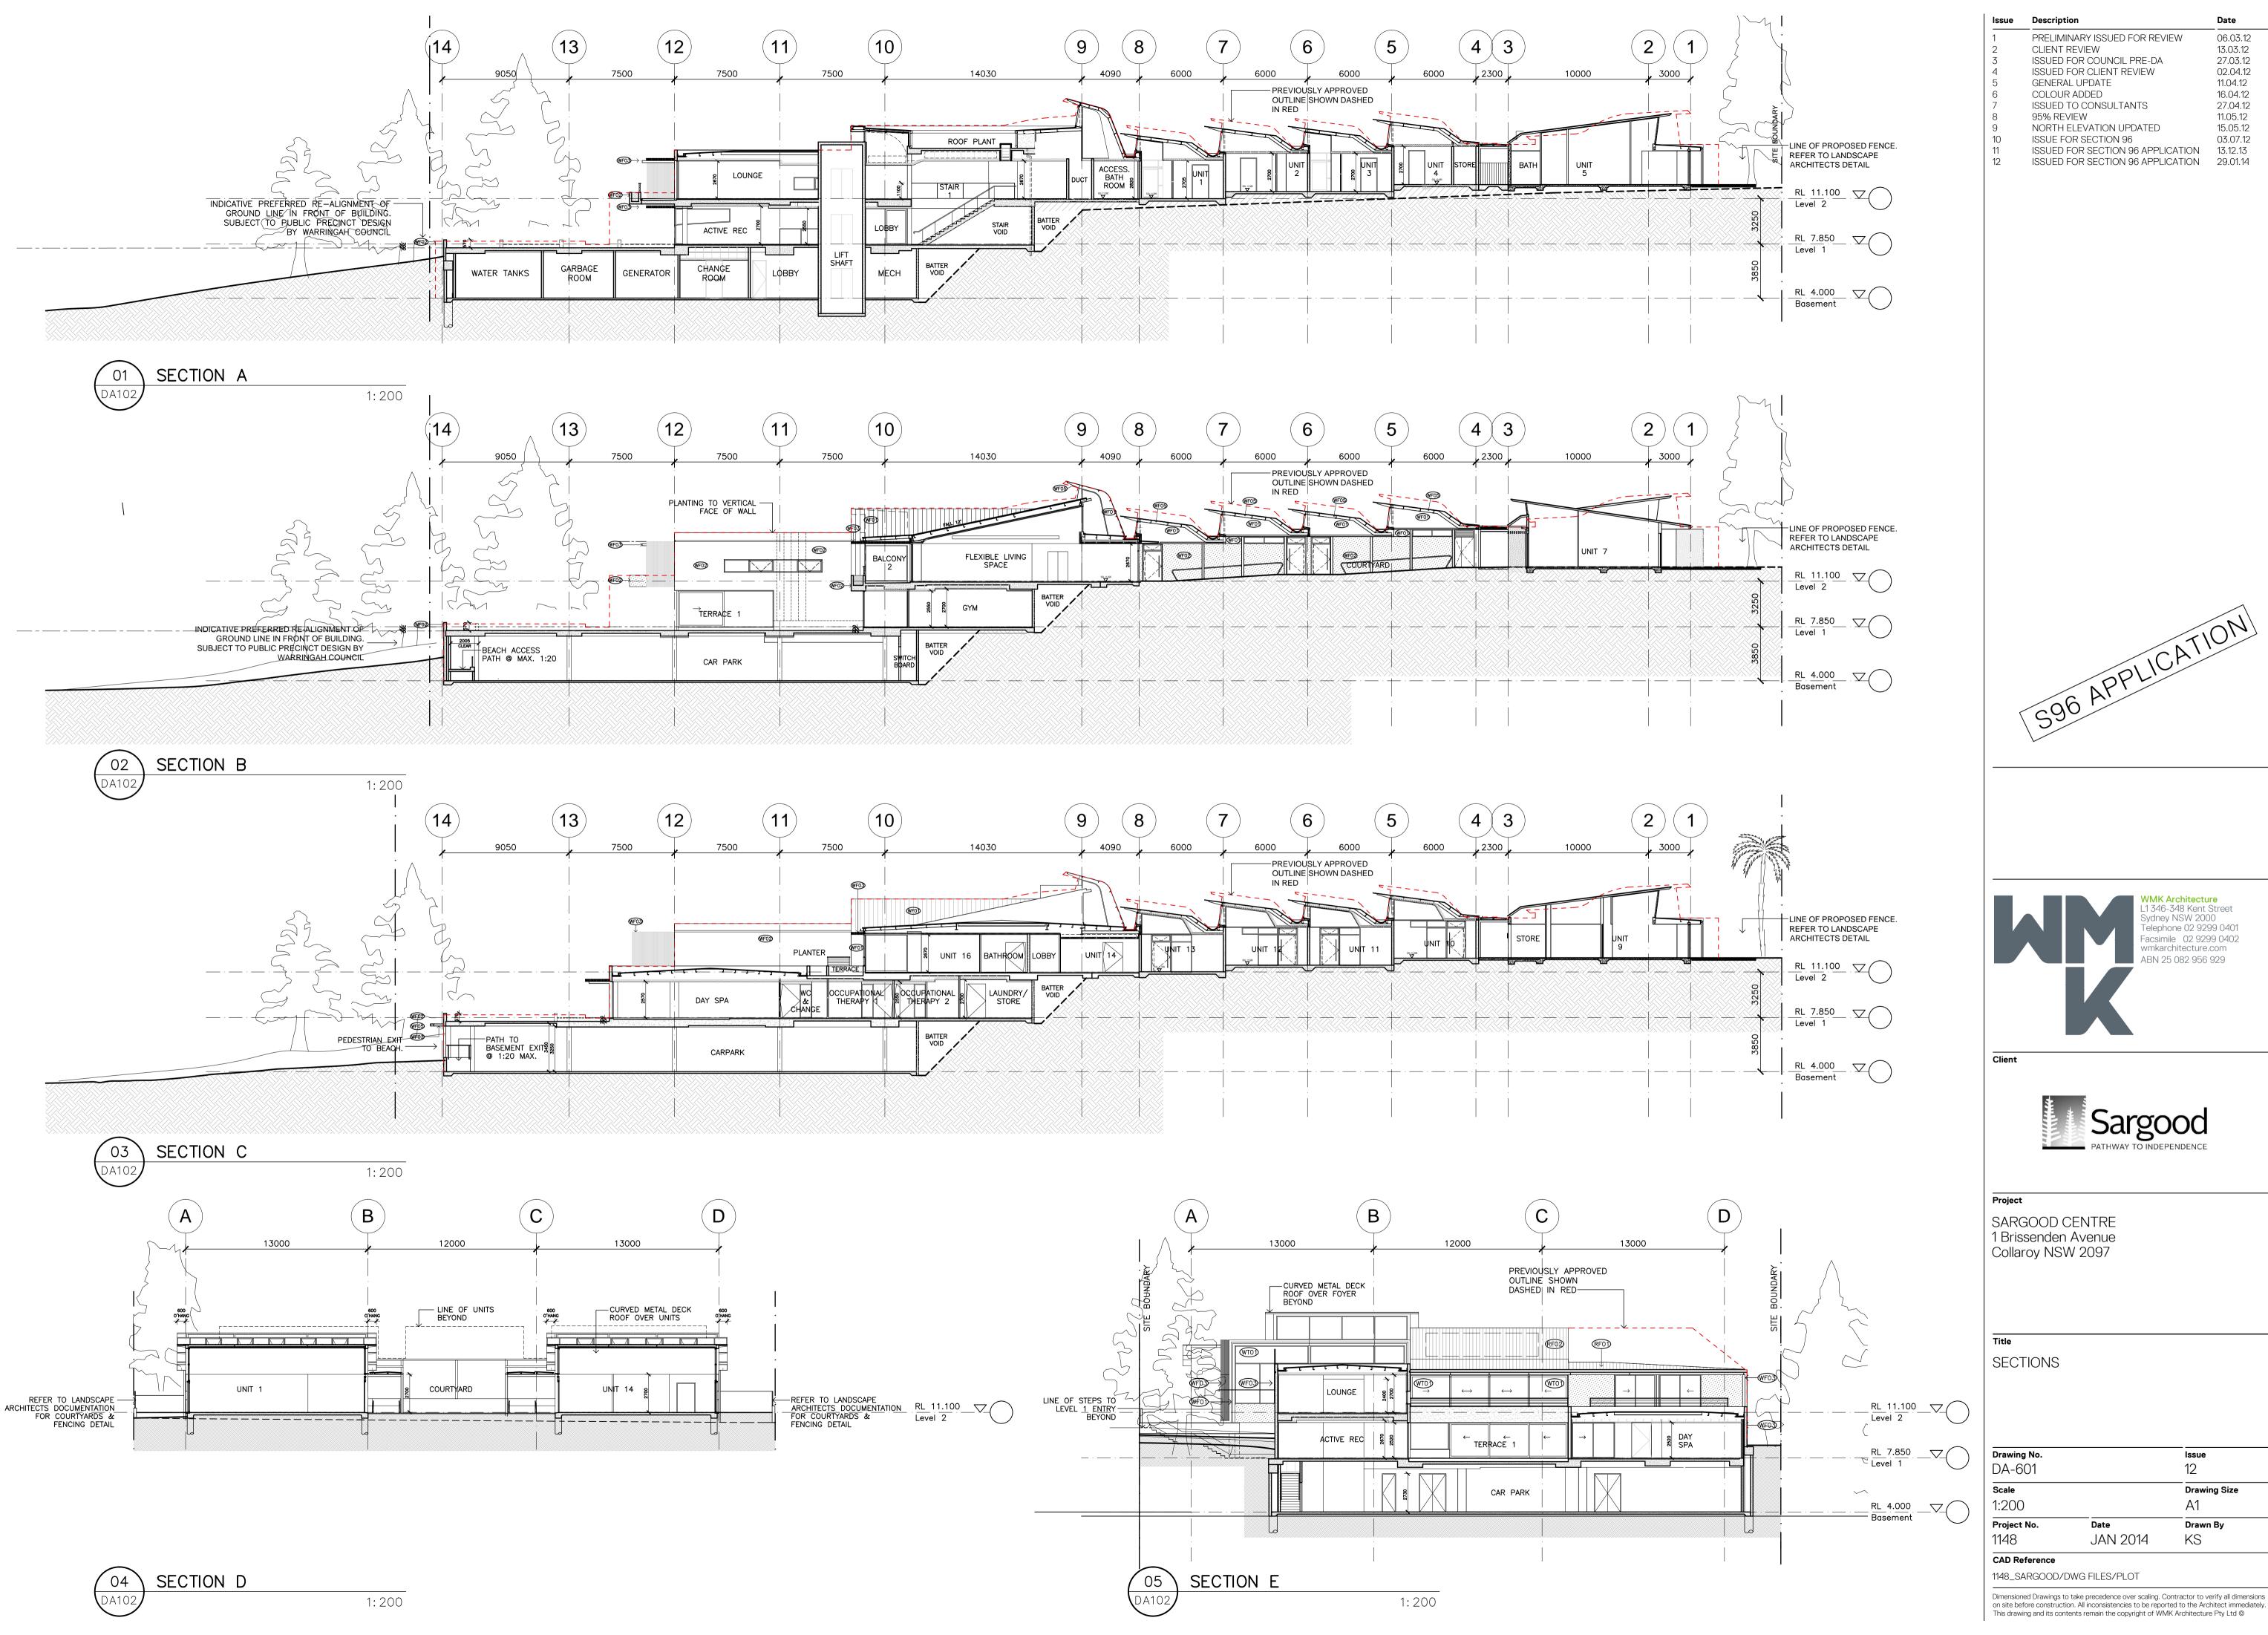


on site before construction. All inconsistencies to be reported to the Architect immediately.

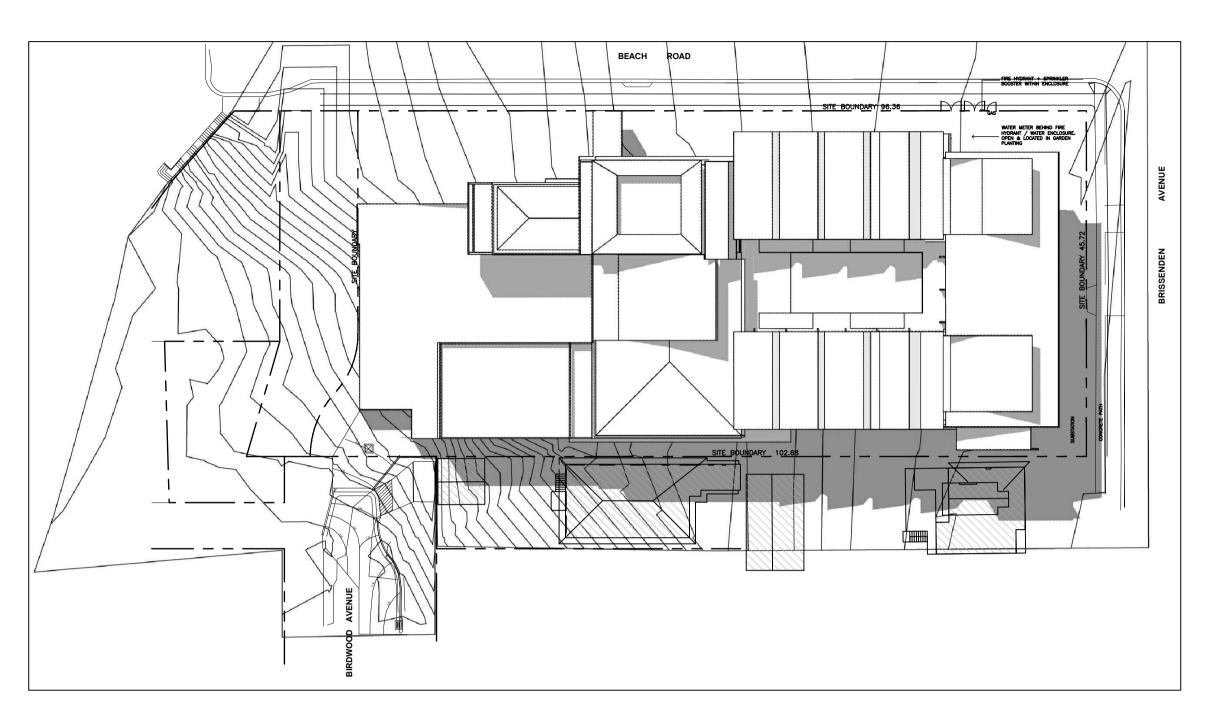

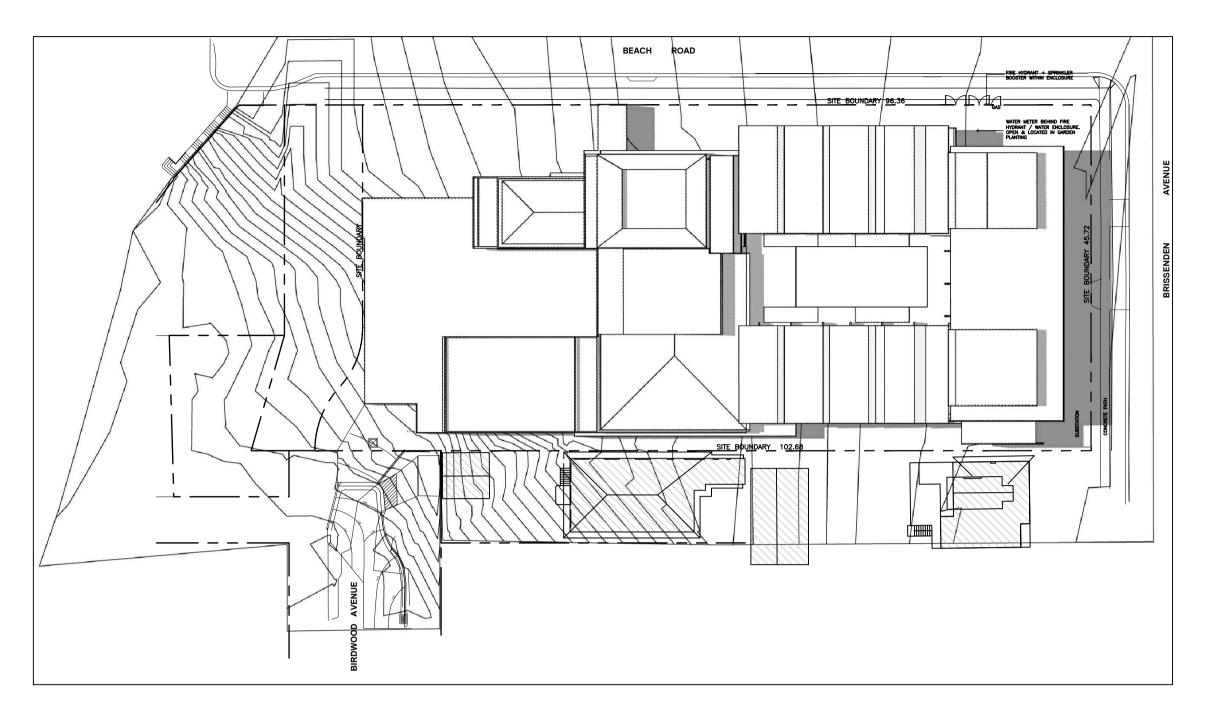

EQUINOX 9.00 AM 1:500

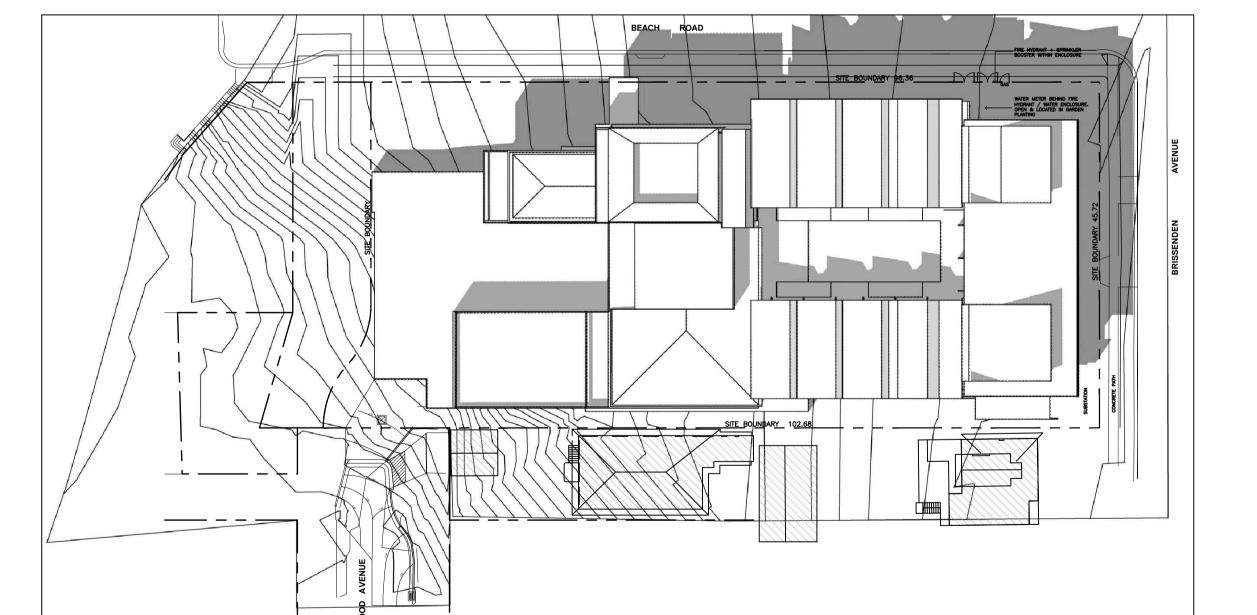

EQUINOX 3.00 PM 1:500 EQUINOX 12.00 PM 1:500

ISSUE FOR SECTION 96

ISSUED FOR SECTION 96 APPLICATION 11.12.13
ISSUED FOR SECTION 96 APPLICATION 29.01.14







SARGOOD CENTRE 1 Brissenden Avenue Collaroy NSW 2097


SHADOW DIAGRAMS AUTUMN EQUINOX


Drawing No.		Issue
DA-901		3
Scale		Drawing Size
1:500		A1
Project No.	Date	Drawn By
1148	JAN 2014	RG

 1148_SARGOOD/DWG FILES/PLOT

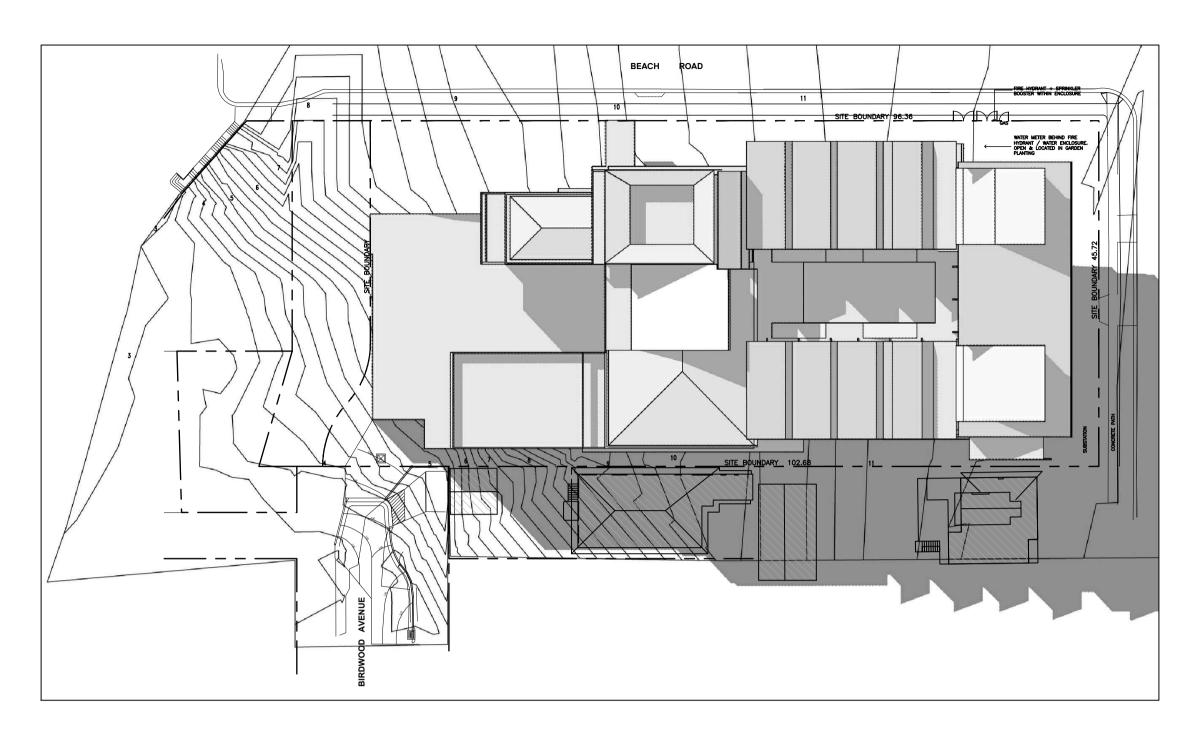

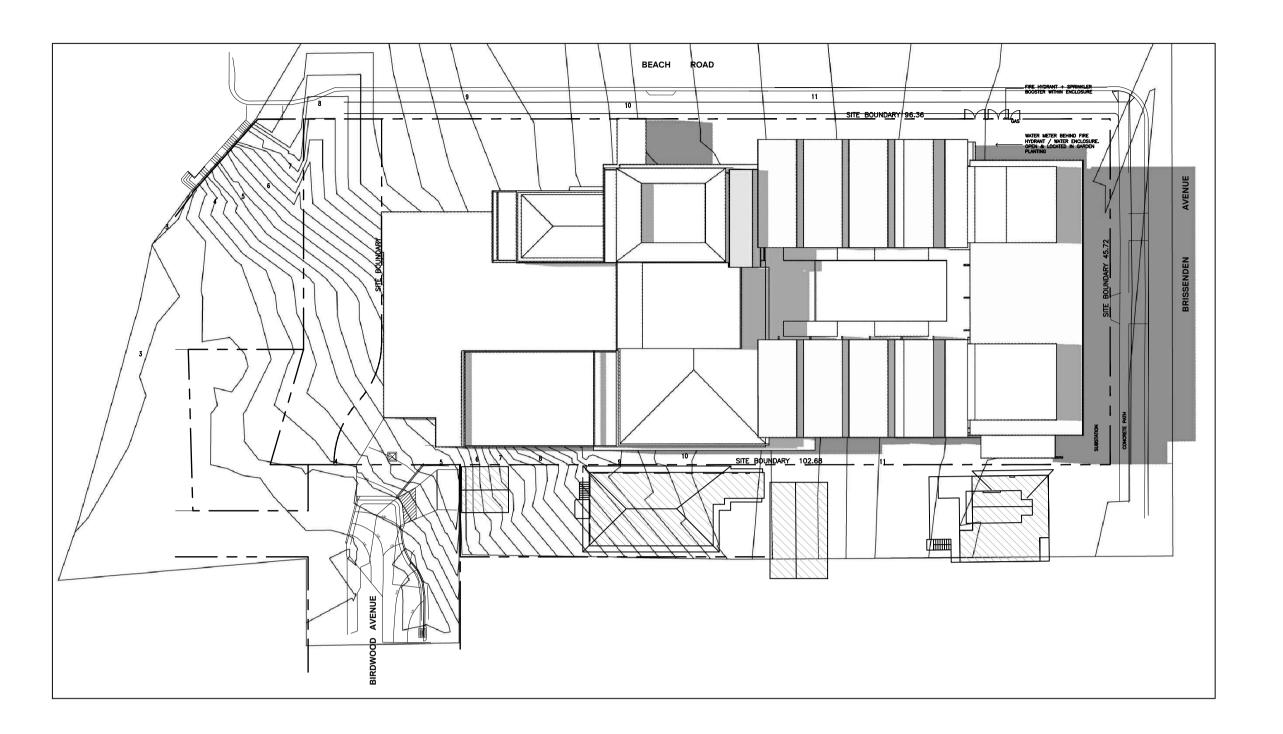



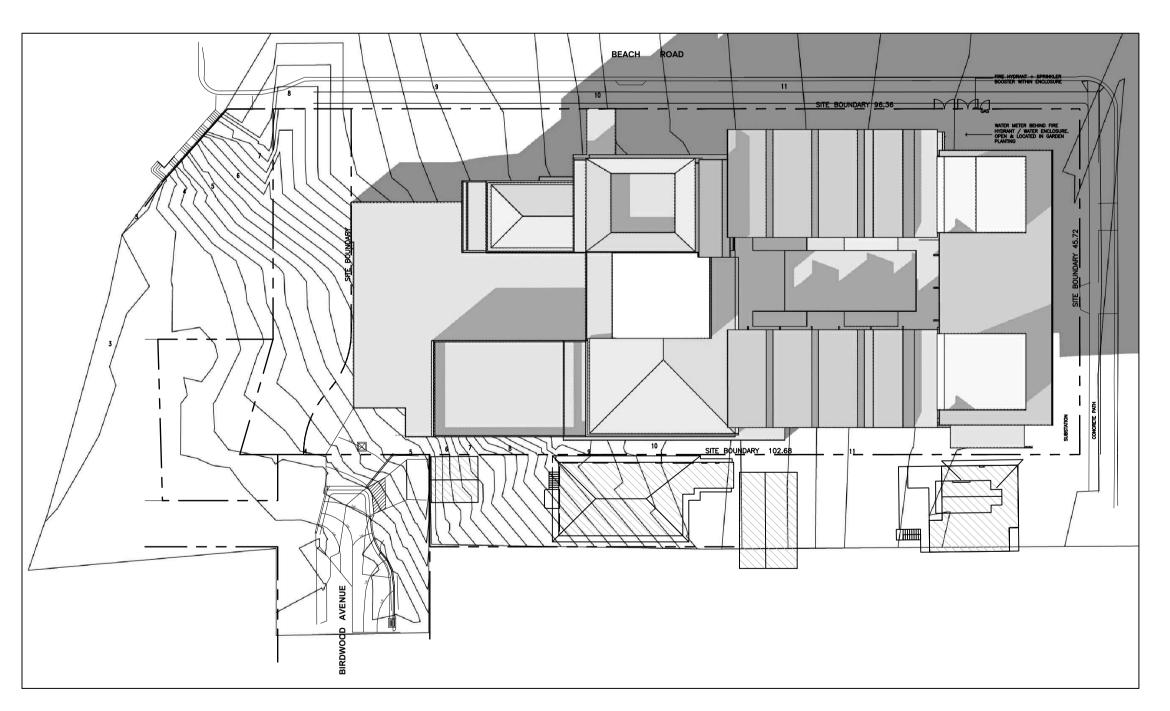

21 JUNE 3.00 PM 1:500 21 JUNE 12.00 PM 1: 500

ISSUE FOR SECTION 96

ISSUED FOR SECTION 96 APPLICATION 00.12.13
ISSUED FOR SECTION 96 APPLICATION 29.01.14







SARGOOD CENTRE 1 Brissenden Avenue Collaroy NSW 2097

SHADOW DIAGRAMS WINTER SOLSTICE

Drawing No.		Issue
DA-902		3
Scale		Drawing Size
1:500		A1
Project No.	Date	Drawn By
1148	JULY 2012	RG

1148_SARGOOD/DWG FILES/PLOT

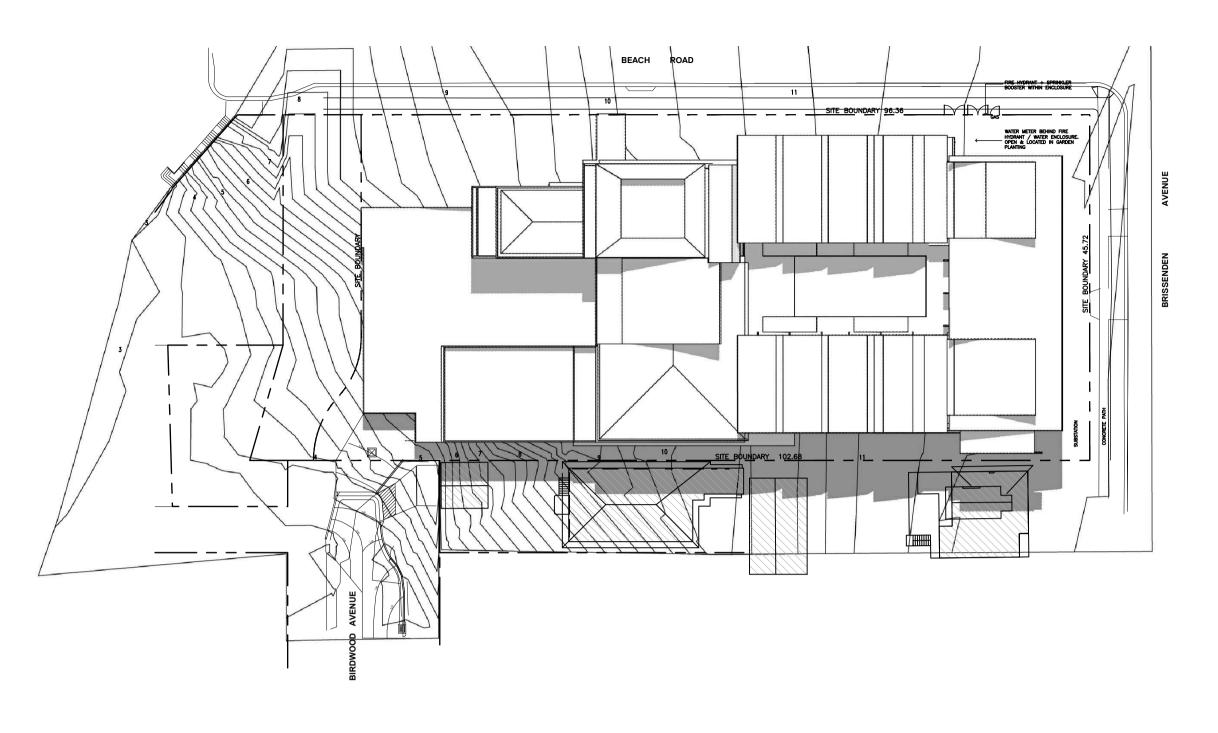


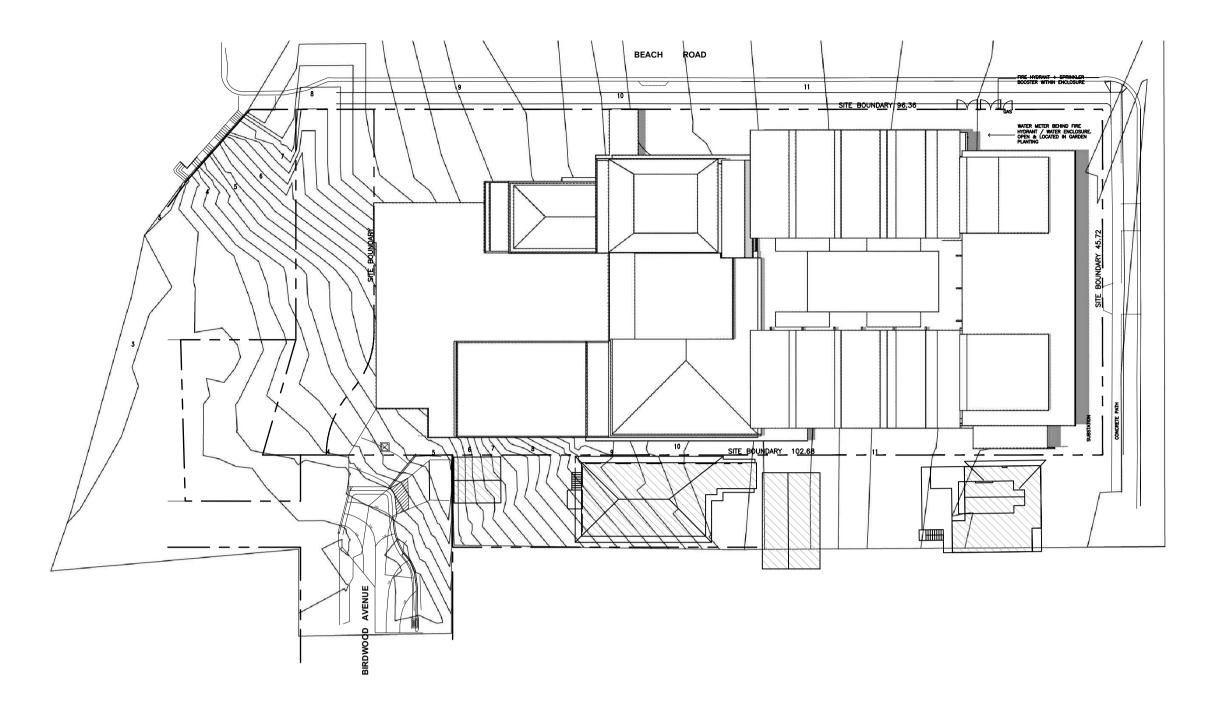

01 22 DECEMBER 9.00 AM
1:500



22 DECEMBER 12.00 PM1:500

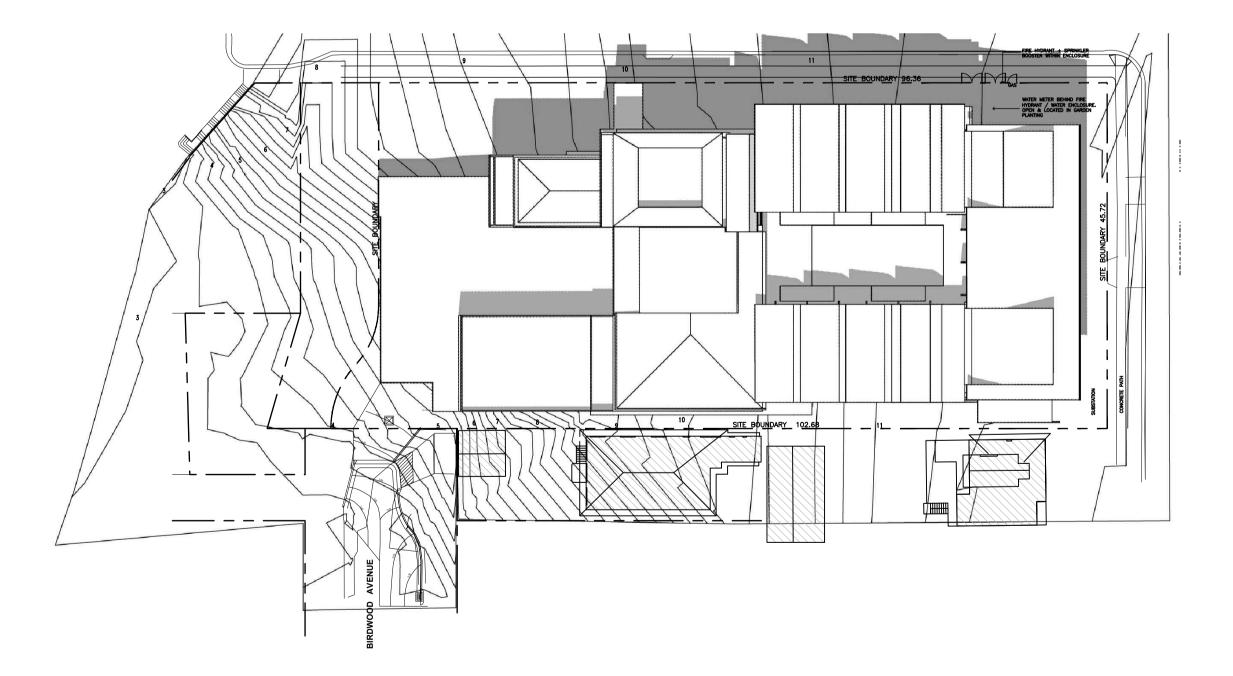





ISSUE FOR SECTION 96 03.07.12
ISSUE FOR SECTION 96 APPLICATION 00.12.13
ISSUE FOR SECTION 96 APPLICATION 29.01.14

Client



Project

SARGOOD CENTRE 1 Brissenden Avenue Collaroy NSW 2097


Title

SHADOW DIAGRAMS SUMMER SOLSTICE

Drawing No.		Issue
DA-903		3
Scale		Drawing Size
1:500		A1
Project No.	Date	Drawn By
1148	JAN 2014	RG

CAD Reference

1148_SARGOOD/DWG FILES/PLOT

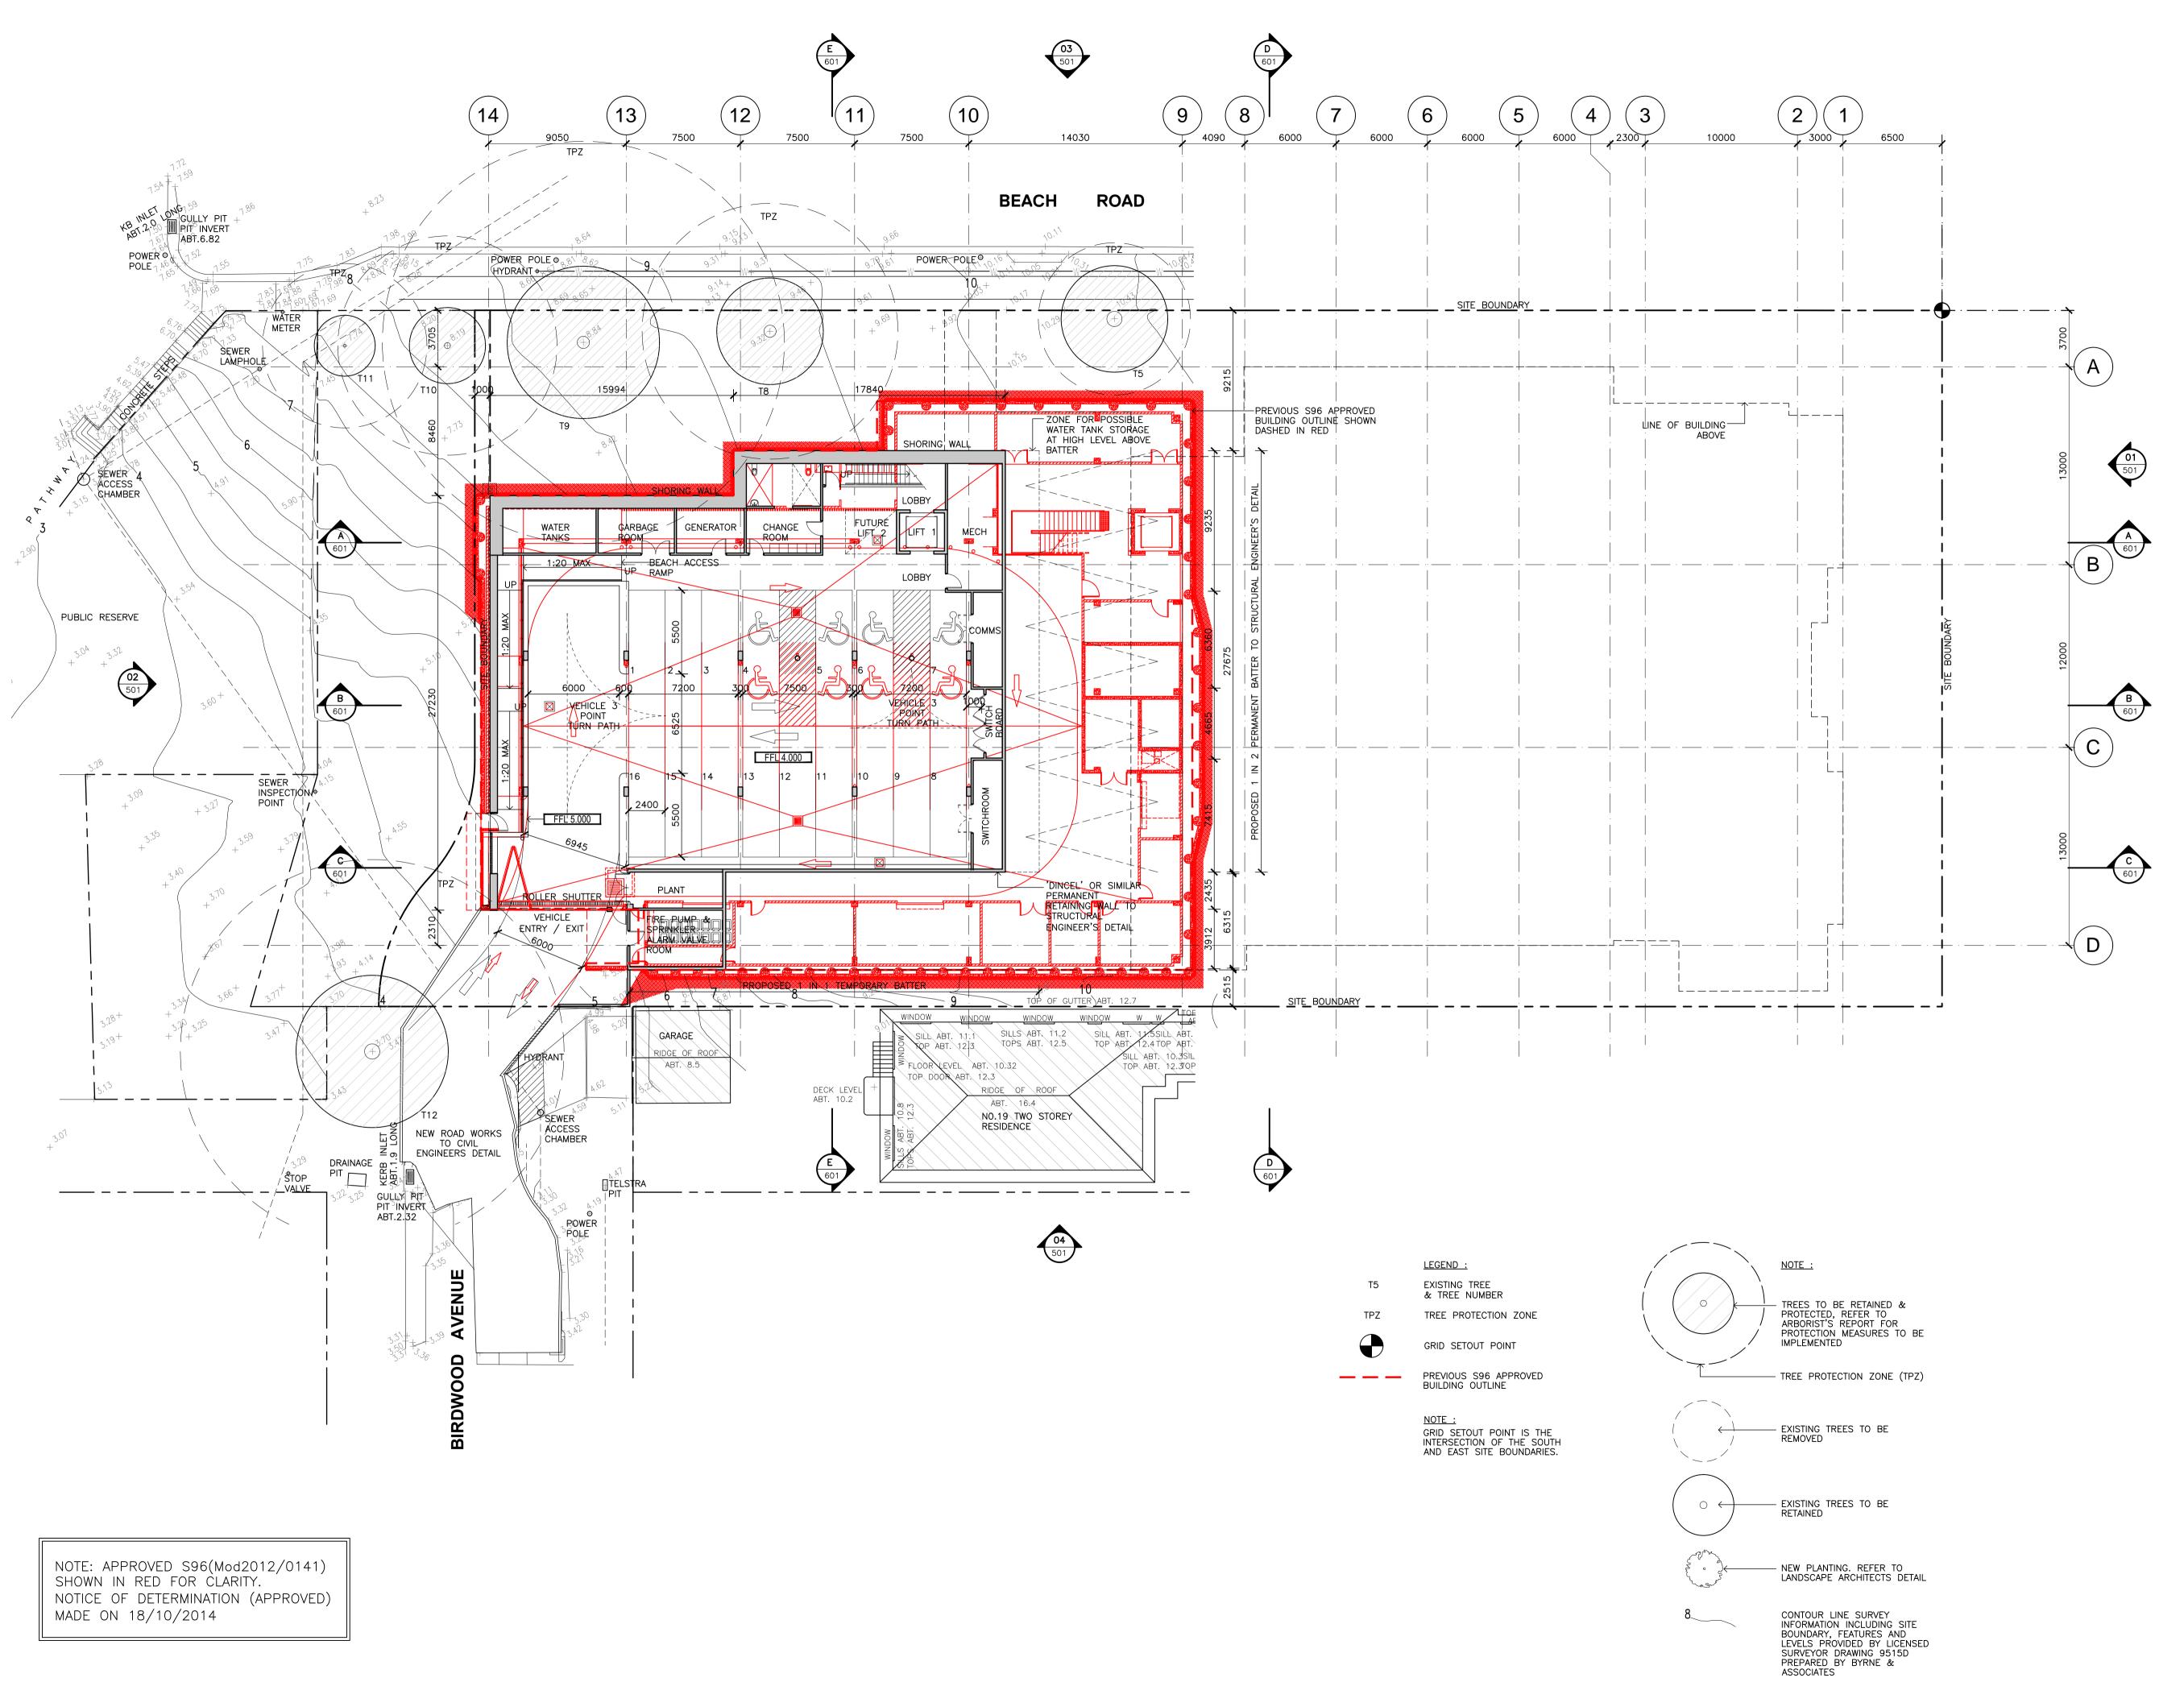



Client




Project

SARGOOD CENTRE 1 Brissenden Avenue Collaroy NSW 2097

BASEMENT FLOOR PLAN S96 OVERLAY

	Issue
DA-110	
	Drawing Size
	A1
Date	Drawn By
JAN 2014	MG

1148_SARGOOD/DWG FILES/PLOT

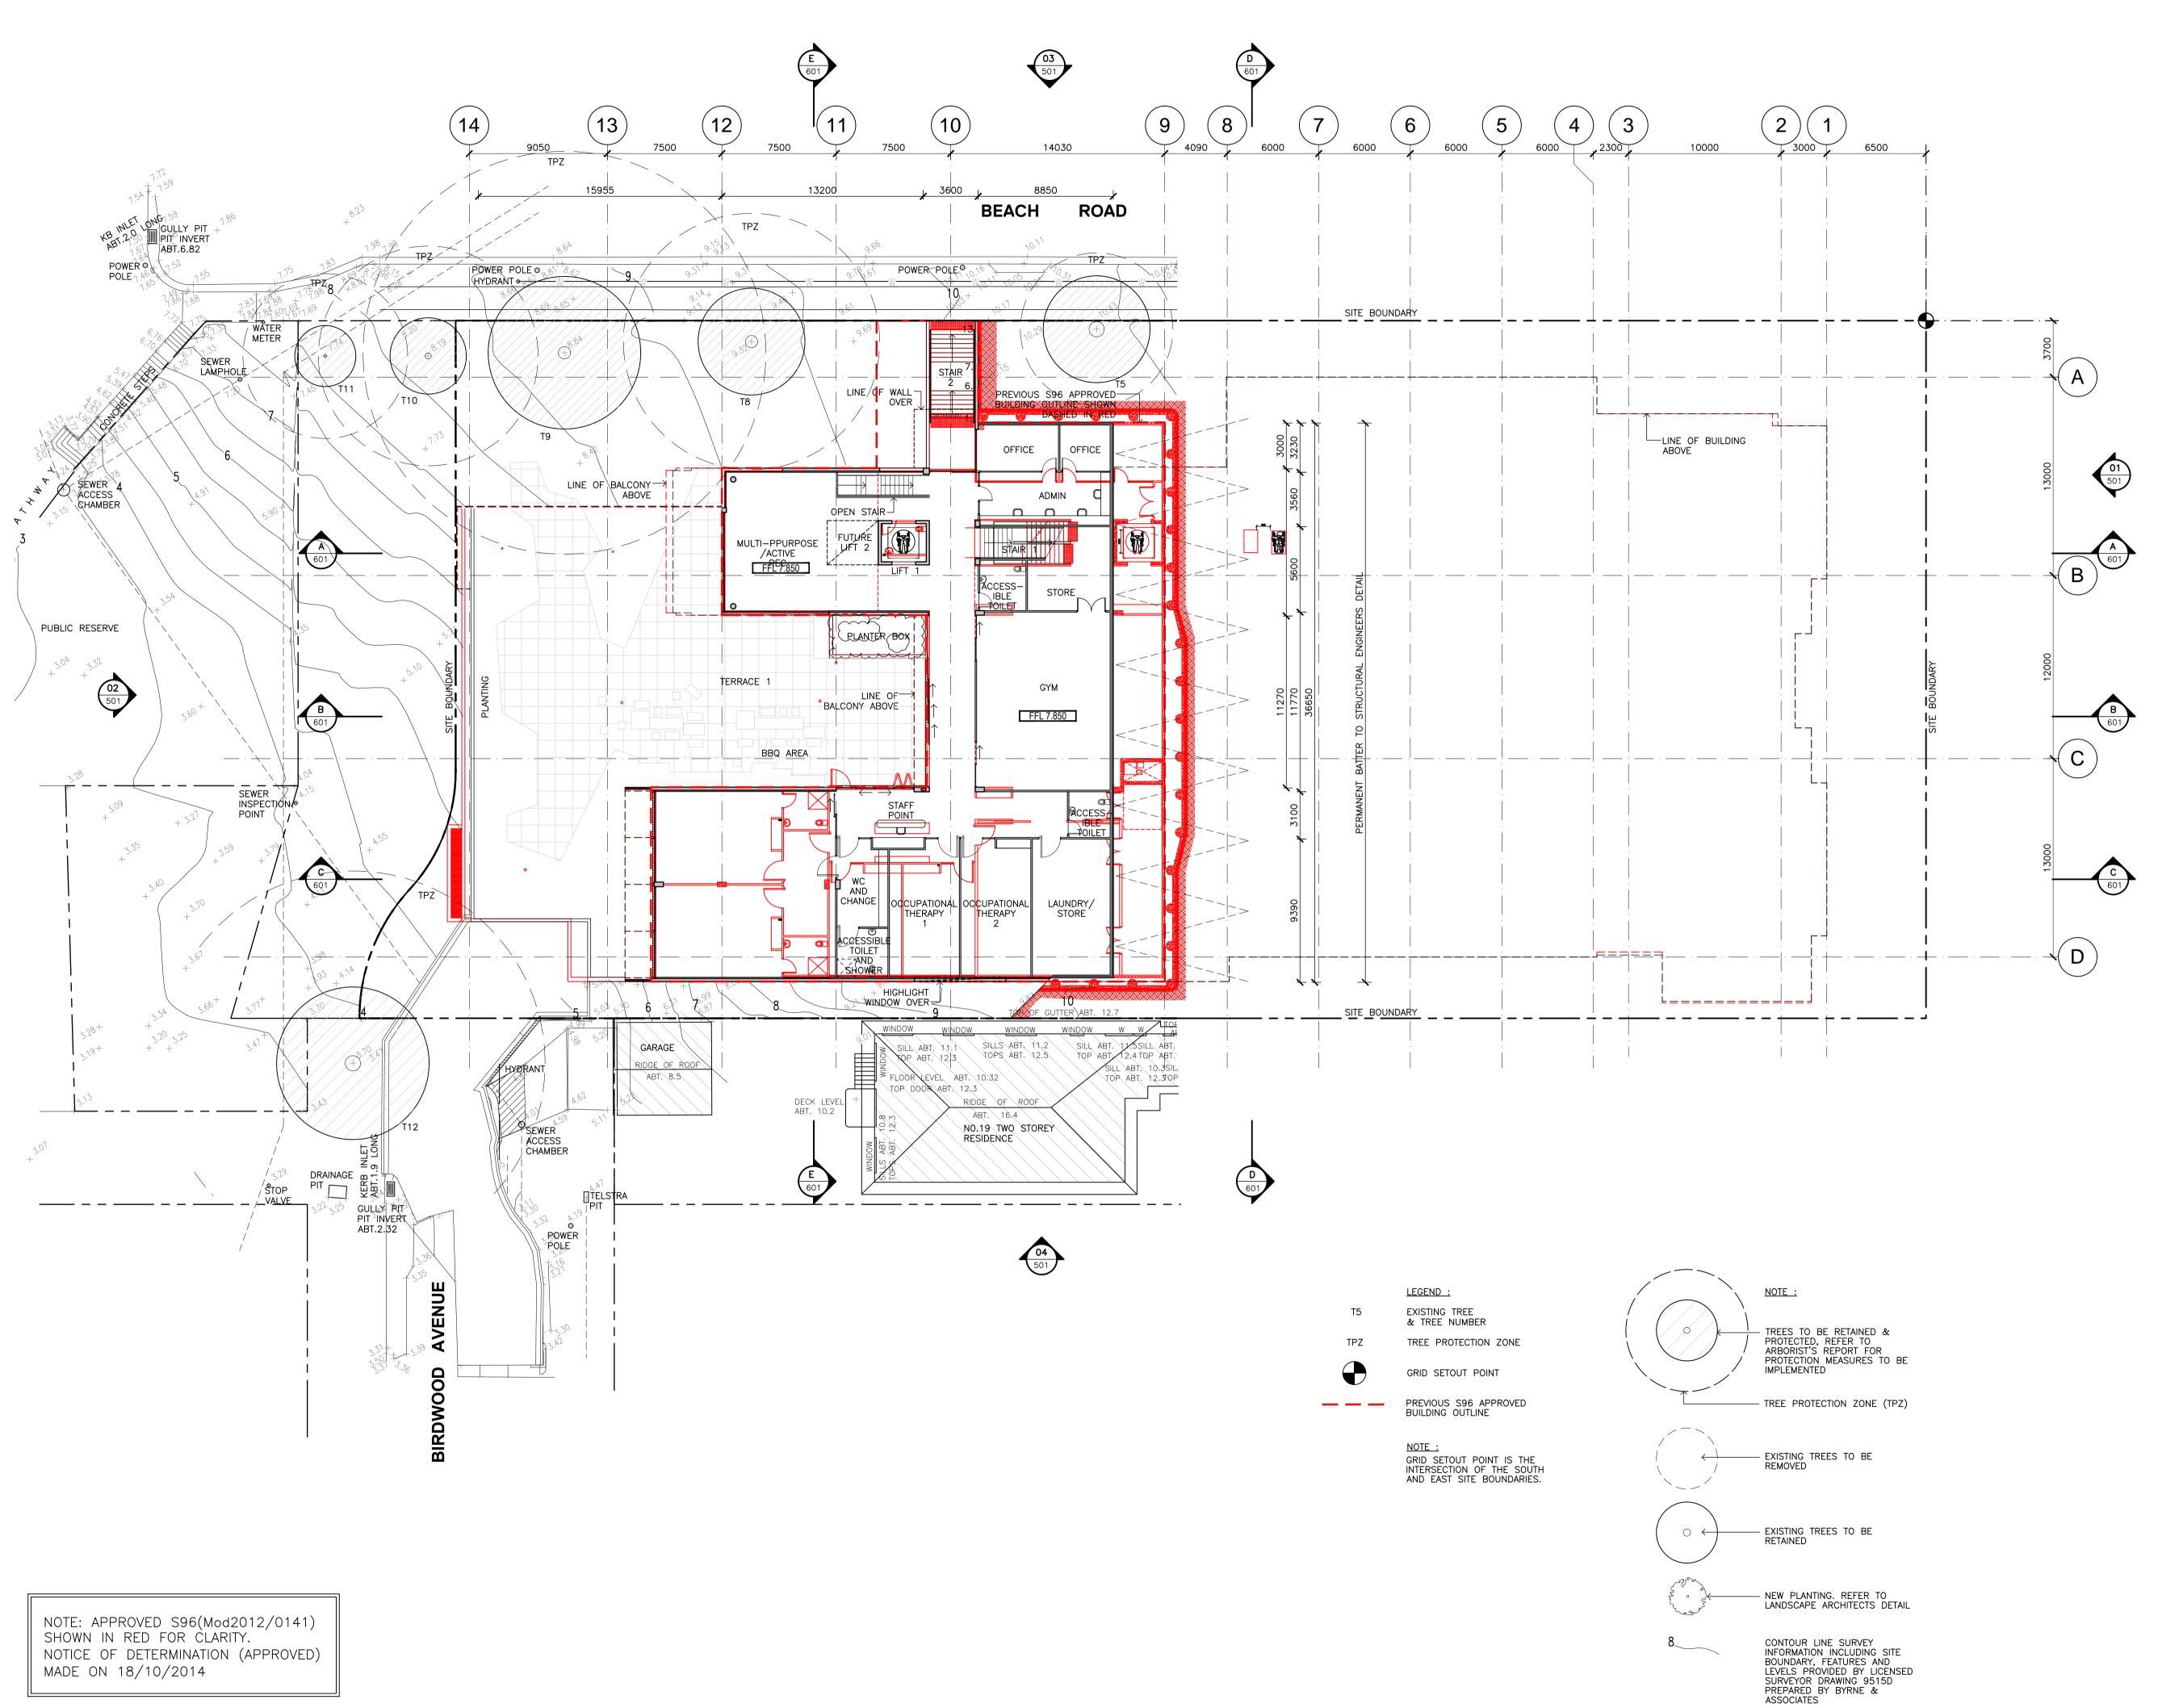



Client




Project

SARGOOD CENTRE 1 Brissenden Avenue Collaroy NSW 2097

LEVEL 1 FLOOR PLAN S96 OVERLAY

Drawing No.	Issue	
Scale 1:200		Drawing Size
Project No.	 Date	Drawn By
1148	JAN 2014	MG
CAD Reference		

CAD Reference 1148_SARGOOD/DWG FILES/PLOT

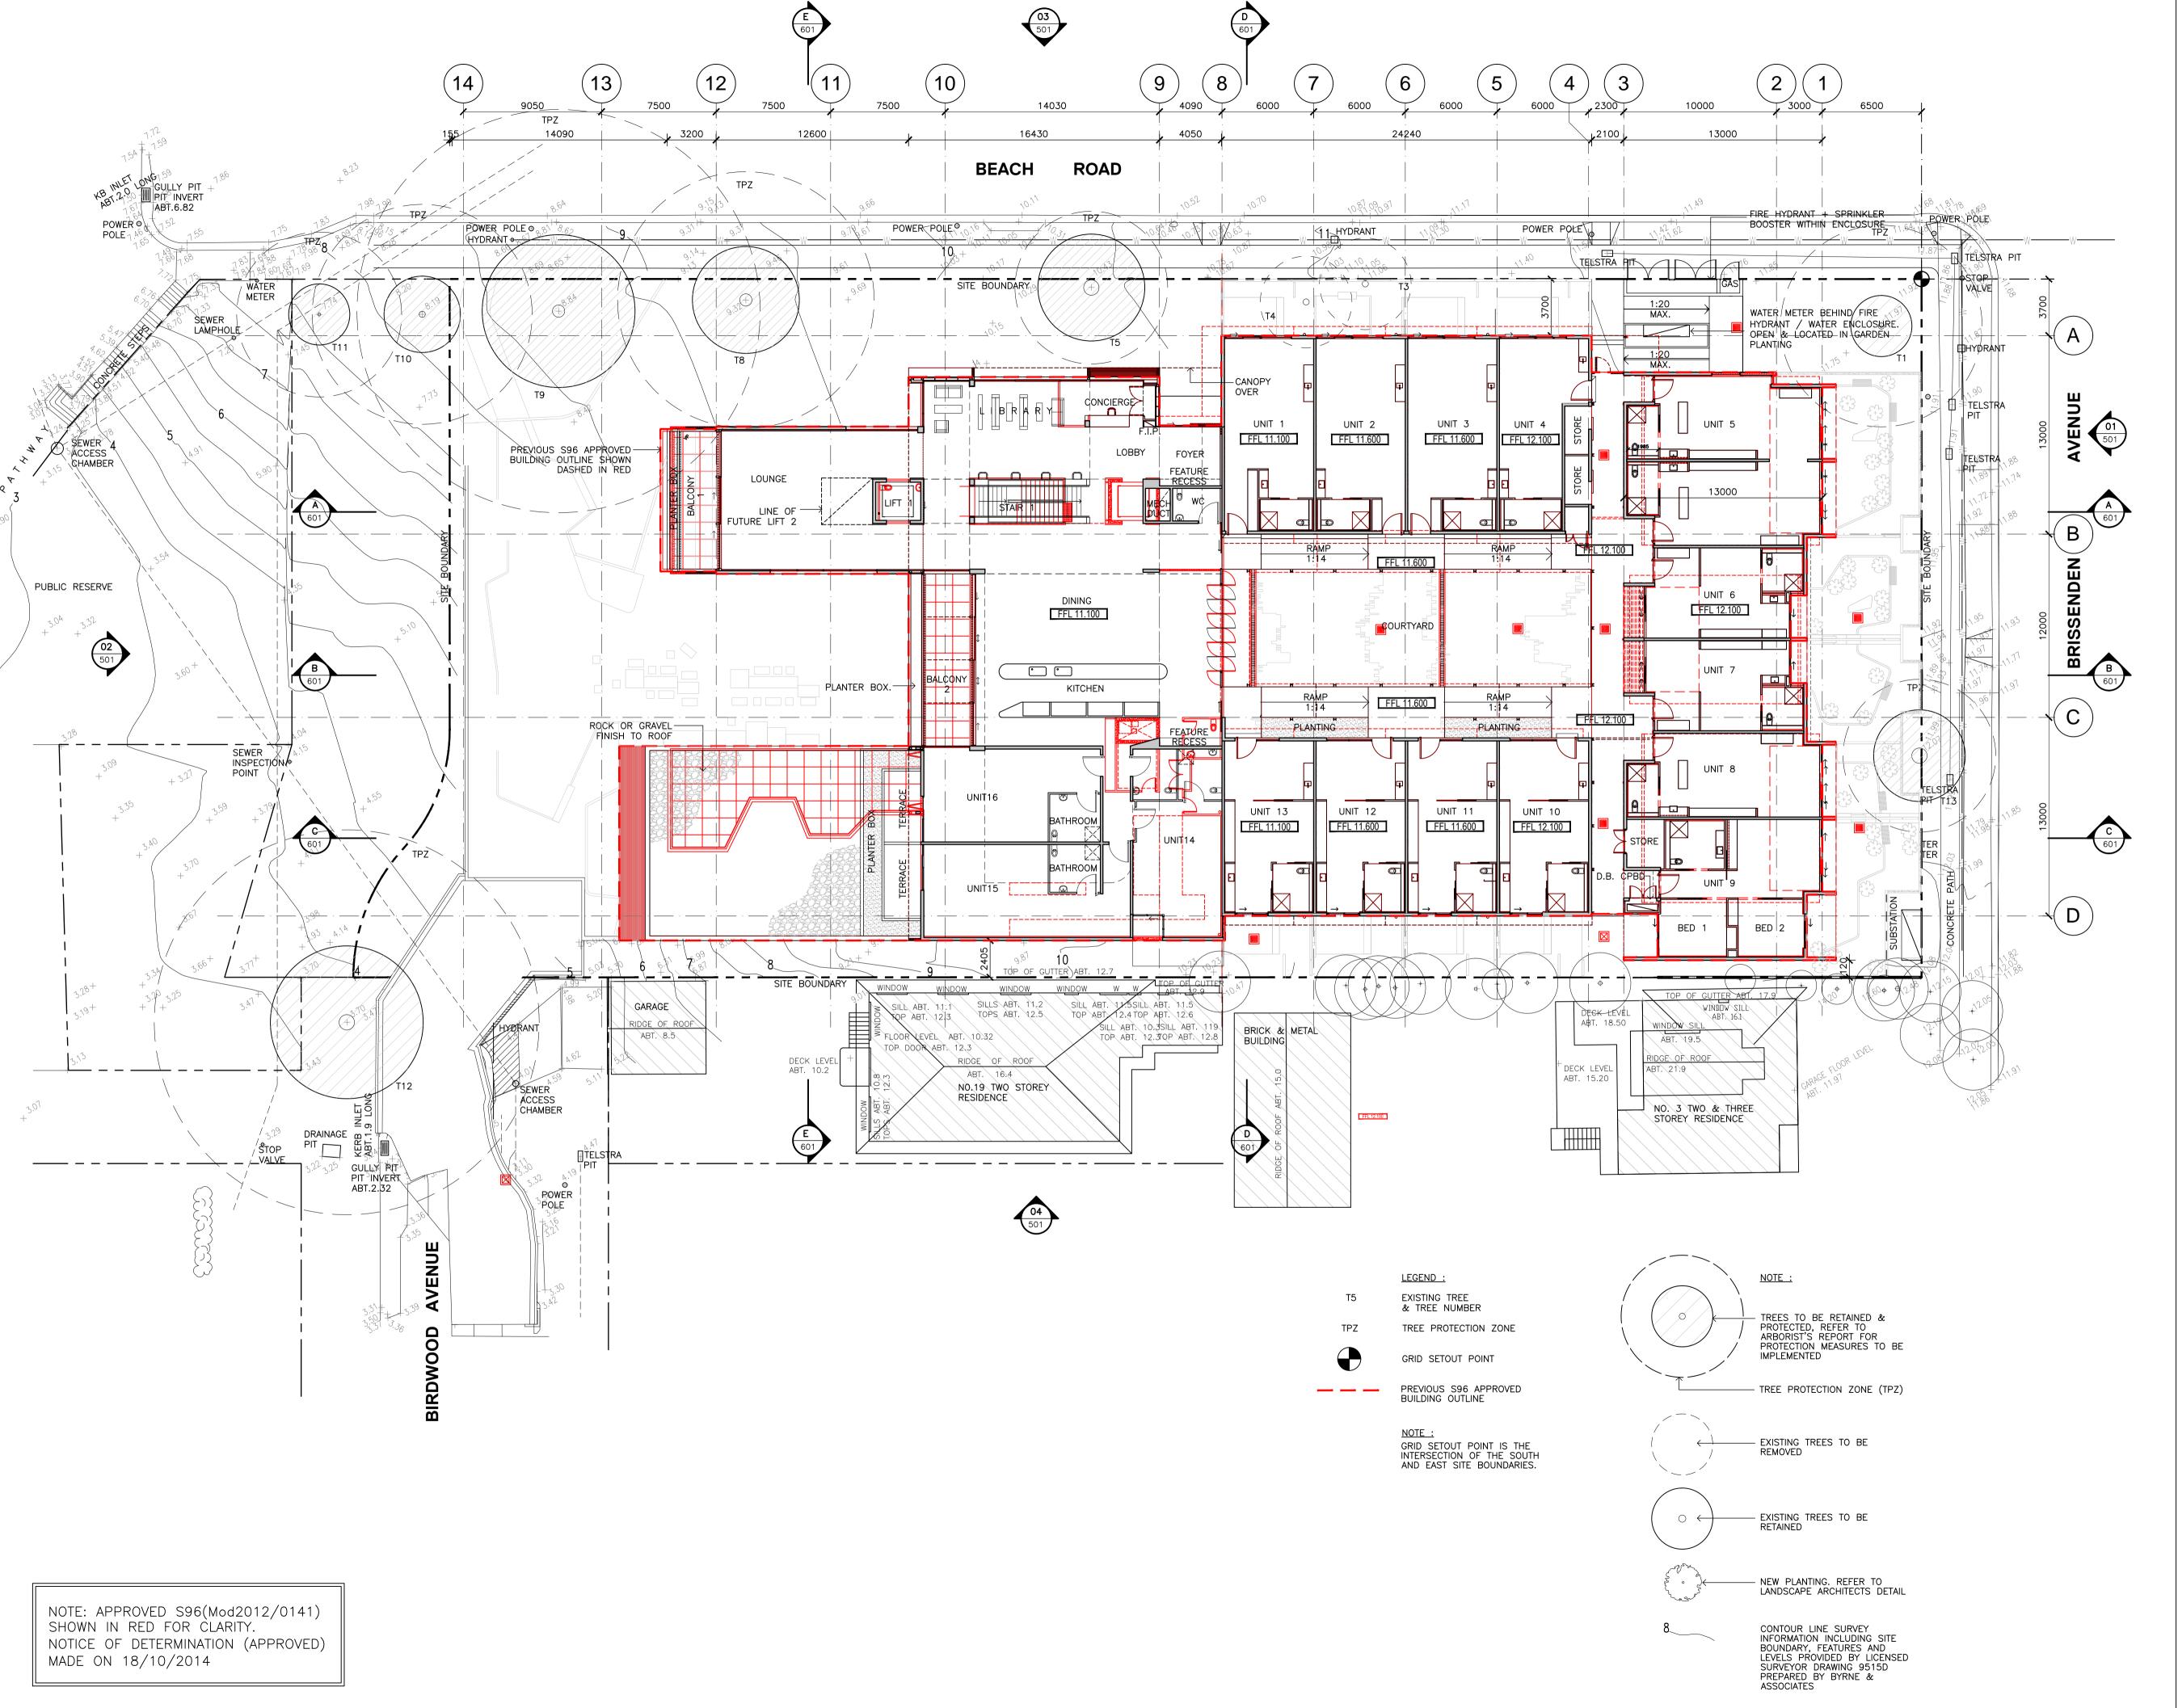





Project SARGOOD CENTRE 1 Brissenden Avenue Collaroy NSW 2097


Client

LEVEL 2 FLOOR PLAN S96 OVERLAY

Drawing No.		Issue 1
Scale 1:200		Drawing Size
Project No. 1148	Date JAN 2014	Drawn By

CAD Reference

1148_SARGOOD/DWG FILES/PLOT

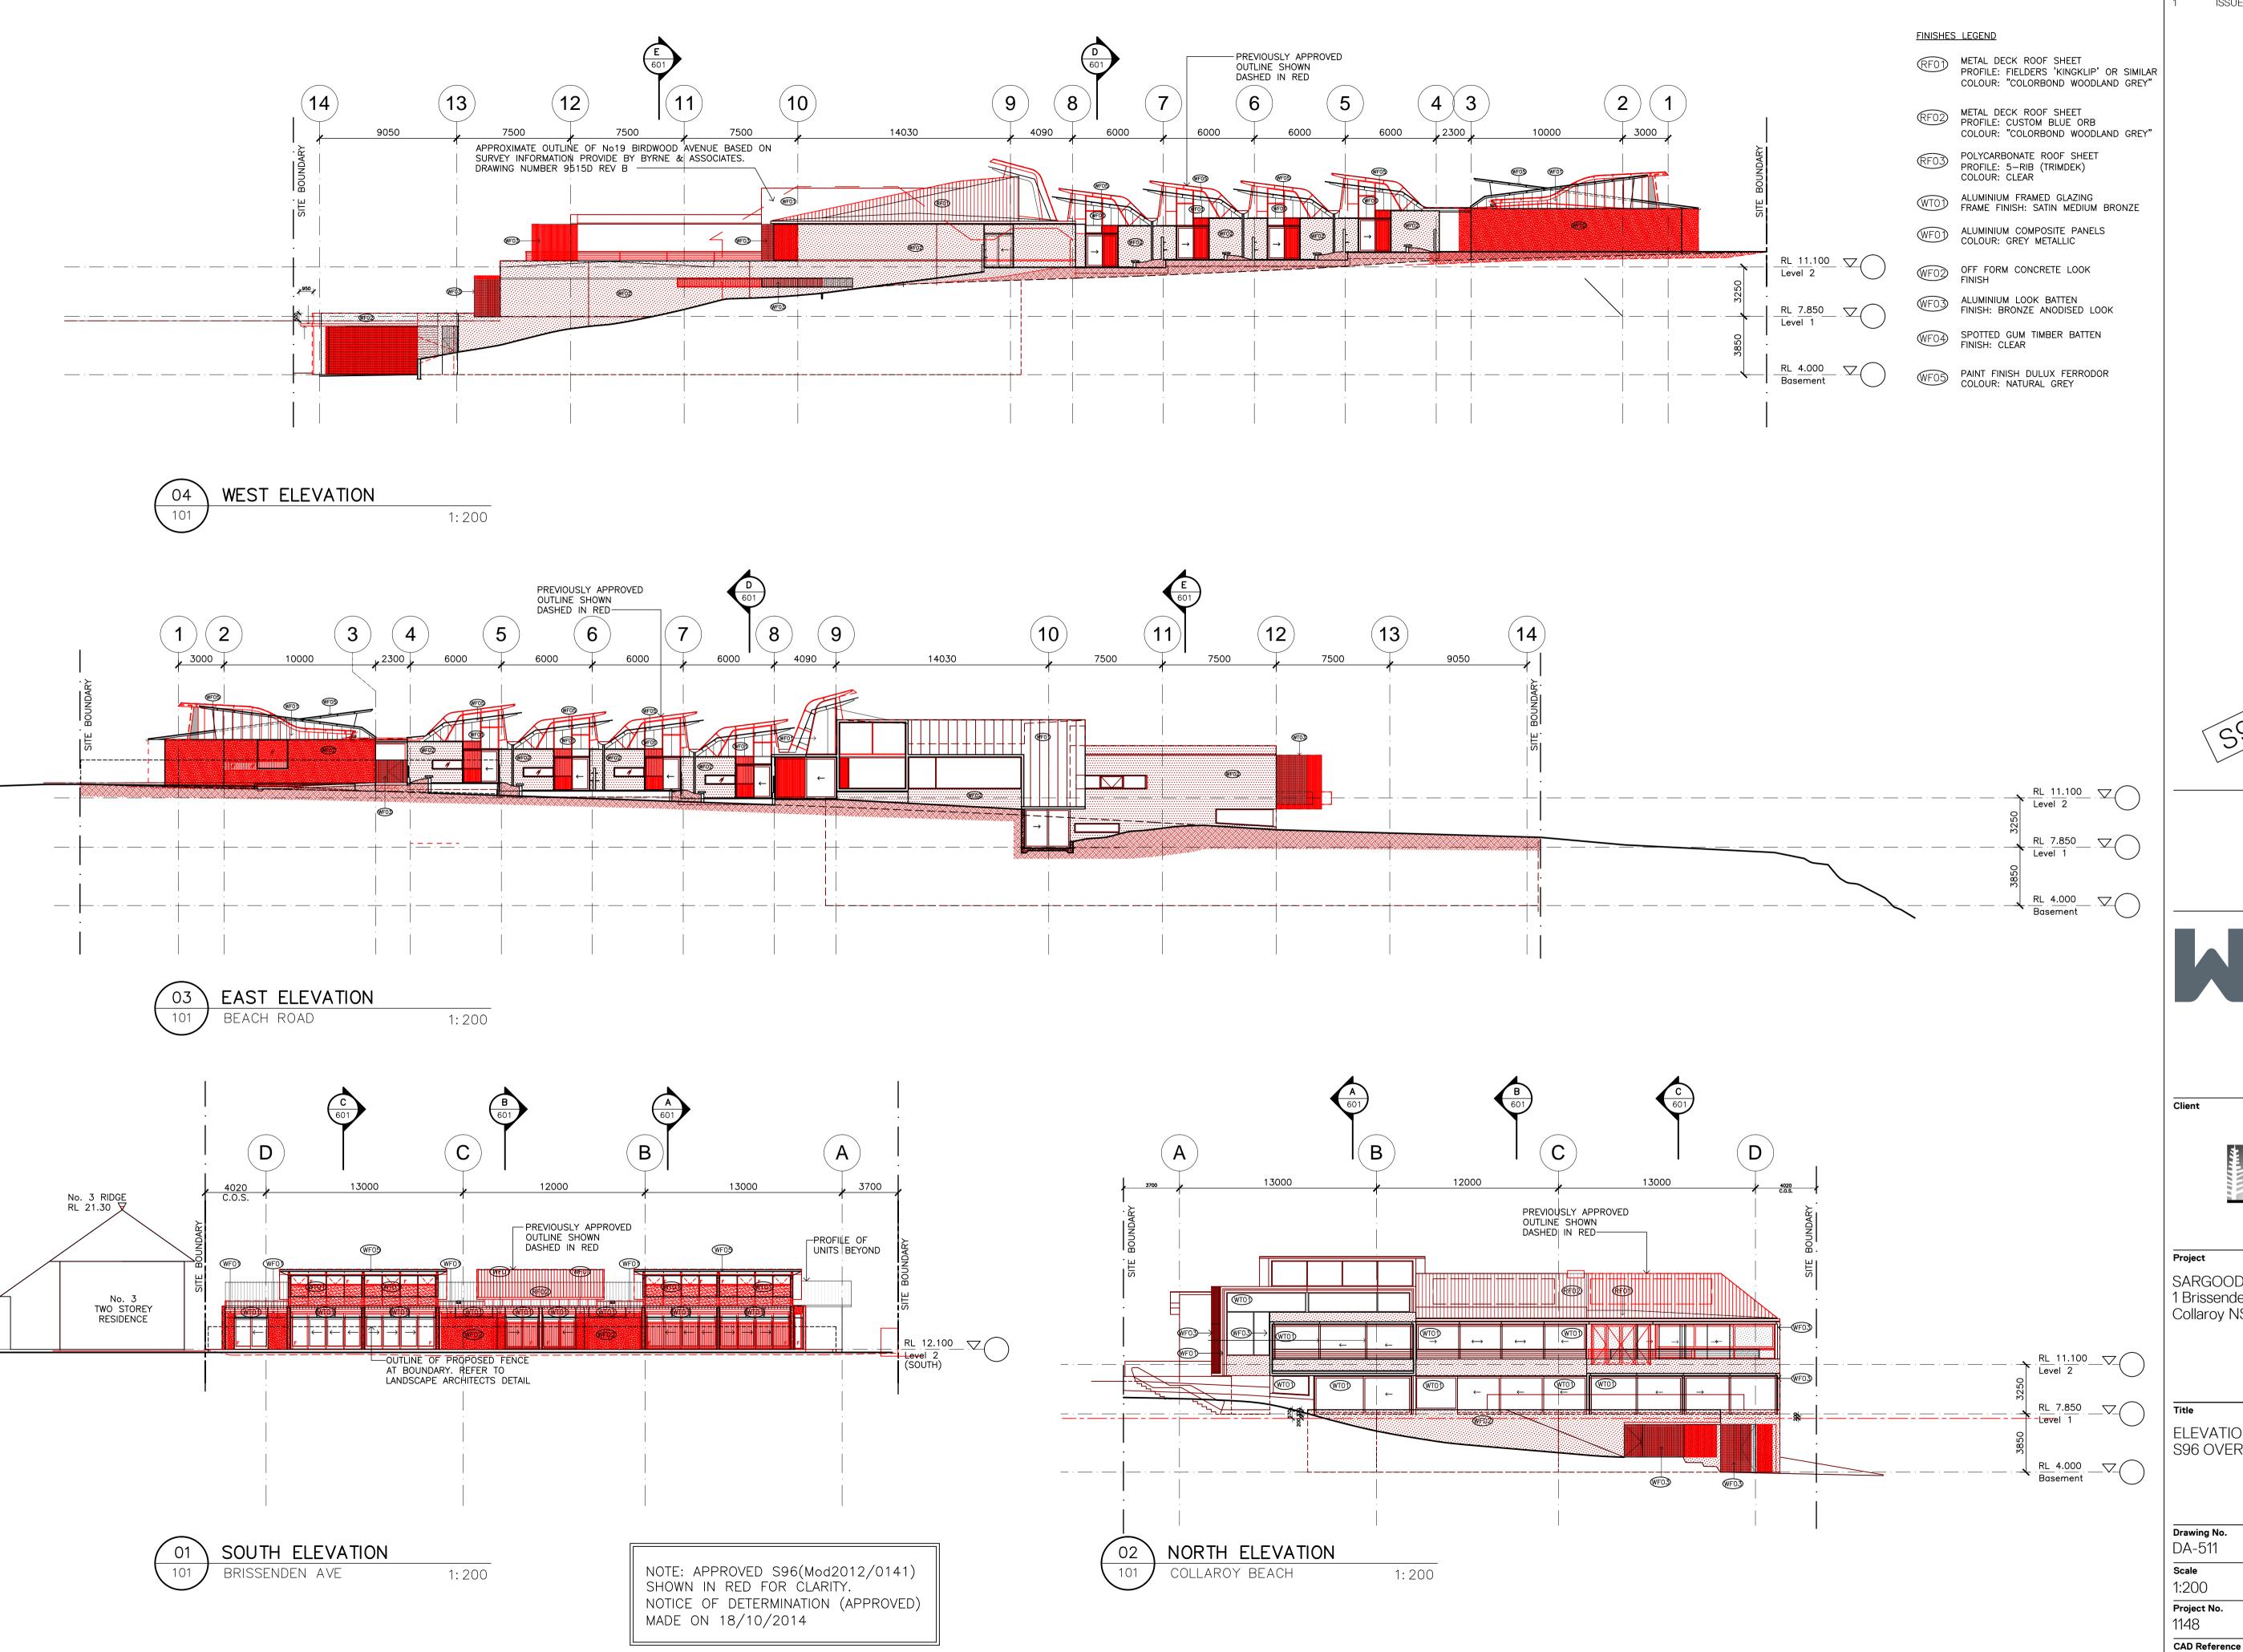

Issue Description ISSUED FOR S96 APPLICATION






SARGOOD CENTRE 1 Brissenden Avenue Collaroy NSW 2097

ELEVATIONS S96 OVERLAY

Drawing No.	_	
Scale 1:200		Drawing Size
Project No.	Date JAN 2014	Drawn By

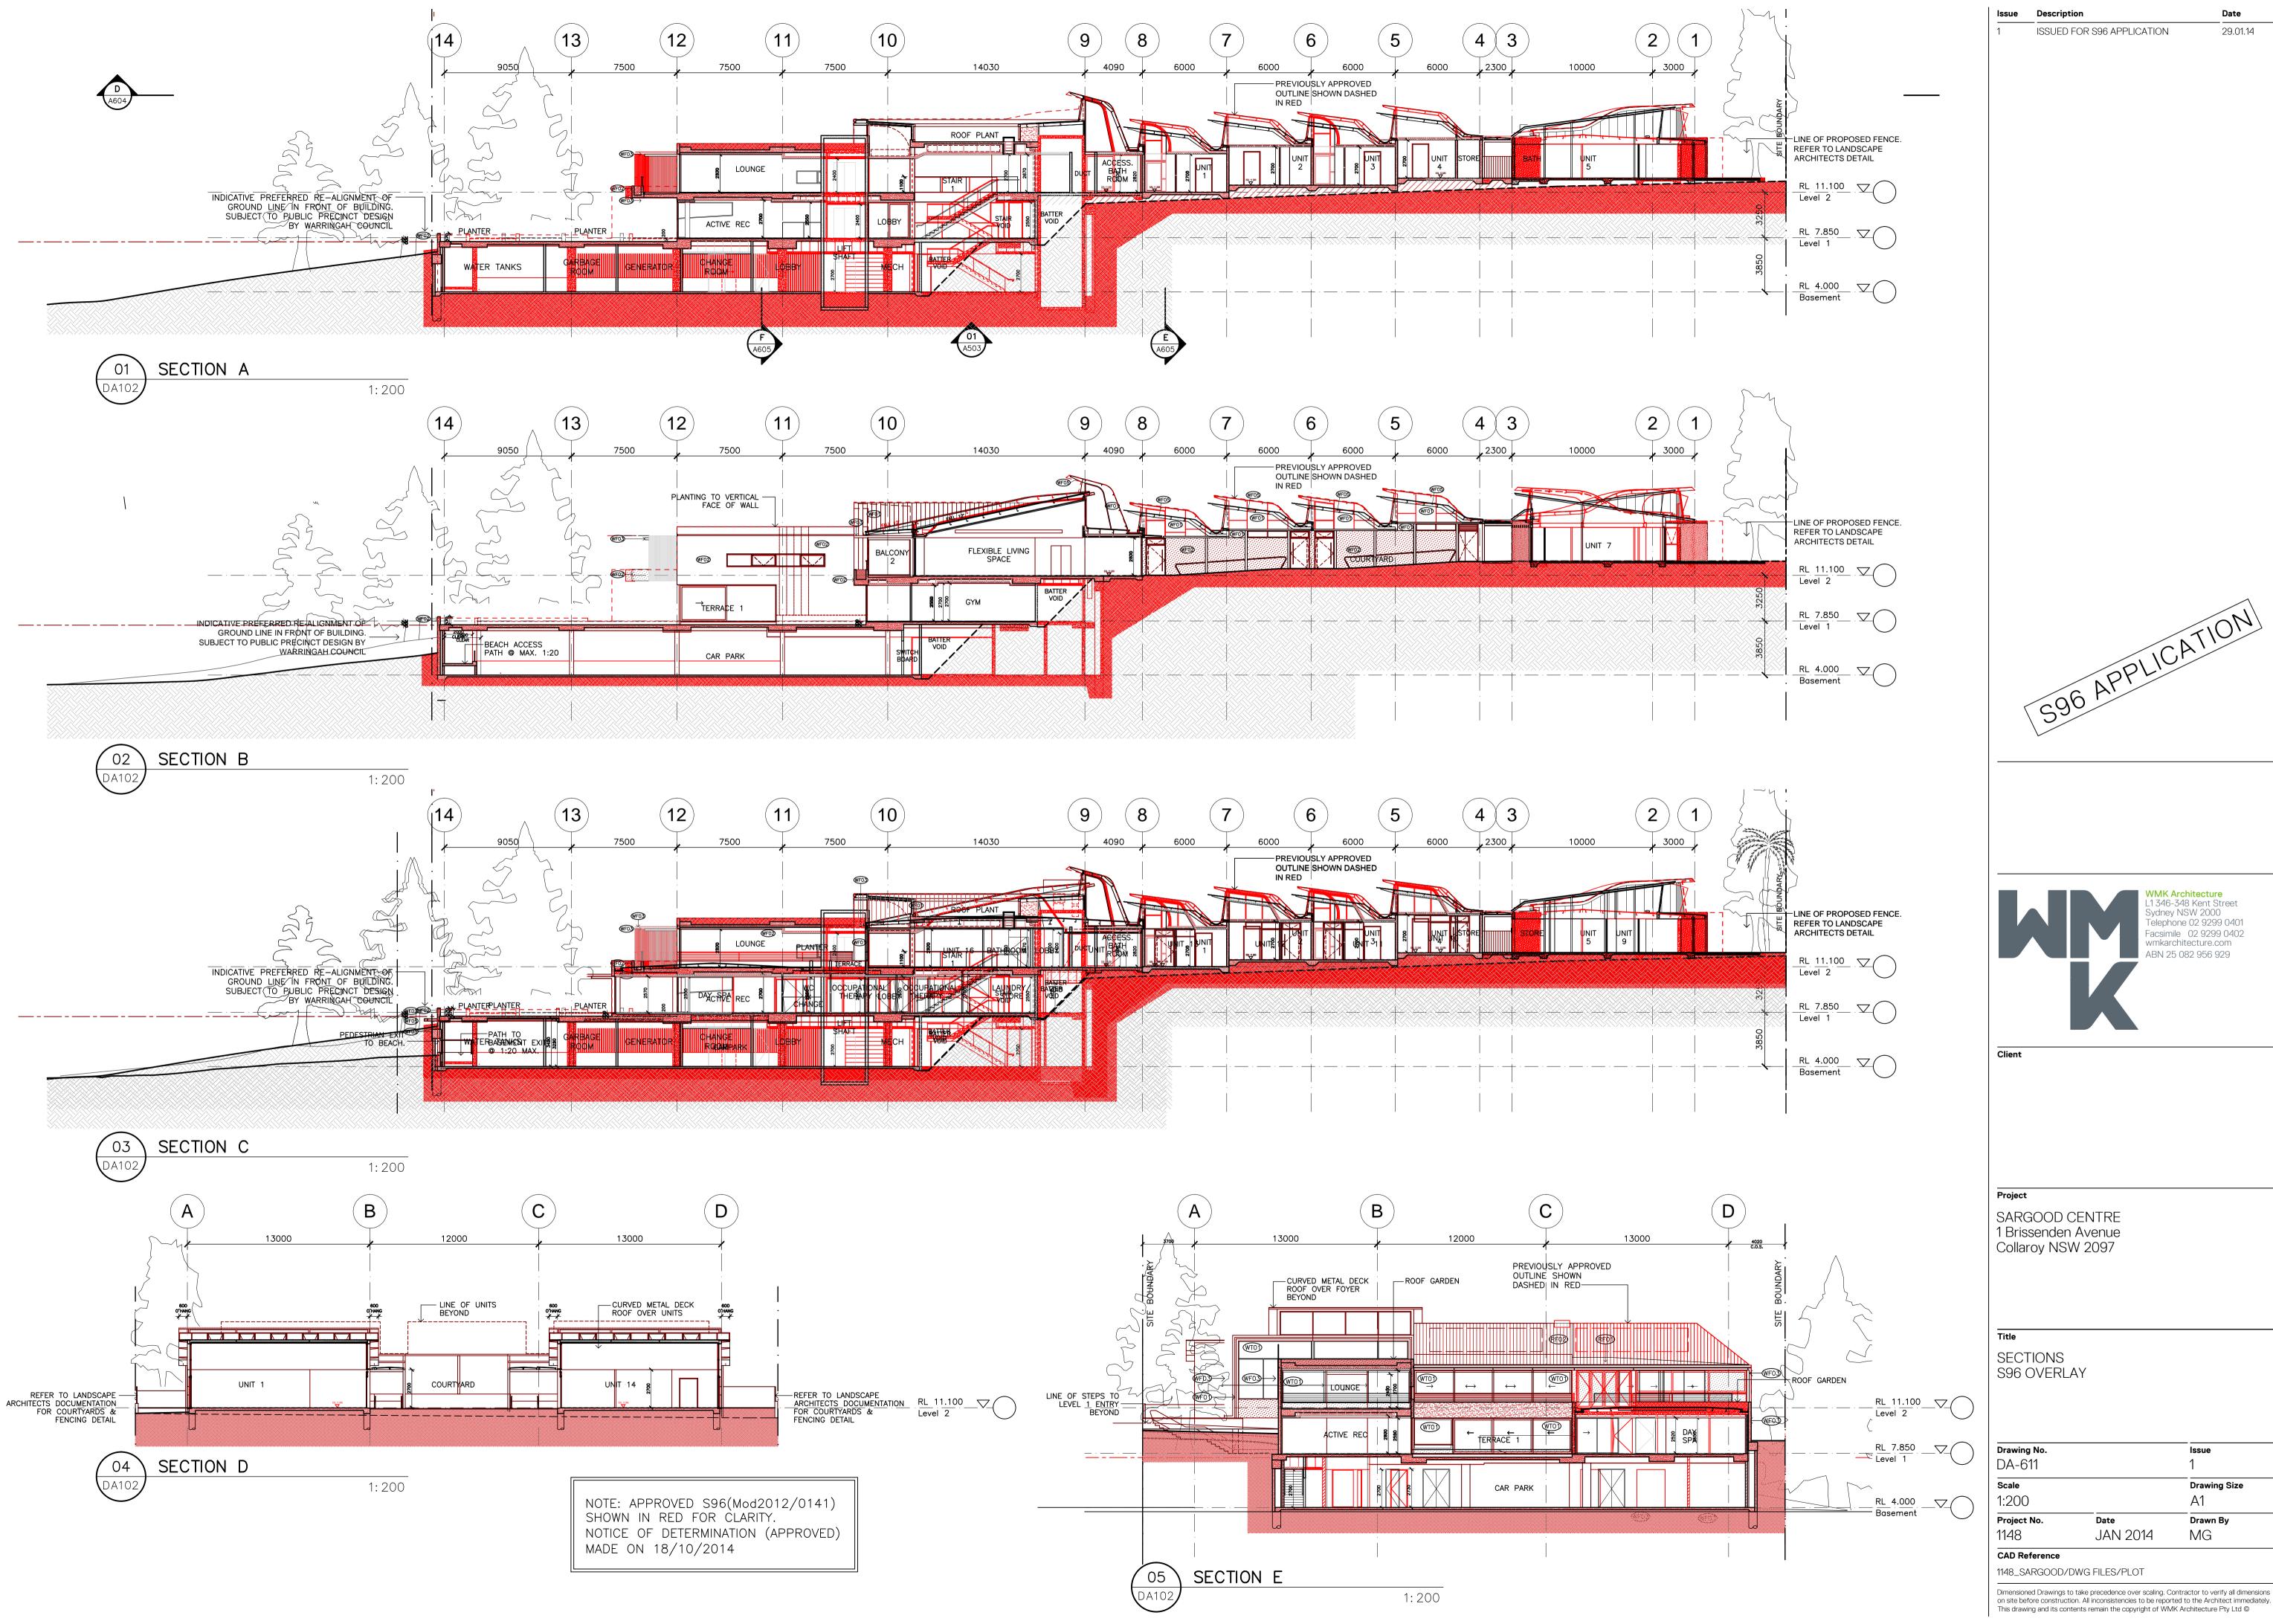




SARGOOD CENTRE 1 Brissenden Avenue Collaroy NSW 2097

S96 OVERLAY


Drawing No.		Issue 1
Scale 1:200		Drawing Size
Project No. 1148	Date JAN 2014	Drawn By MG
CAD Reference		

1148_SARGOOD/DWG FILES/PLOT

Dimensioned Drawings to take precedence over scaling. Contractor to verify all dimensions

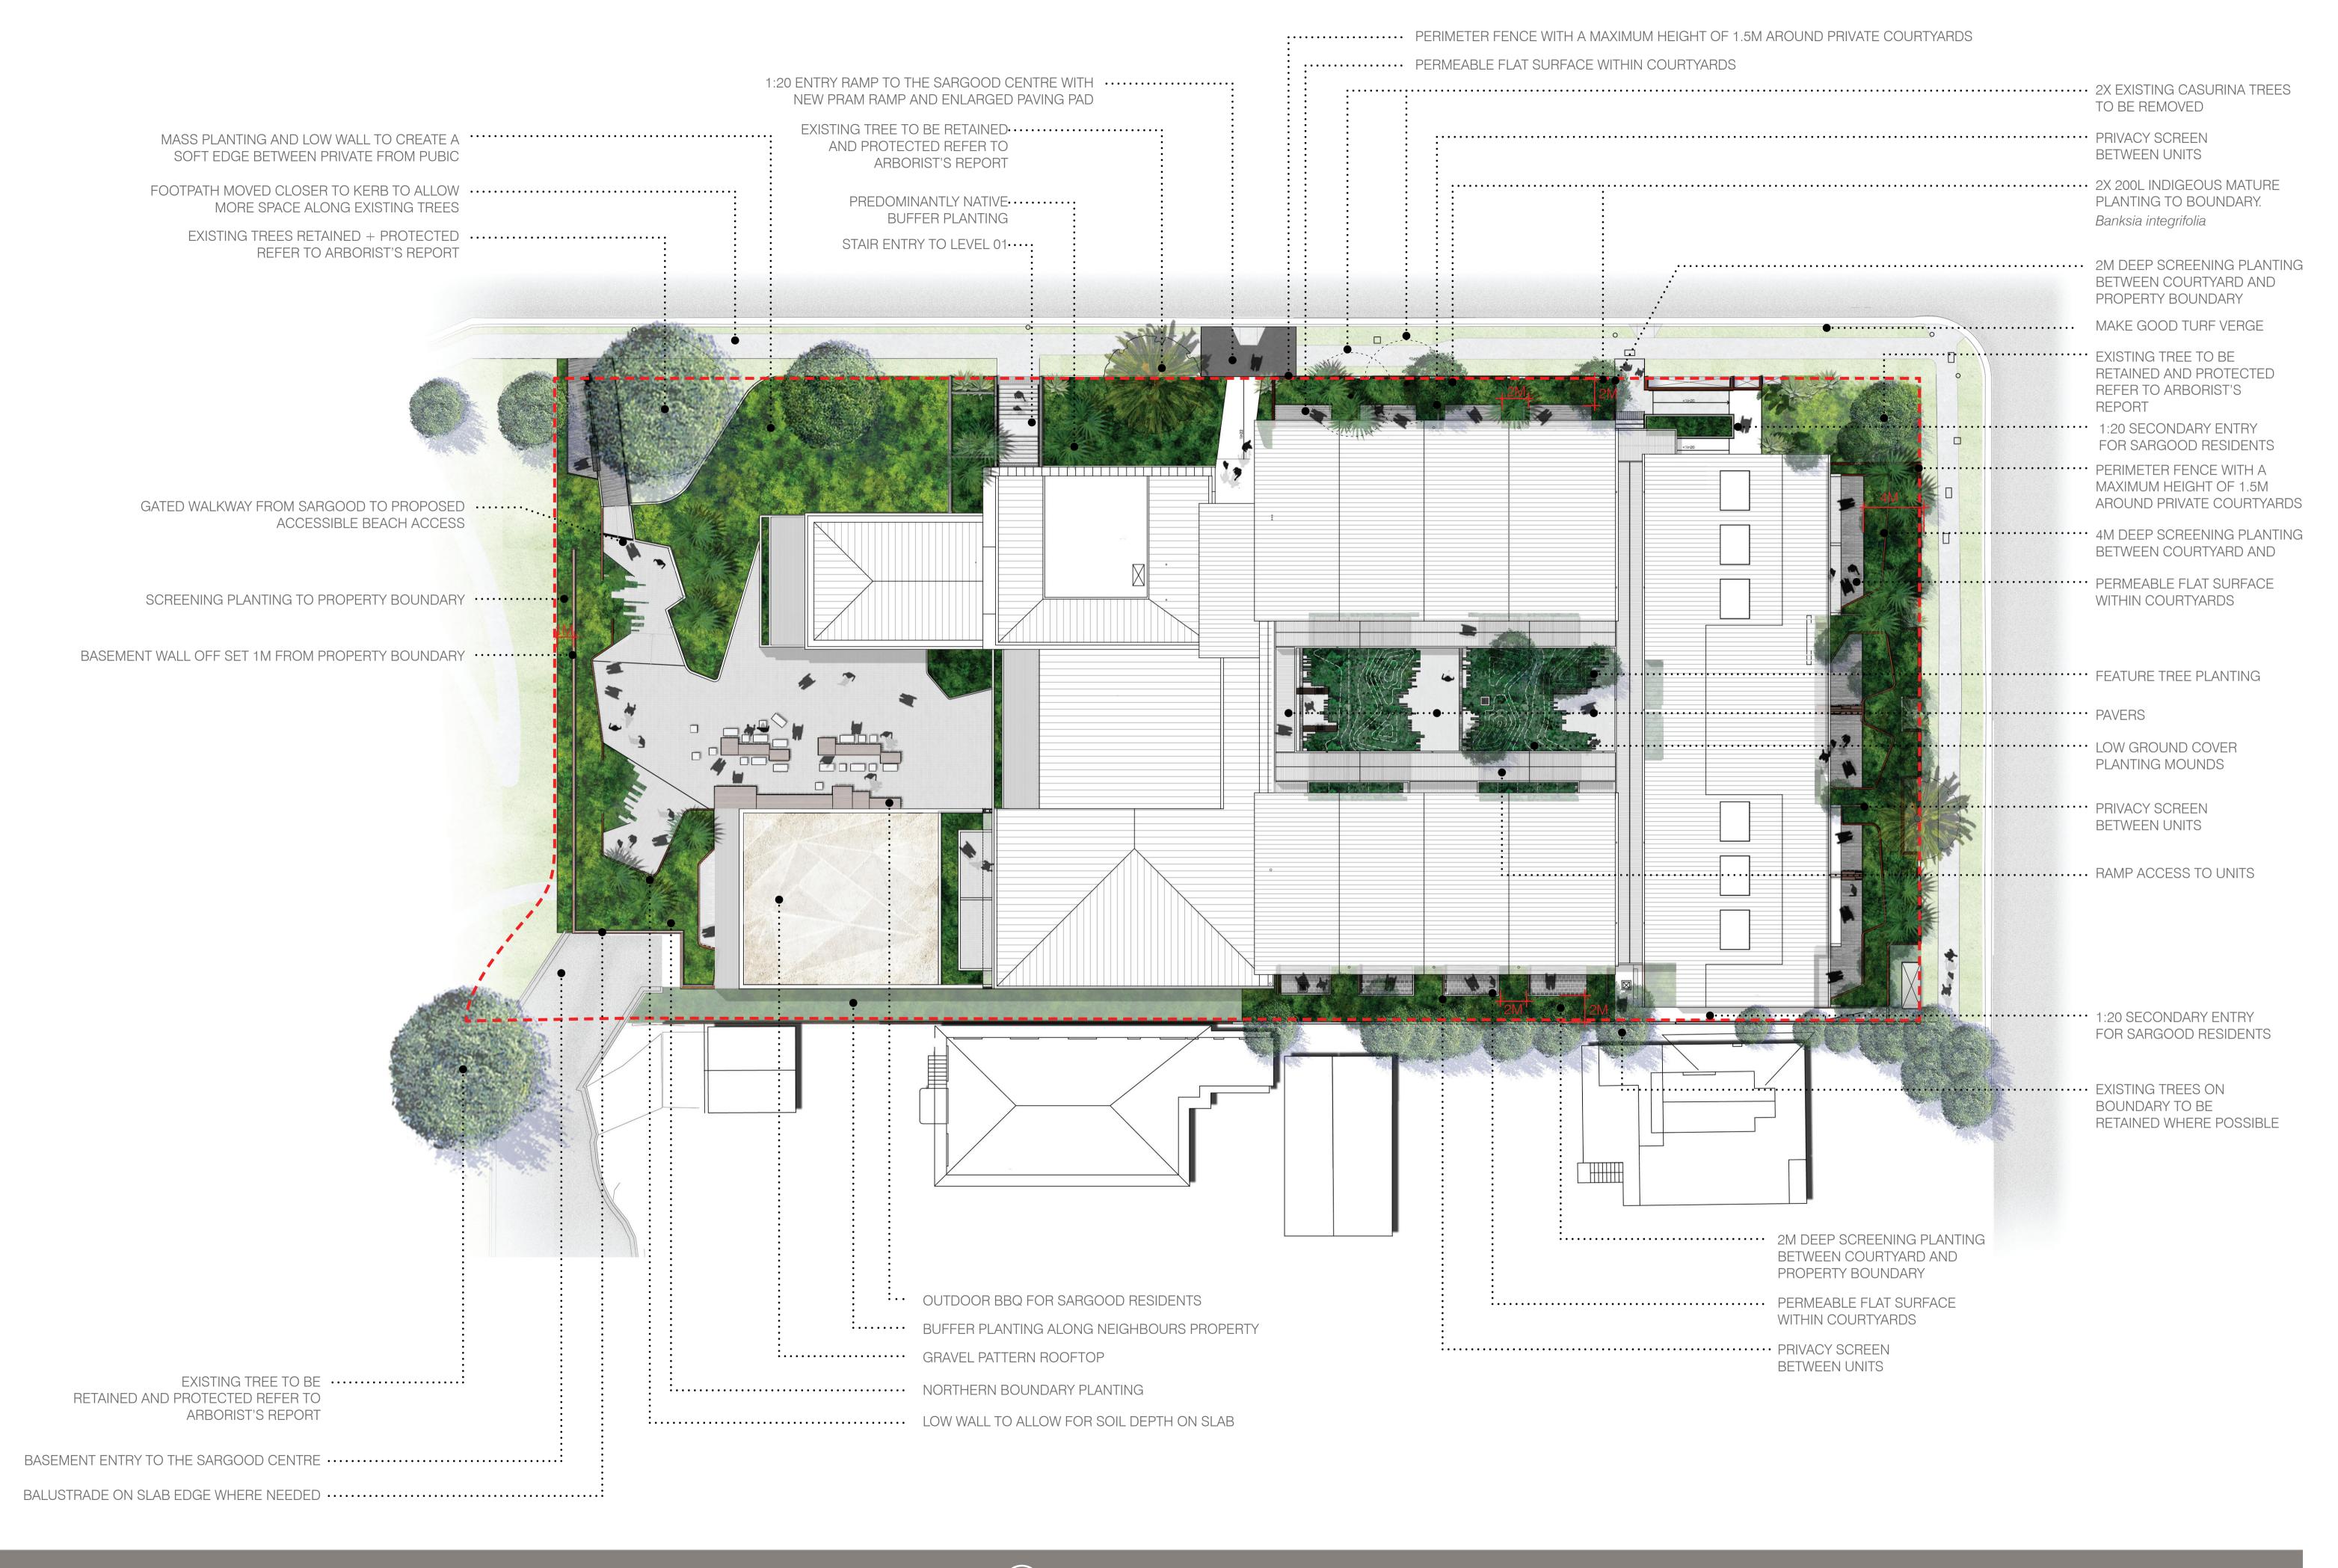

OCULUS | THE SARGOOD CENTRE | ILLUSTRATIVE LANDSCAPE MASTER PLAN | FOR SECTION 96 | SCALE: 1:200 @ A1

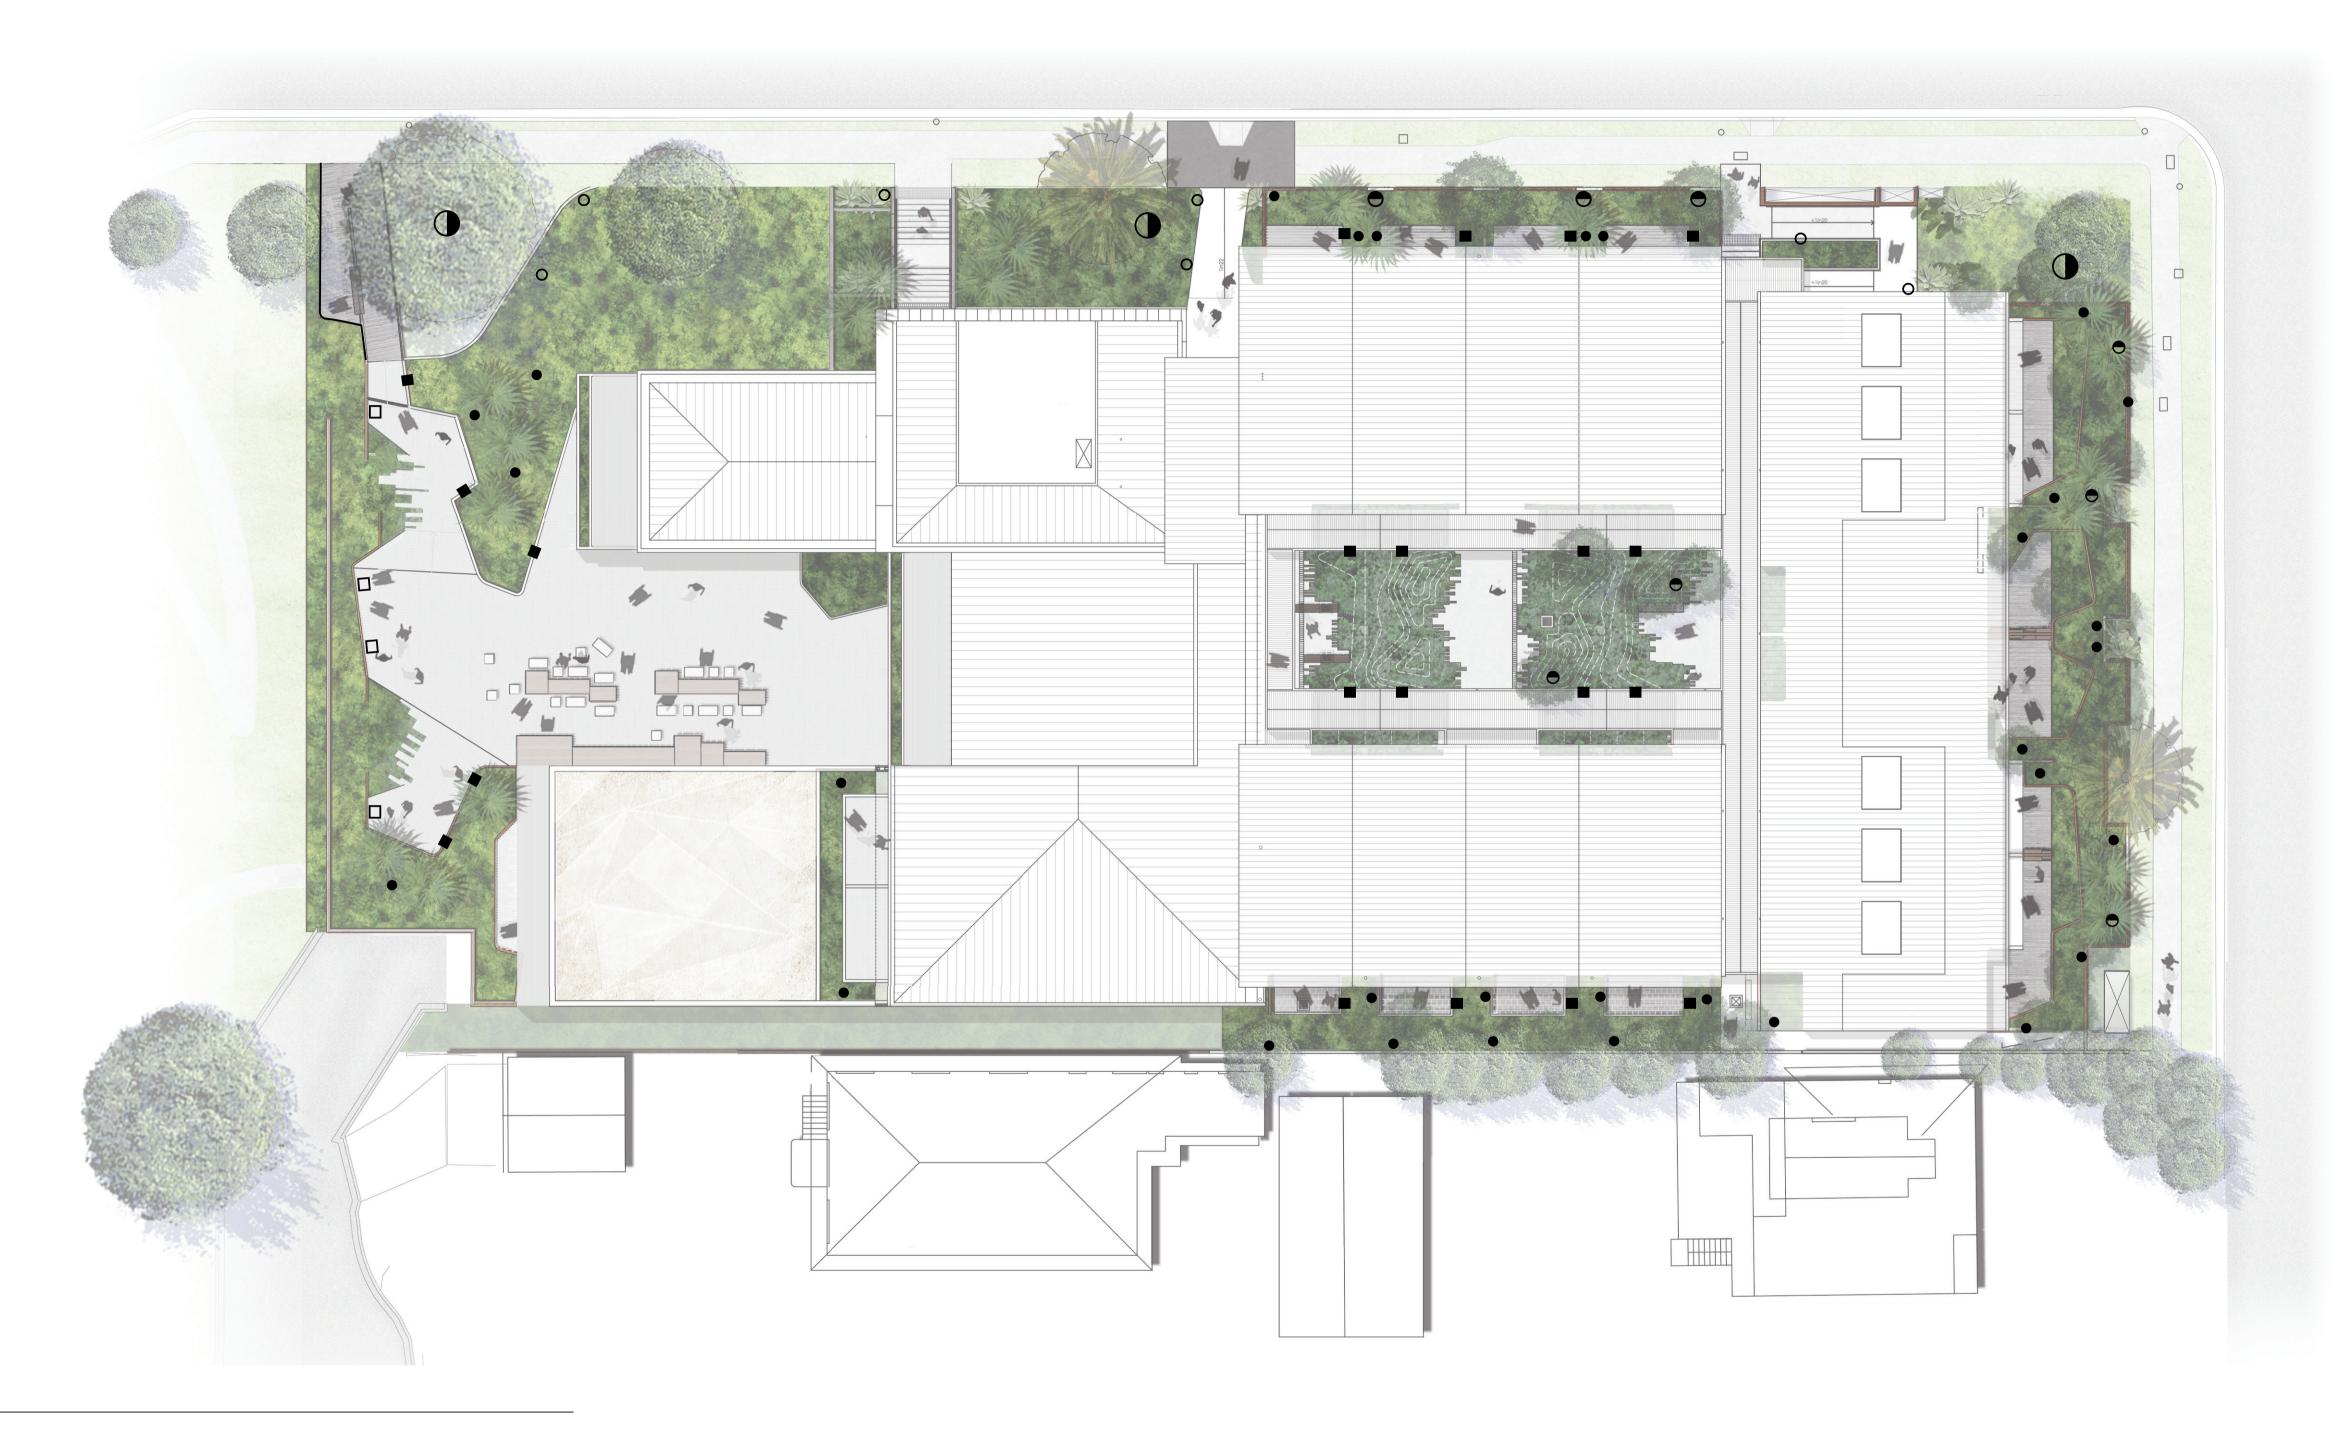


INDICATIVE EXTERNAL LIGHTING PLAN


LEGEND

- ON-GROUND FLOODLIGHT (PUBLIC)
 ON-GROUND FLOODLIGHT (PRIVATE)
 LED GARDEN LUMINAIRES WITH EARTH SPIKE
 LED GARDEN AND PATH LUMINAIRES


- STRIP LED LIGHT TO EGDE OF DECK
 RECTANGULAR IN-GROUND LUMINAIRES · IN EXTERNAL WALL
 □ RECTANGULAR IN-GROUND LUMINAIRES · IN GROUND

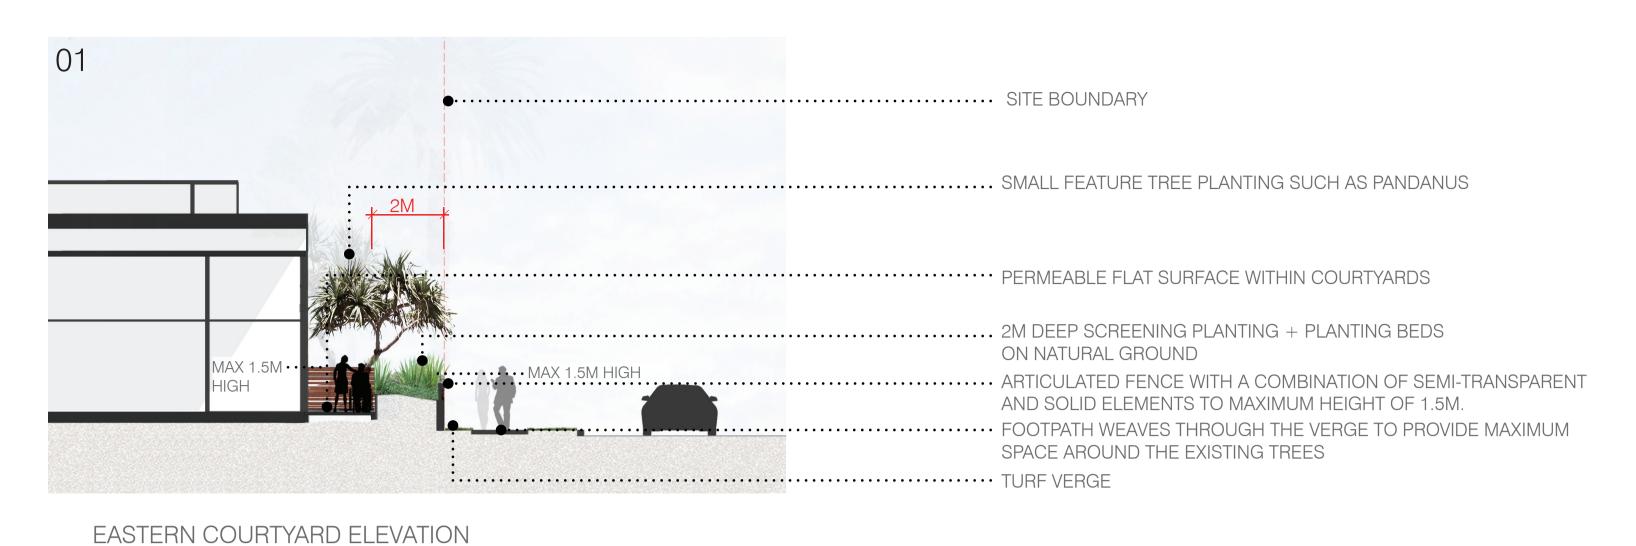



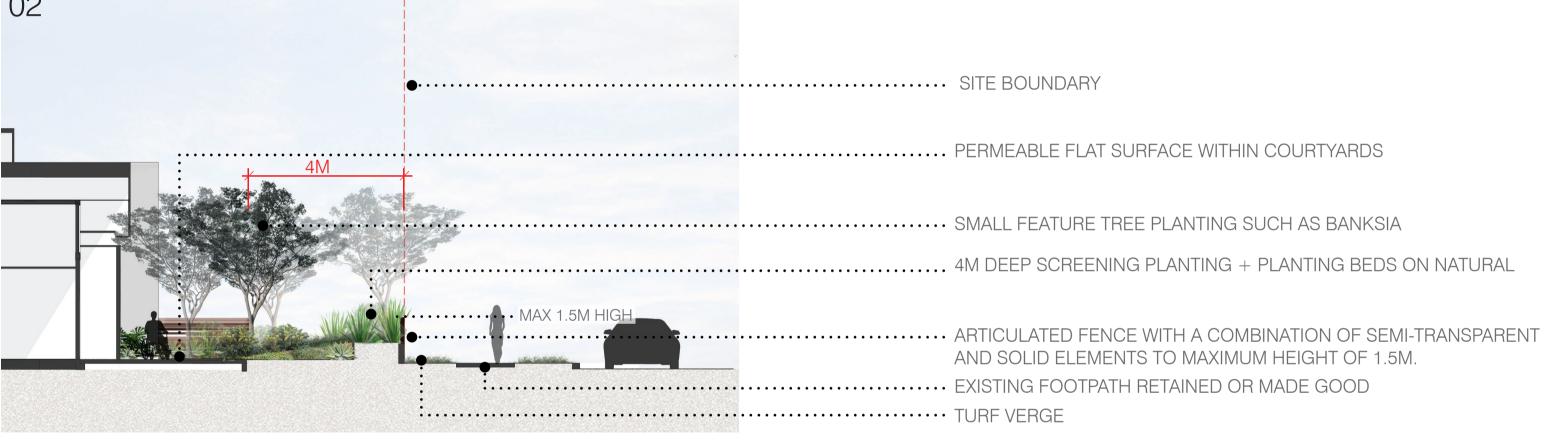


SOUTHERN COURTYARD ELEVATION

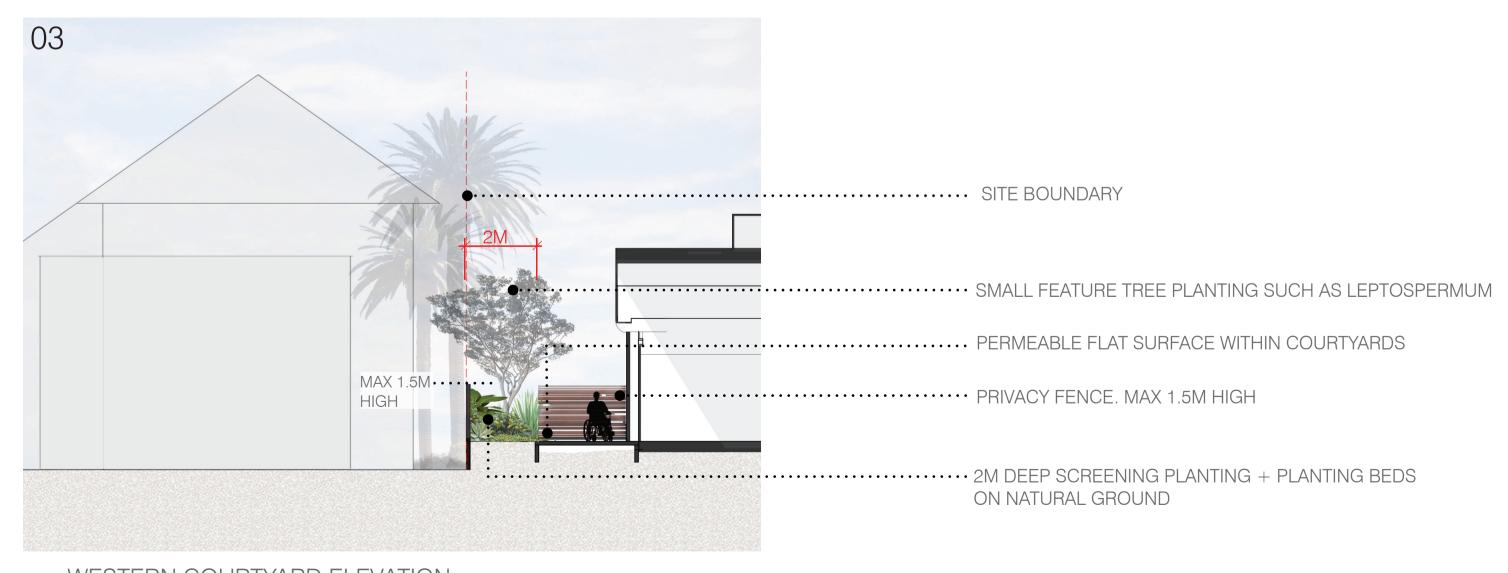


WESTERN COURTYARD ELEVATION

1:100



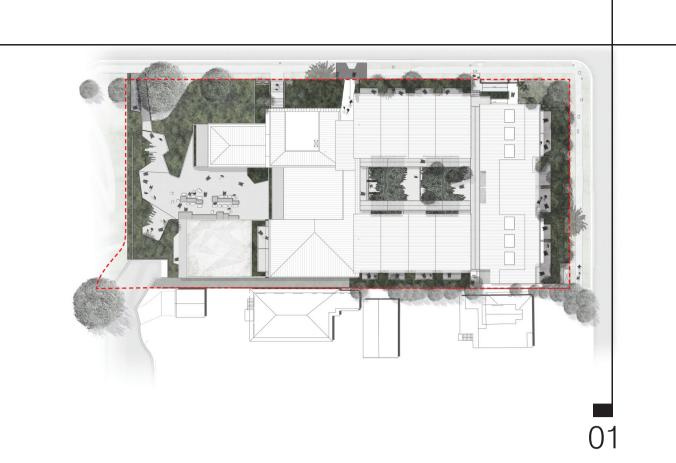

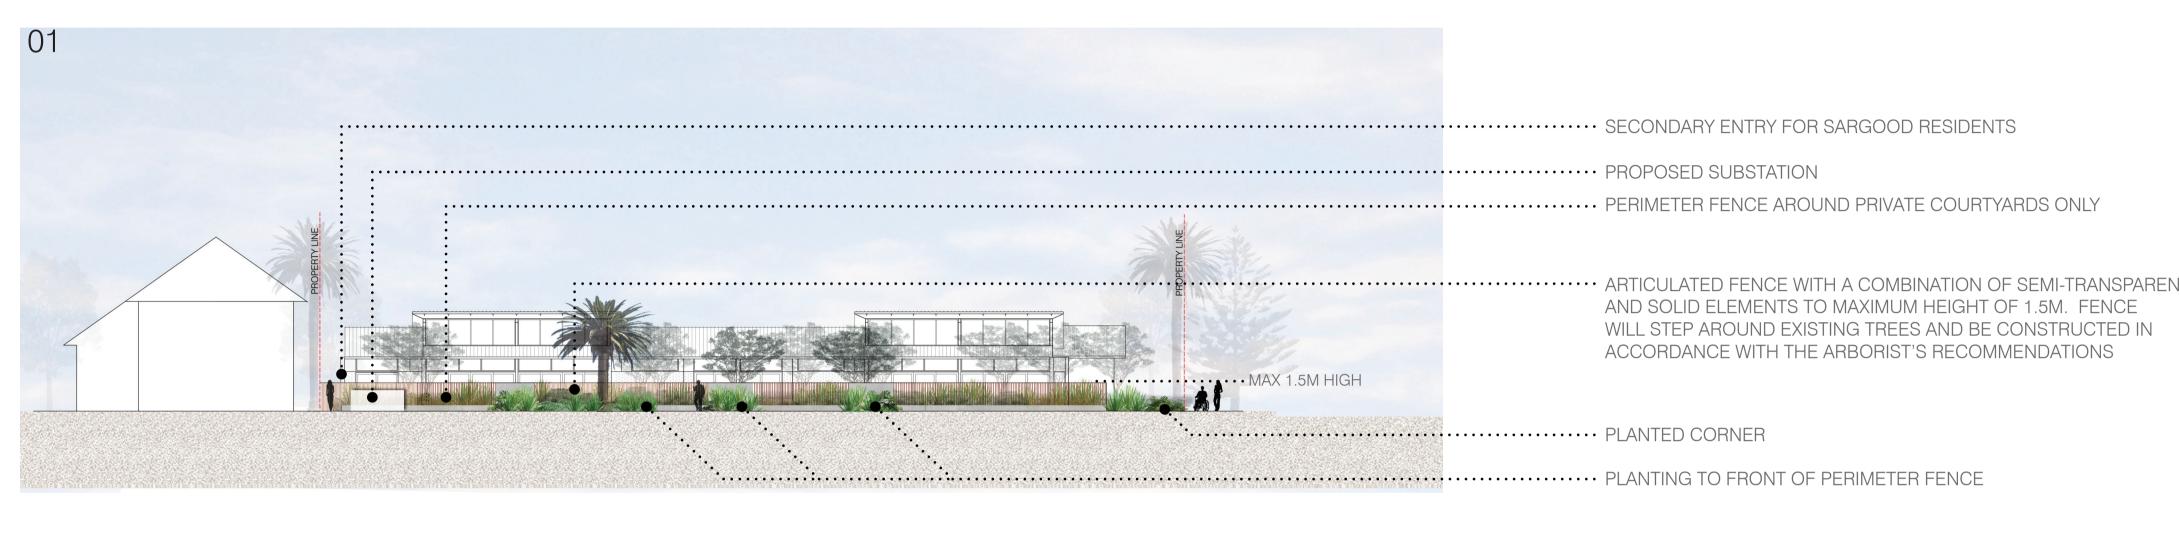

SOUTHERN FACADE ELEVATION



EASTERN FACADE ELEVATION

PRIVATE COURTYARDS ONLY

Banksia integrifolia

MAXIMUM HEIGHT OF 1.5M. FENCE WILL STEP AROUND EXISTING TREES AND BE CONSTRUCTED IN ACCORDANCE WITH THE ARBORIST'S RECOMMENDATIONS

REFER TO ARBORIST'S REPORT

AND PUBLICLY ACCESSIBLE PRIVATE LAND

...... LOW GATE TO DEFINE THE SARGOOD CENTRE



KEY

PRIVATE COURTYARD PLANTING


CENTRAL COURTYARD

BUFFER PLANTING

NORTHERN BOUNDARY + COMMUNAL LOUNGE


PLANTING KEY PLAN

NTS

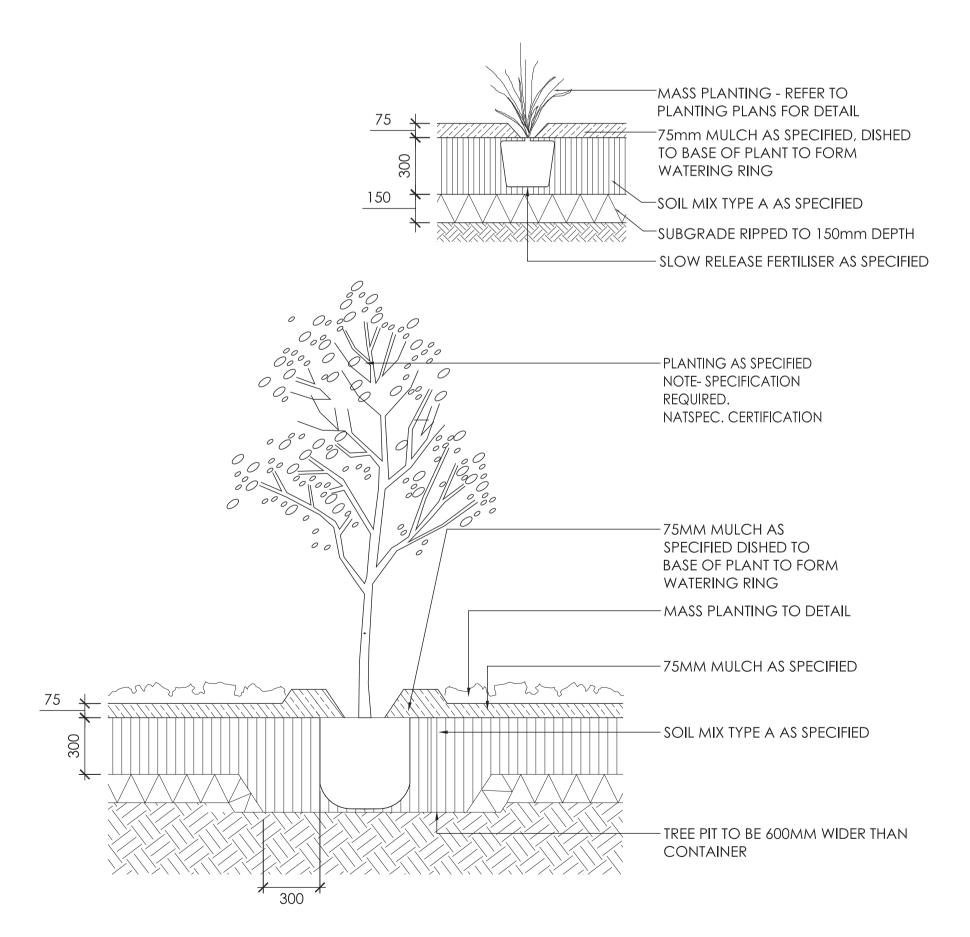

INDICATIVE PRIVATE COURTYARD PLANTING PLAN

SPECIES COMMON NAME SPACING SIZE 2 x MATURE REPLACEMENT TREE SPECIES Banksia integrifolia Coast Banksia COURTYARD TREE SPECIES N/A Pandanus tectorius Screw Pine PERENNIALS & GROUNDCOVERS Renga Renga Lily Arthropodium cirratum 6.25/m2 Birds Nest Fern Asplenium australasicum N/A Cordyline australis 'Purpurea' Purple Cordyline N/A Hymenocallis speciosa Spider Lily 4/m2 Phormium cookianum N.Z. Flax 4/m2 Sedum atropurpureum Sedum 11/m2 Scaevola aemula Fan Flower 6.25/m2 Strelitzia reginae var. juncea Bird of Paradise 2/m2 Viola hederacea Native Violet 3.25/m2 Westringia fruticosa Coastal Rosemary 4/m2

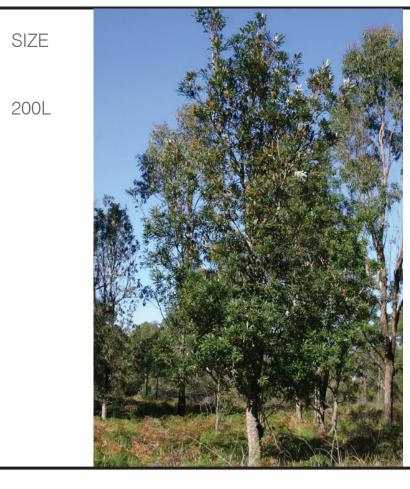









INDICATIVE CENTRAL COURTYARD PLANTING PLAN

Species Spacing Common name TREE SPECIES Old Man Banksia N/A Banksia serrata PERENNIALS & GROUNDCOVERS

Casuarina 'Cousin It' Prostrate Casuarina 11/m2 Myoporum parvifolium Creeping Boobialla 6.25/m2 Pratia pedunculata Pratia 11/m2 Mondo Grass Ophiopogan japonicus 11/m2











INDICATIVE NORTHERN BOUNDARY ROOF PLANTING PLAN

Species PERENNIALS & GROUNDCOVERS	Common name	Massing
•		Massing 11/m2 11/m2 4/m2 11/m2 11/m2 11/m2 11/m2 11/m2 11/m2
Kalanchoe orgyalis 'Cooper Spoon Myoporum parvifolium Sedum 'Gold Mound' Senecio mandraliscae	'Cooper Spoons Creeping Boobialla Giant Bugle Blue Chalk Sticks	11/m2 6.25/m2 11/m2 6.25/m2















Species	Common name	Massing
TREE SPECIES Banksia serrata Leptospermum laevigatum	Old Man Banksia Tea Tree	N/A N/A
SHRUB SPECIES Banksia ericifolia Westringia fruticosa	Heath Banksia Coastal Rosemary	1/m2 4/m2

PERENNIALS & GROUNDCOVERS Blechnum cartilagineum Rasp Fern 6.25/m2 Native Pig Face Carpobrotus glaucescens 4/m2 Gymea Lily Doryanthes excelsea 1/m2 Hibbertia scandens Snake Vine 2/m2 Happy Wanderer 2/m2 Hardenbergia violacea Knobby Club Rush 6.25/m2 Isolepsis nodosa






















SURFACES TREATMENT TYPICAL DETAILS

1:20

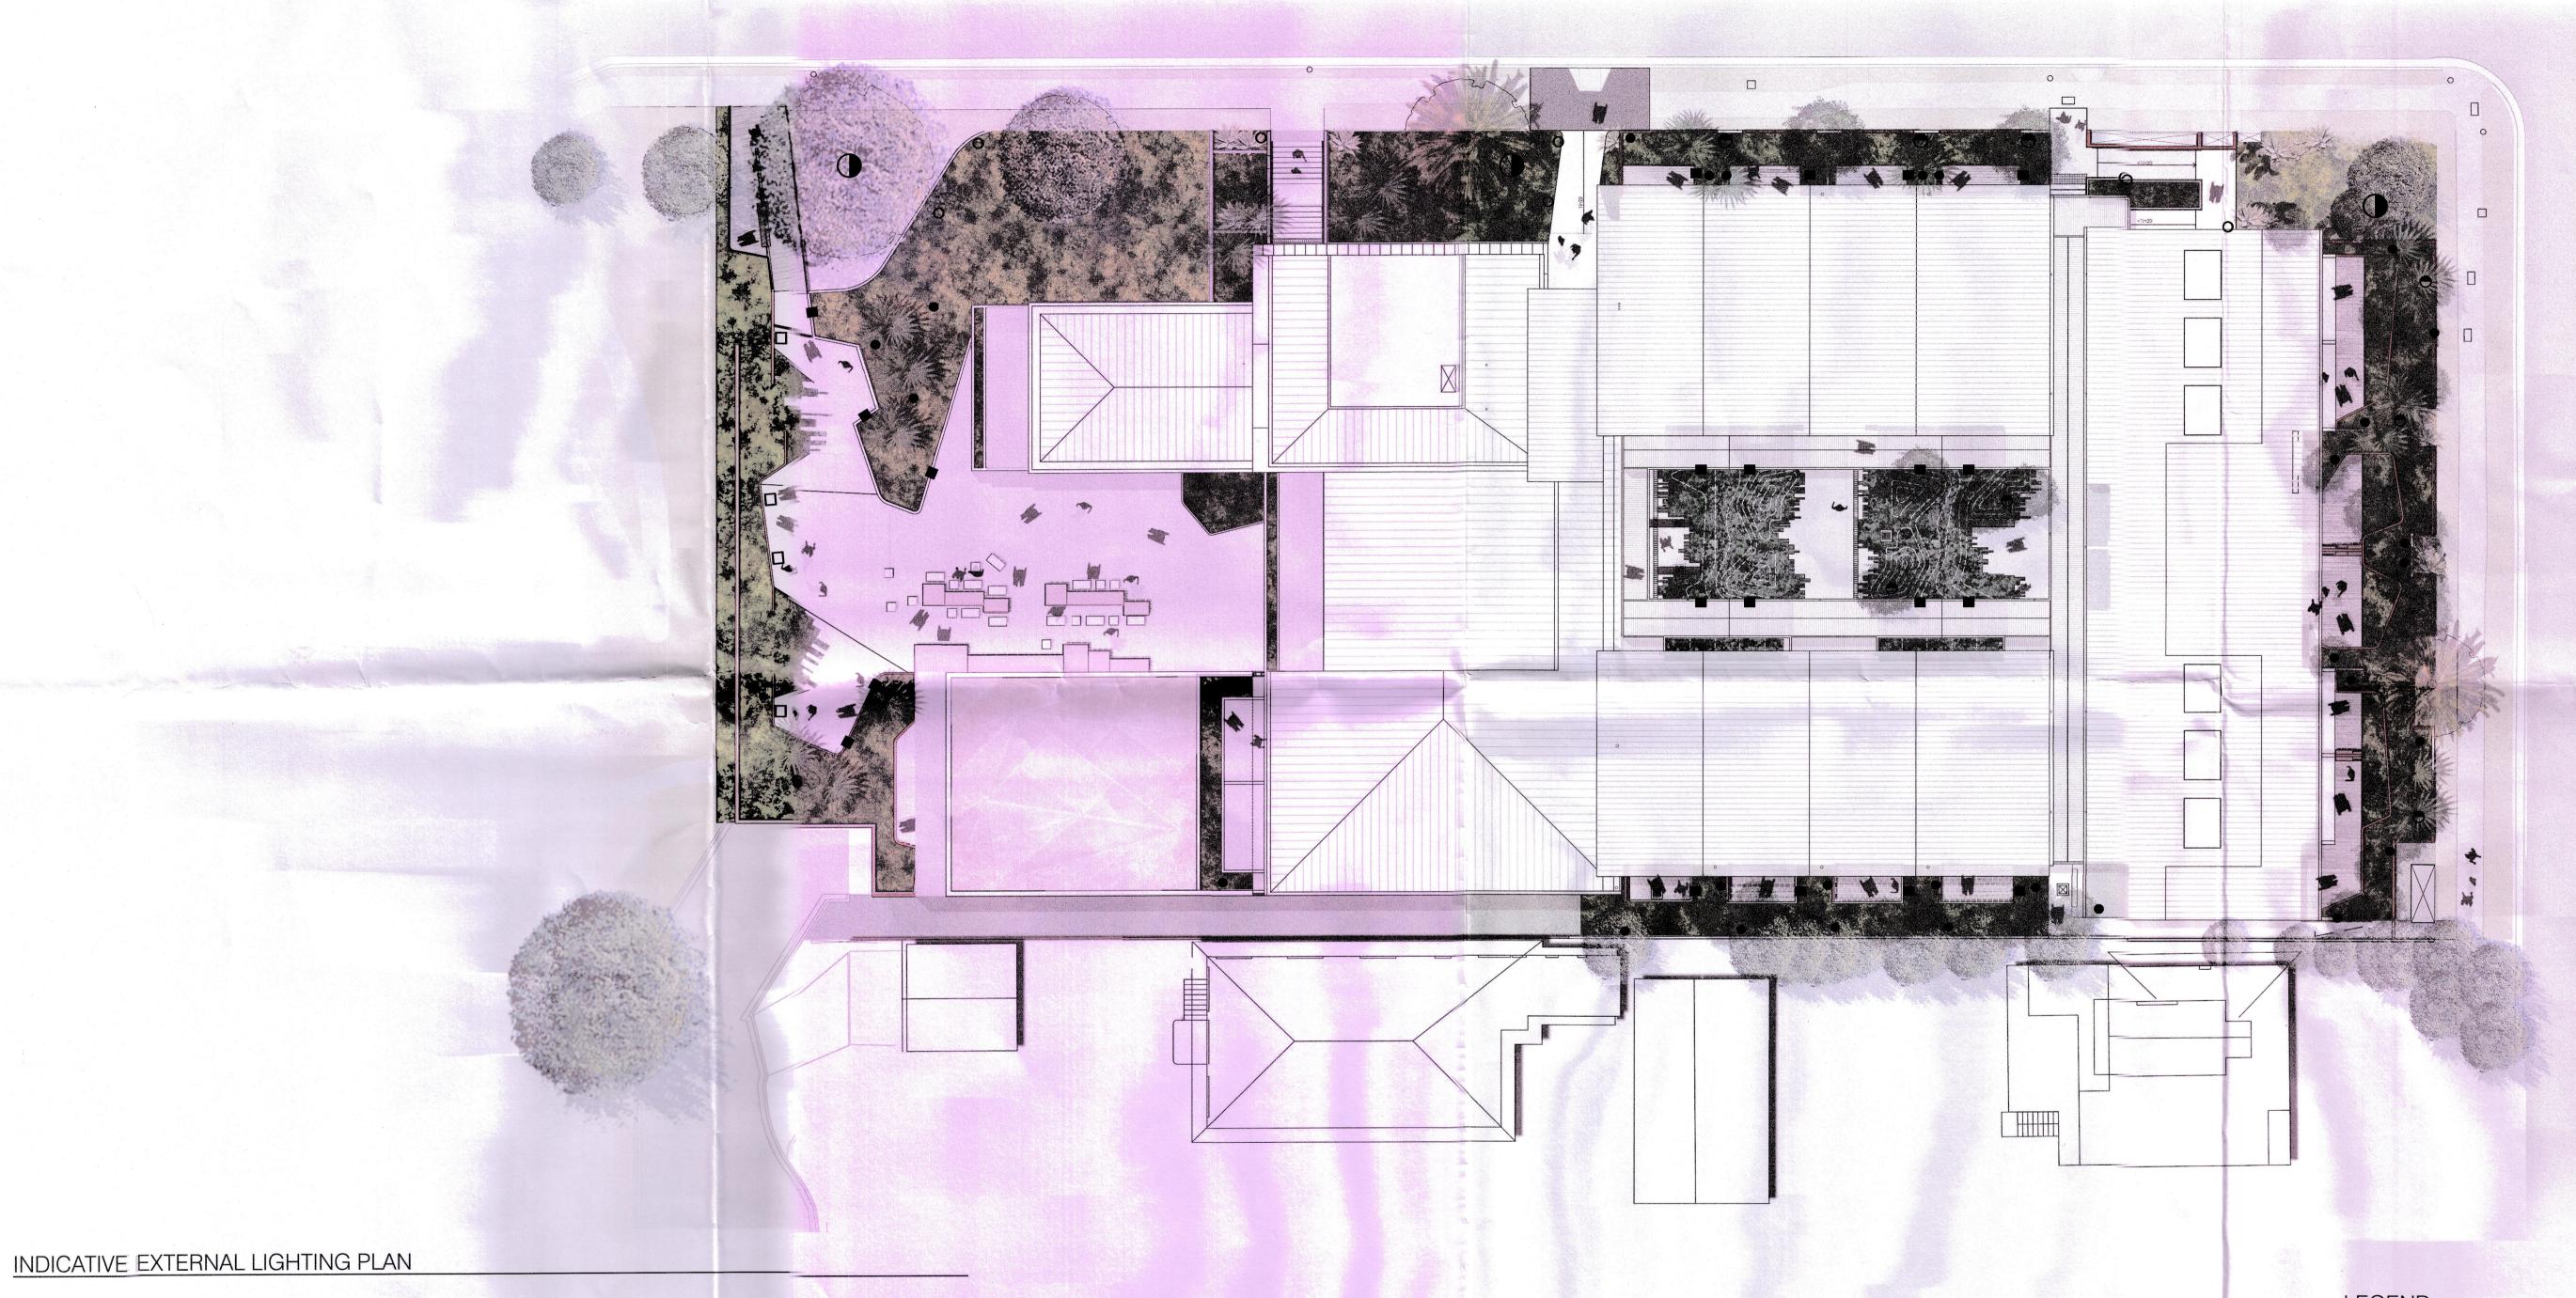

LEGEND

- ON-GROUND FLOODLIGHT (PUBLIC)
 ON-GROUND FLOODLIGHT (PRIVATE)
 LED GARDEN LUMINAIRES WITH EARTH SPIKE
- O LED GARDEN AND PATH LUMINAIRES
- STRIP LED LIGHT TO EGDE OF DECK

 RECTANGULAR IN-GROUND LUMINAIRES · IN EXTERNAL WALL
 RECTANGULAR IN-GROUND LUMINAIRES · IN GROUND