DRAWING NO.	DRAWING TITLE		EVISION	SCALE	
00 REFERENCE			<u> </u>		
0000	COVER PAGE	<u></u>	В		
1 SITE & LOCATION					
1000	SITE PLAN_EXISTING & DEMOLITION	>	В	1:100	
1001	SITE PLAN_PROPOSED	<u> </u>	В	1:100	
11 COMPLIANCE					
1100	GFA/FSR PLAN_CONTROL	$\rightarrow$	В	1:100	
1101	LANDSCAPED AREA/OPEN SPACE AREA CONTROL		В	1:100	
1102	MAX HEIGHT PLANE_CONTROL		В	1:50	
1103	MAX HEIGHT PLANE_CONTROL EXISTING		В		
1104	MAX SHEAR WALL_CONTROL		В	1:50	
1105	MAX SHEAR WALL_CONTROL EXISTING	$\rightarrow$	В		
1106	NOTIFICATION PLAN		В	1:200	
20 GA PLAN_EXISTIN					
2000	BASEMENT - GENERAL ARRANGEMENT PLAN - EXISTING & DEMOLITION	<u> </u>	В	1:50	
2001	LOWER GROUND FLOOR - GENERAL ARRANGEMENT PLAN - EXISTING & DEMOLITION		В	1:50	
2002	GROUND FLOOR - GENERAL ARRANGEMENT PLAN - EXISTING & DEMOLITION		В	1:50	
2003	FIRST FLOOR - GENERAL ARRANGEMENT PLAN - EXISTING & DEMOLITION	$\rightarrow$	В	1:50	
2004	ROOF - GENERAL ARRANGEMENT PLAN - EXISTING & DEMOLITION		В	1:50	
 21 GA PLAN_PROPO		$\rightarrow$			
2100	BASEMENT - GENERAL ARRANGEMENT PLAN - PROPOSED		В	1:50	
2101	LOWER GROUND FLOOR - GENERAL ARRANGEMENT PLAN - PROPOSED		В	1:50	
2102	GROUND FLOOR - GENERAL ARRANGEMENT PLAN - PROPOSED		В	1:50	
2103	FIRST FLOOR - GENERAL ARRANGEMENT PLAN - PROPOSED		В	1:50	
2104	ROOF - GENERAL ARRANGEMENT PLAN - PROPOSED	$\rightarrow$	В	1:50	
31 GA ELEVATIONS_					
3000	GENERAL ARRANGEMENT - ELEVATION E01 _PROPOSED		В	1:50	
3001	GENERAL ARRANGEMENT - ELEVATION E02 PROPOSED		В	1:50	
3002	GENERAL ARRANGEMENT - ELEVATION E03 PROPOSED		В	1:50	
3003	GENERAL ARRANGEMENT - ELEVATION E04 _PROPOSED		В	1:50	
32 SITE ELEVATIONS					
3100	SITE ELEVATIONS - ELEVATION E05 _PROPOSED		В	1:100	
3101	SITE ELEVATIONS - ELEVATION E06 & E08 _ PROPOSED		В	1:100	
3102	SITE ELEVATIONS - ELEVATION E07 PROPOSED		В	1:100	
41 GA SECTIONS_PR	<del>_</del>				
4100	GENERAL ARRANGEMENT - SECTION 01 PROPOSED		В	1:50	
4101	GENERAL ARRANGEMENT - SECTION 02 PROPOSED		В	1:50	
4102	GENERAL ARRANGEMENT - SECTION 03_ PROPOSED		В	1:50	
4103	GENERAL ARRANGEMENT - SECTION 04 & 05 PROPOSED		В	1:50	
42 GA SECTIONS_SI	<del>-</del>				
4200	SITE SECTIONS - SECTION S06_PROPOSED		В	1:100	
80 VISUALS & MATE		<u> </u>			
8000	MATERIAL PALETTE		В		
0000		$\rightarrow$			
	M	1			
1 SHADOW DIAGRA			В	1:100	
8100 81 SHADOW DIAGRA 8100 8101	SHADOW DIAGRAMS 21 JUNE 9AM SHADOW DIAGRAMS 21 JUNE 12PM		B B	1:100 1:100	



ATHR

CS
KK

1. ALL WORKS TO BE IN ACCORDANCE WITH THE NATIONAL CONSTRUCTION CODE, AUSTRALIAN STANDARDS AND LOCAL AUTHORITY REQUIREMENTS, INCLUDING COUNCIL CONDITIONS OF CONSENT

2. DO NOT SCALE OFF THIS DRAWING. USE ONLY DIMENSIONS PROVIDED

3. A&CO DRAWINGS ARE TO BE READ IN CONJUNCTION WITH ALL CONTRACT DOCUMENTS FROM ALL CONSULTANTS

4. ALL DIMENSIONS TO BE CHECKED ON SITE PRIOR TO THE COMMENCEMENT OF WORK DESCRIPTION FOR DA SUBMISSION FOR S4.55 SUBMISSION B 18/7/2024 DISCLAIMER:
THE COPYRIGHT OF THIS DRAWING TOGETHER WITH ANY DOCUMENTS PREPARED BY A&CO PTY. LTD REMAINS THE PROPERTY OF A&CO PTY. LTD. A&CO PTY. LTD GRANTS LICENCE FOR THE USE OF THIS DOCUMENT FOR THE PURPOSE FOR WHICH IT IS INTENDED. THE LICENCE IS NOT TRANSFERABLE WITHOUT THE PERMISSION OF A&CO PTY. LTD

ALEXANDER &CO.

ALEXANDER HOUSE
63 BRISBANE STREET, BONDI JUNCTION
NSW 2022

CLIENT:
TRACEY & JAMES
SMAIL

PROJECT: BOWER HOUSE 38 BOWER ST MANLY, NSW 2095

T +61 (02) 8394 9838 www.alexanderand.co ABN 11 162 041 929 NOMINATED ARCHITECT: **JEREMY BULL** NSW REGISTRATION NO. **7881** CLASS 2 DESIGN PRACTITIONER: JEREMY BULL | NUMBER DEP0001029

DRAWING TITLE COVER PAGE

> CHECKED **KK** PROJECT NO. - DWG NO.\_REV. **0567-0000-[B]**

# **DEMOLITION** ALL DEMOLITION WORK IN ACCORDANCE WITH THE NATIONAL CONSTRUCTION CODE OF AUSTRALIA. AUSTRALIAN STANDARDS, STATUTORY REGULATIONS AND LOCAL AUTHORITY REQUIREMENTS.

IN ACCORDANCE WITH DEVELOPMENT APPLICATION CONDITIONS ALL HAZARDOUS SUBSTANCES LOCATED ON SITE ARE TO BE IDENTIFIED IN A REPORT PREPARED IN ACCORDANCE WITH AS2601. THIS IS TO BE PREPARED BY A SUITABLY QUALIFIED COMPETENT PERSON AND SUBMITTED

TO THE PCA FOR APPROVAL AND SUBMISSION TO COUNCIL CONTRACTOR IS RESPONSIBLE FOR THE ORGANISATION OF AND PROVISION OF TEMPORARY SERVICES TO BE ABLE TO

INCLUDING BUT NOT LIMITED TO CEILING HEIGHTS AND DIMENSIONS BEFORE COMMENCING WORK ON SITE OR


CONTRACTOR TO ADVISE OF ANY INCONSISTENCIES TO DIMENSIONS SHOWN PRIOR TO ANY CONSTRUCTION; FINAL


PROPOSED ARCHITECTURAL PACKAGE & SPECIFICATIONS.


NEW WIRING THROUGHOUT.


CONSTRUCTION.

INDICATED

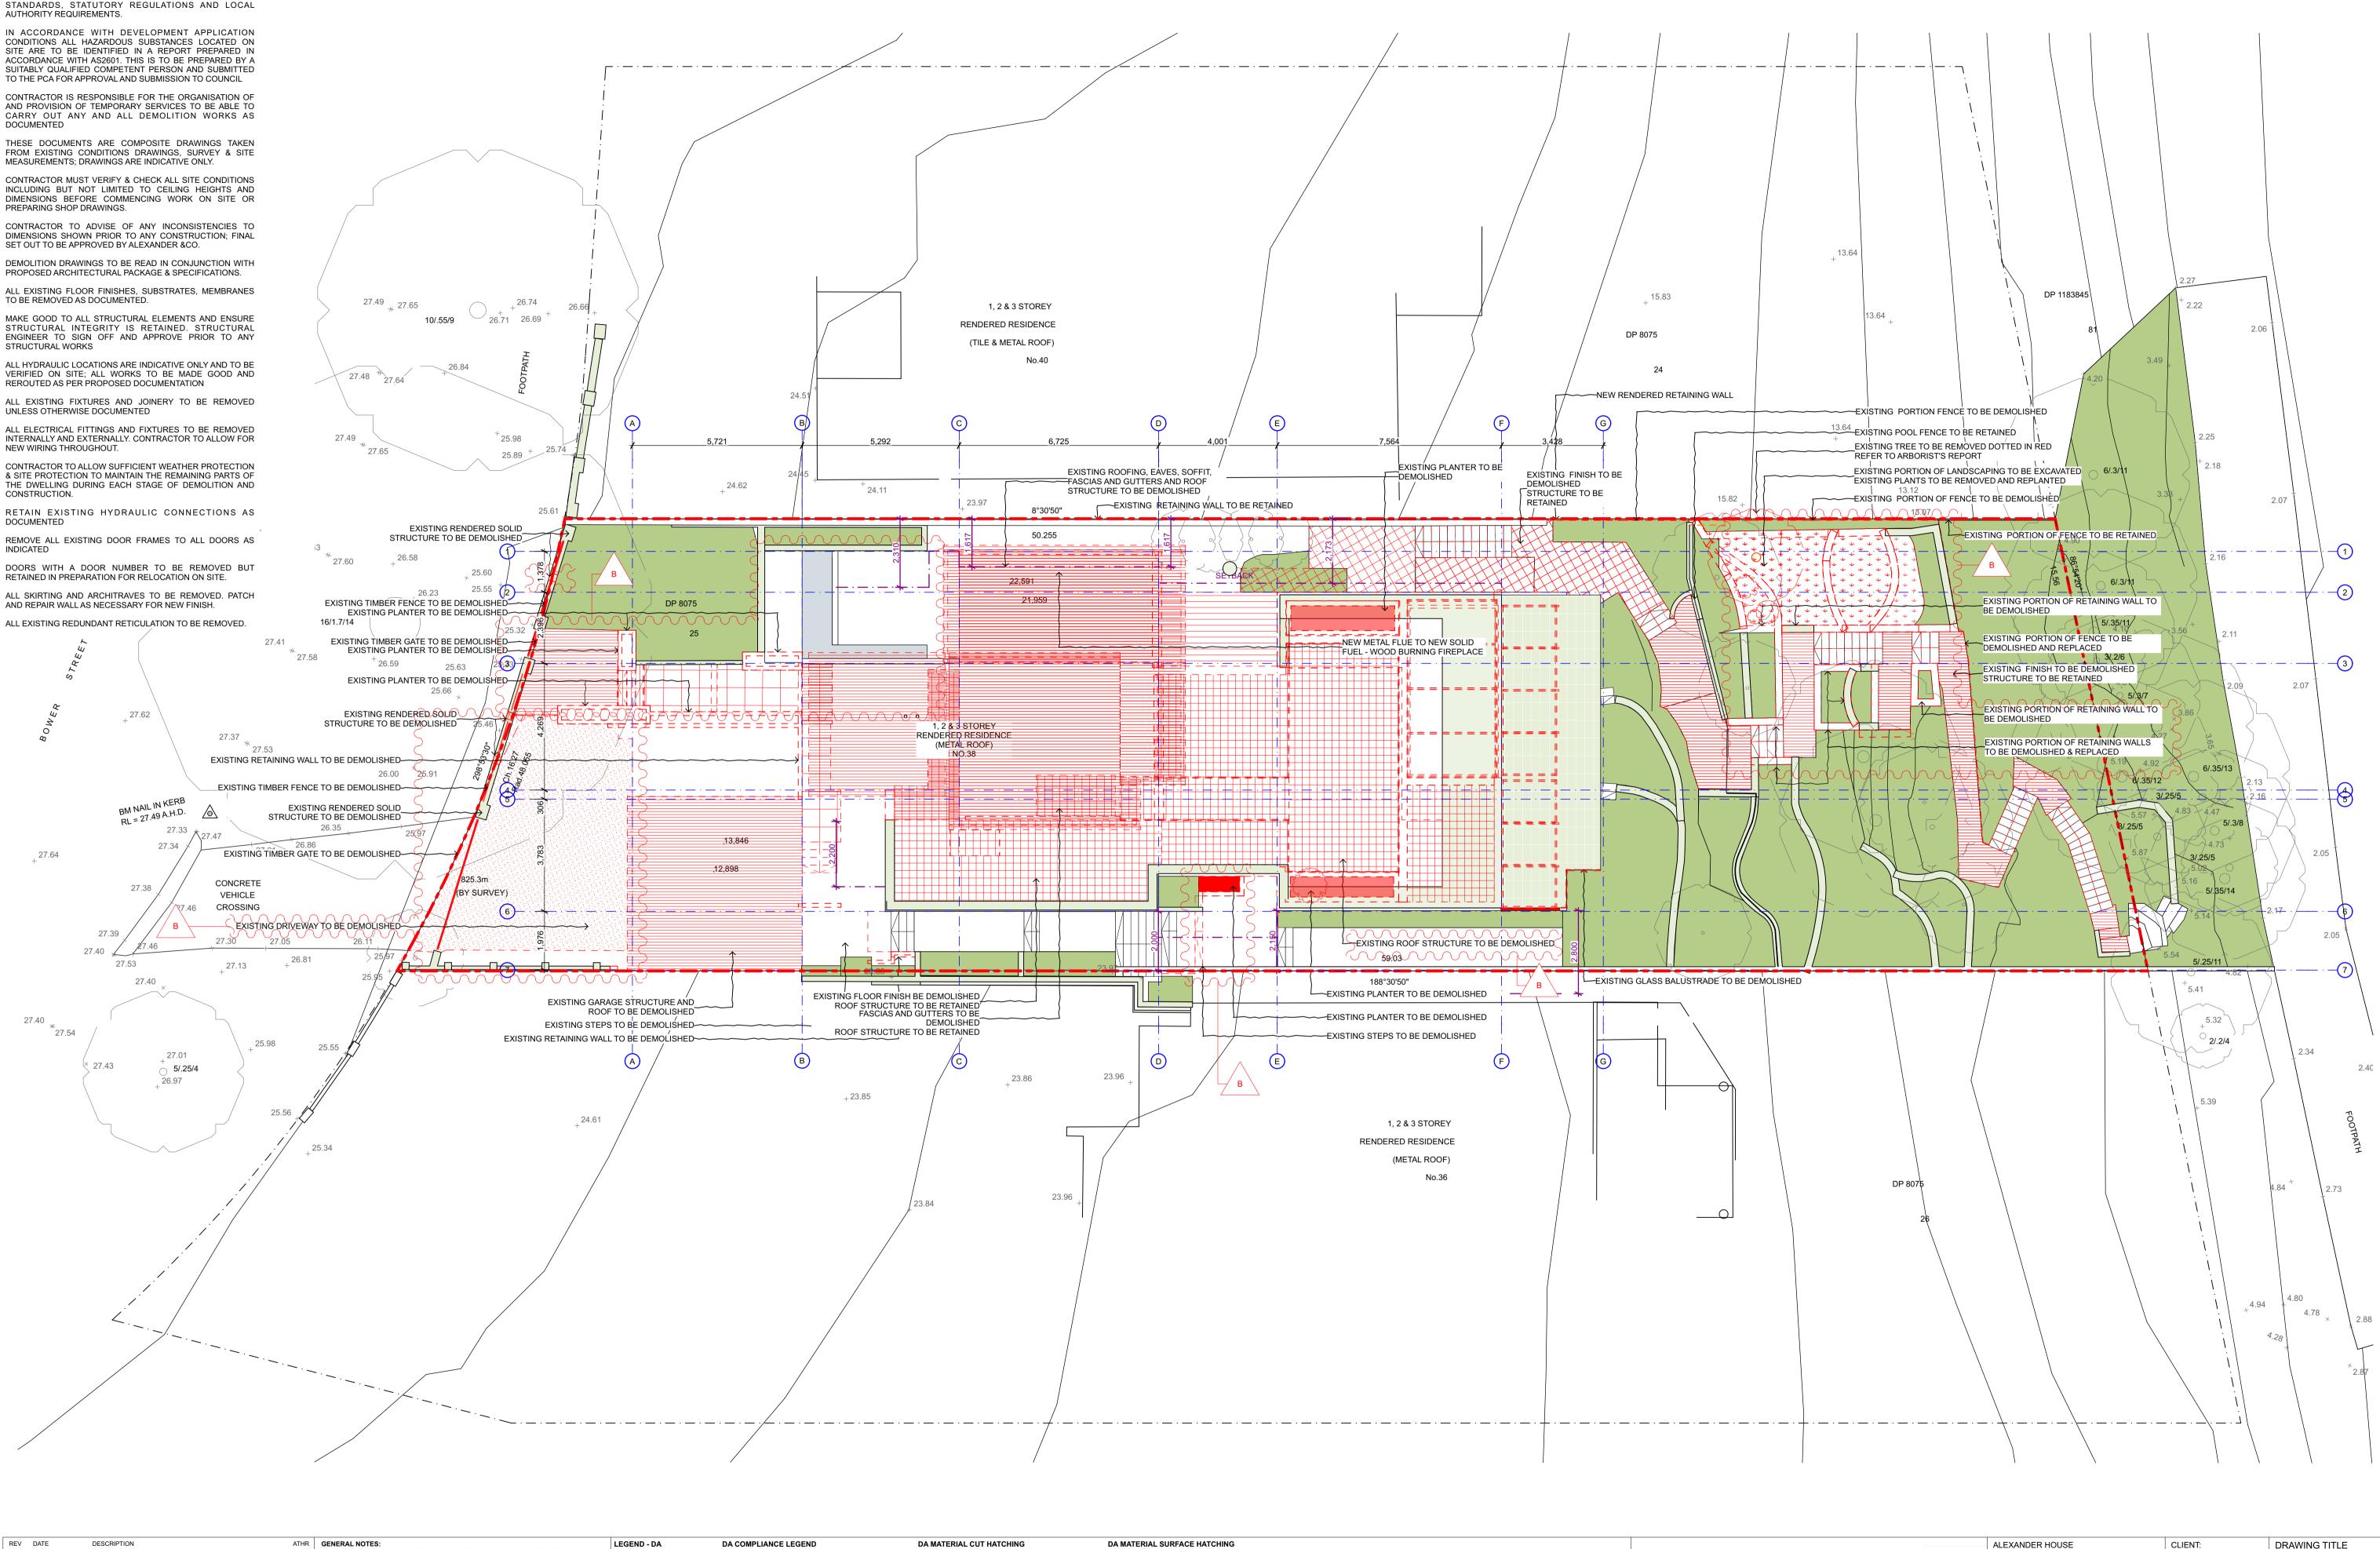

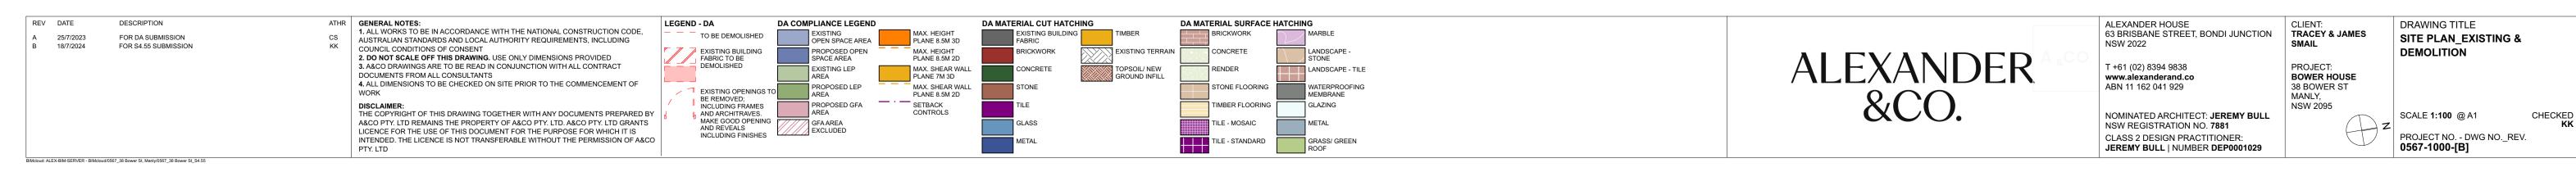


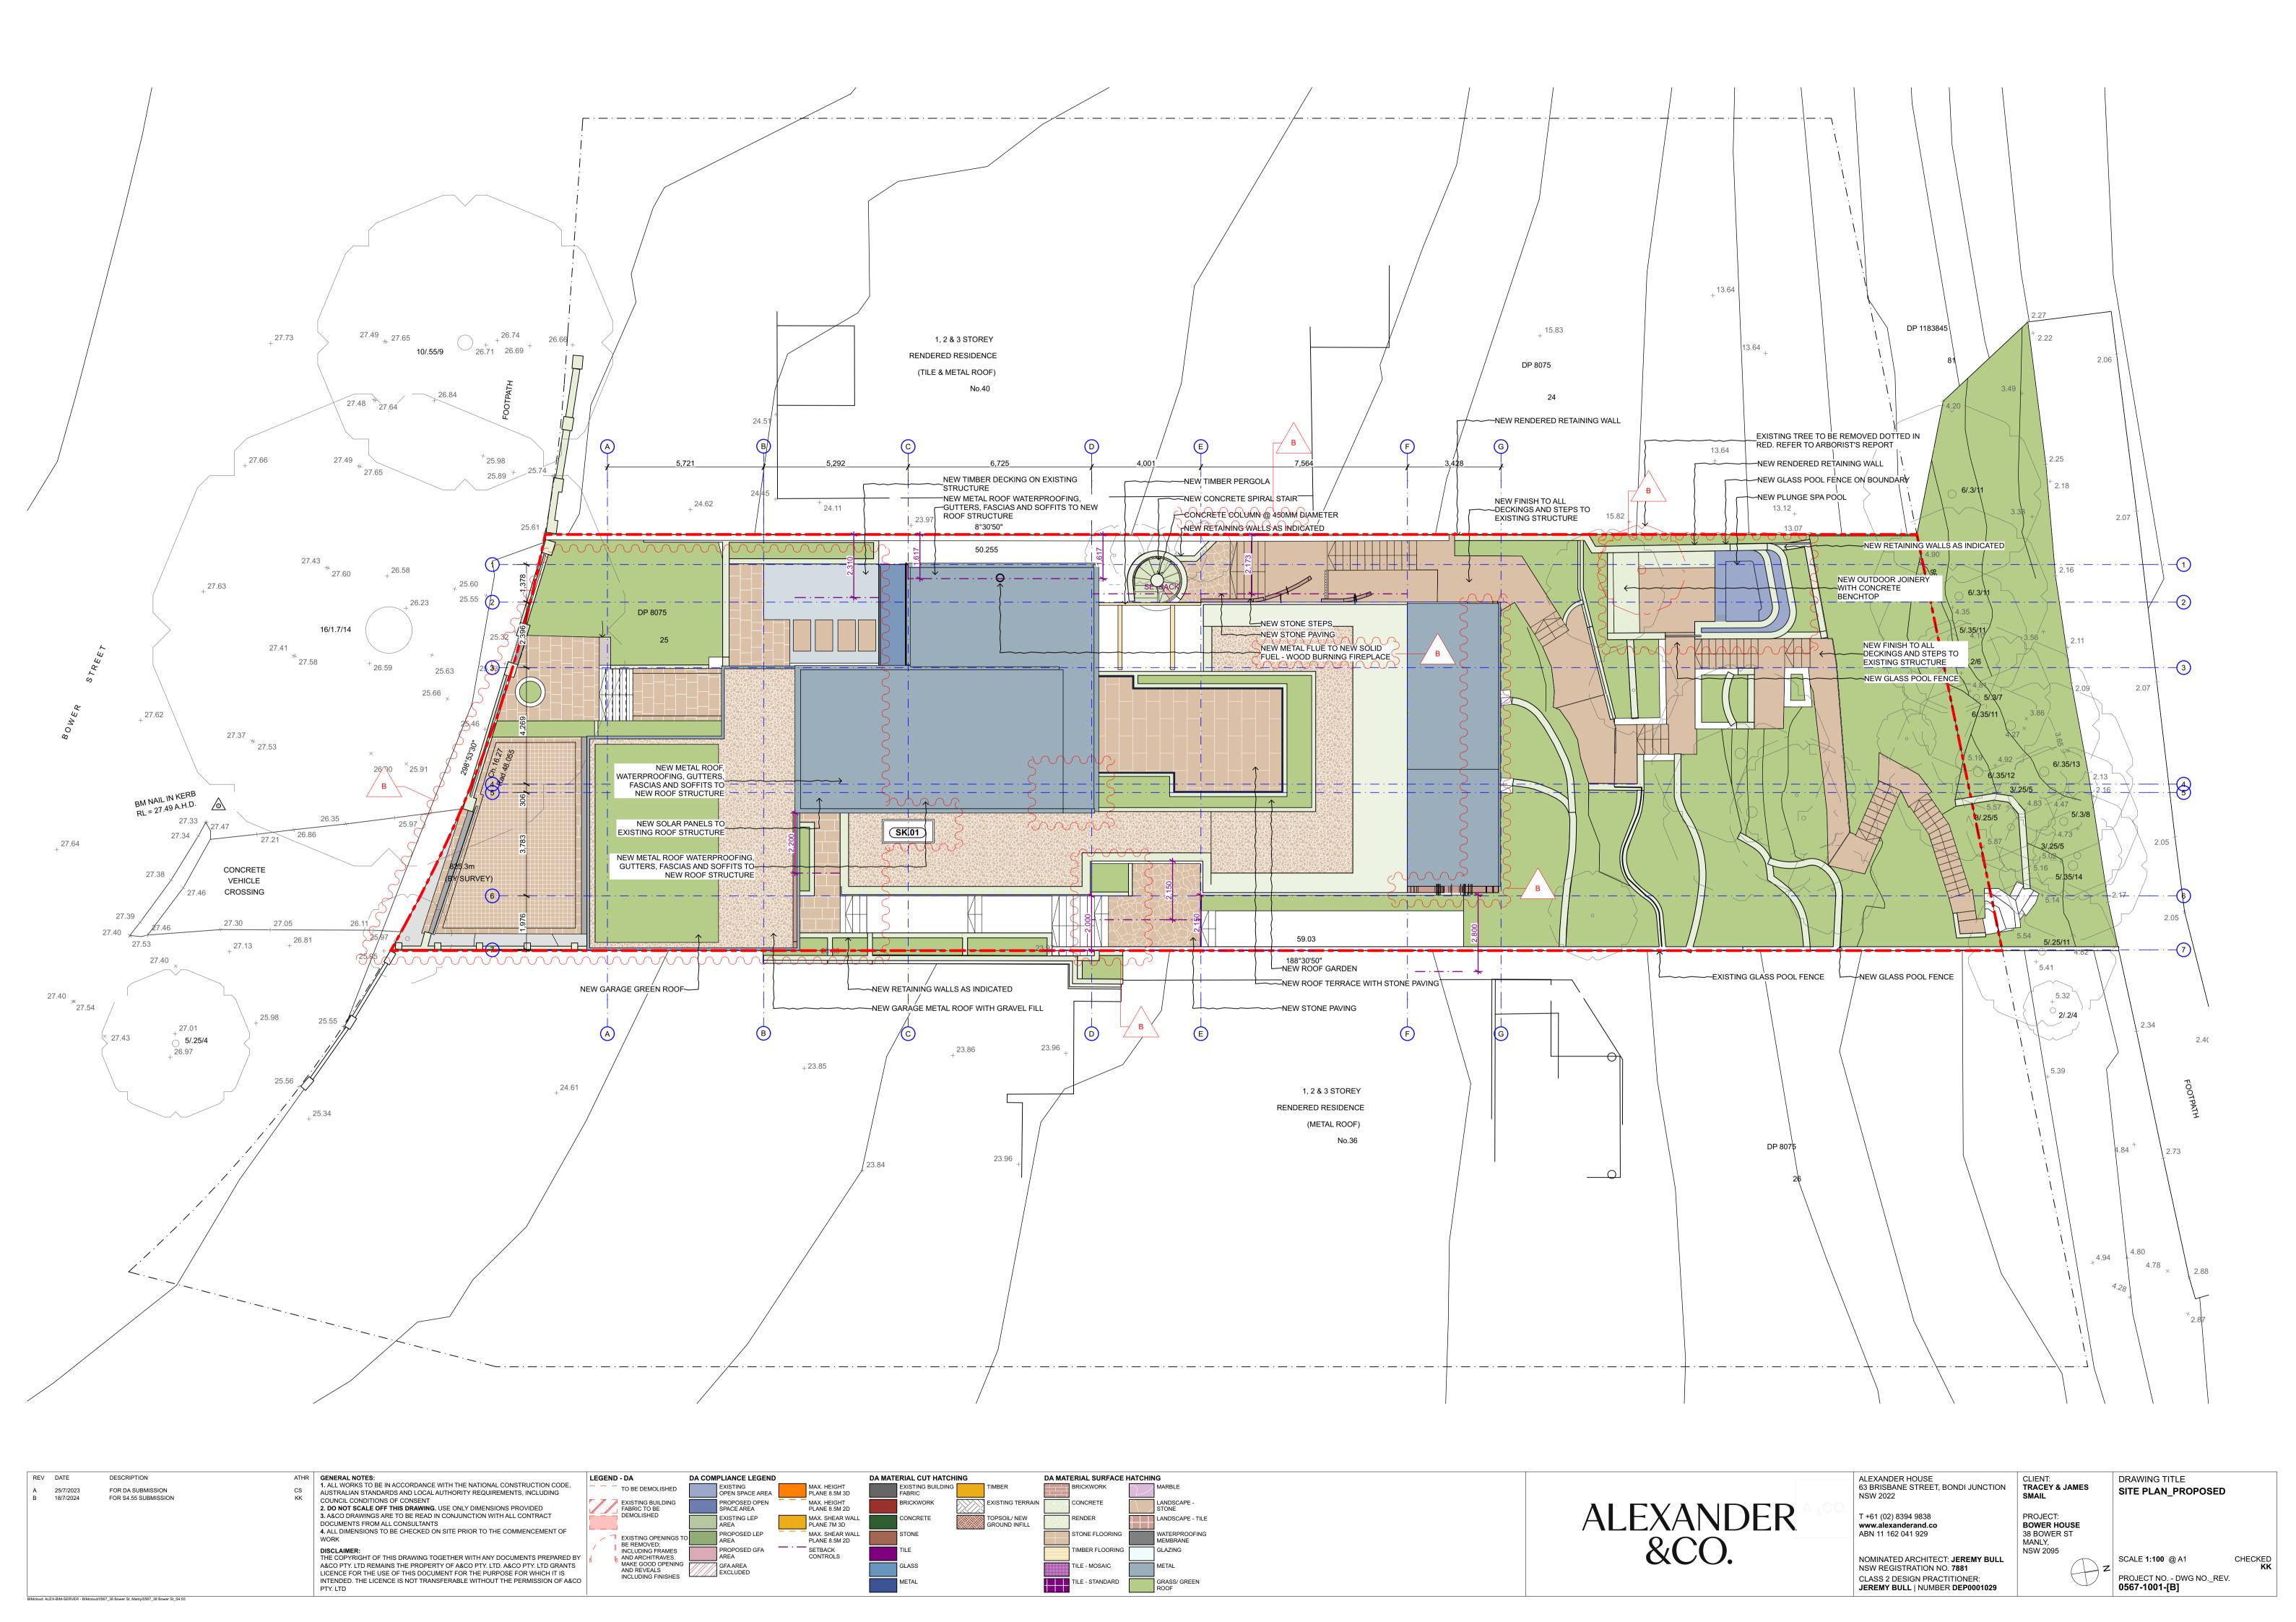

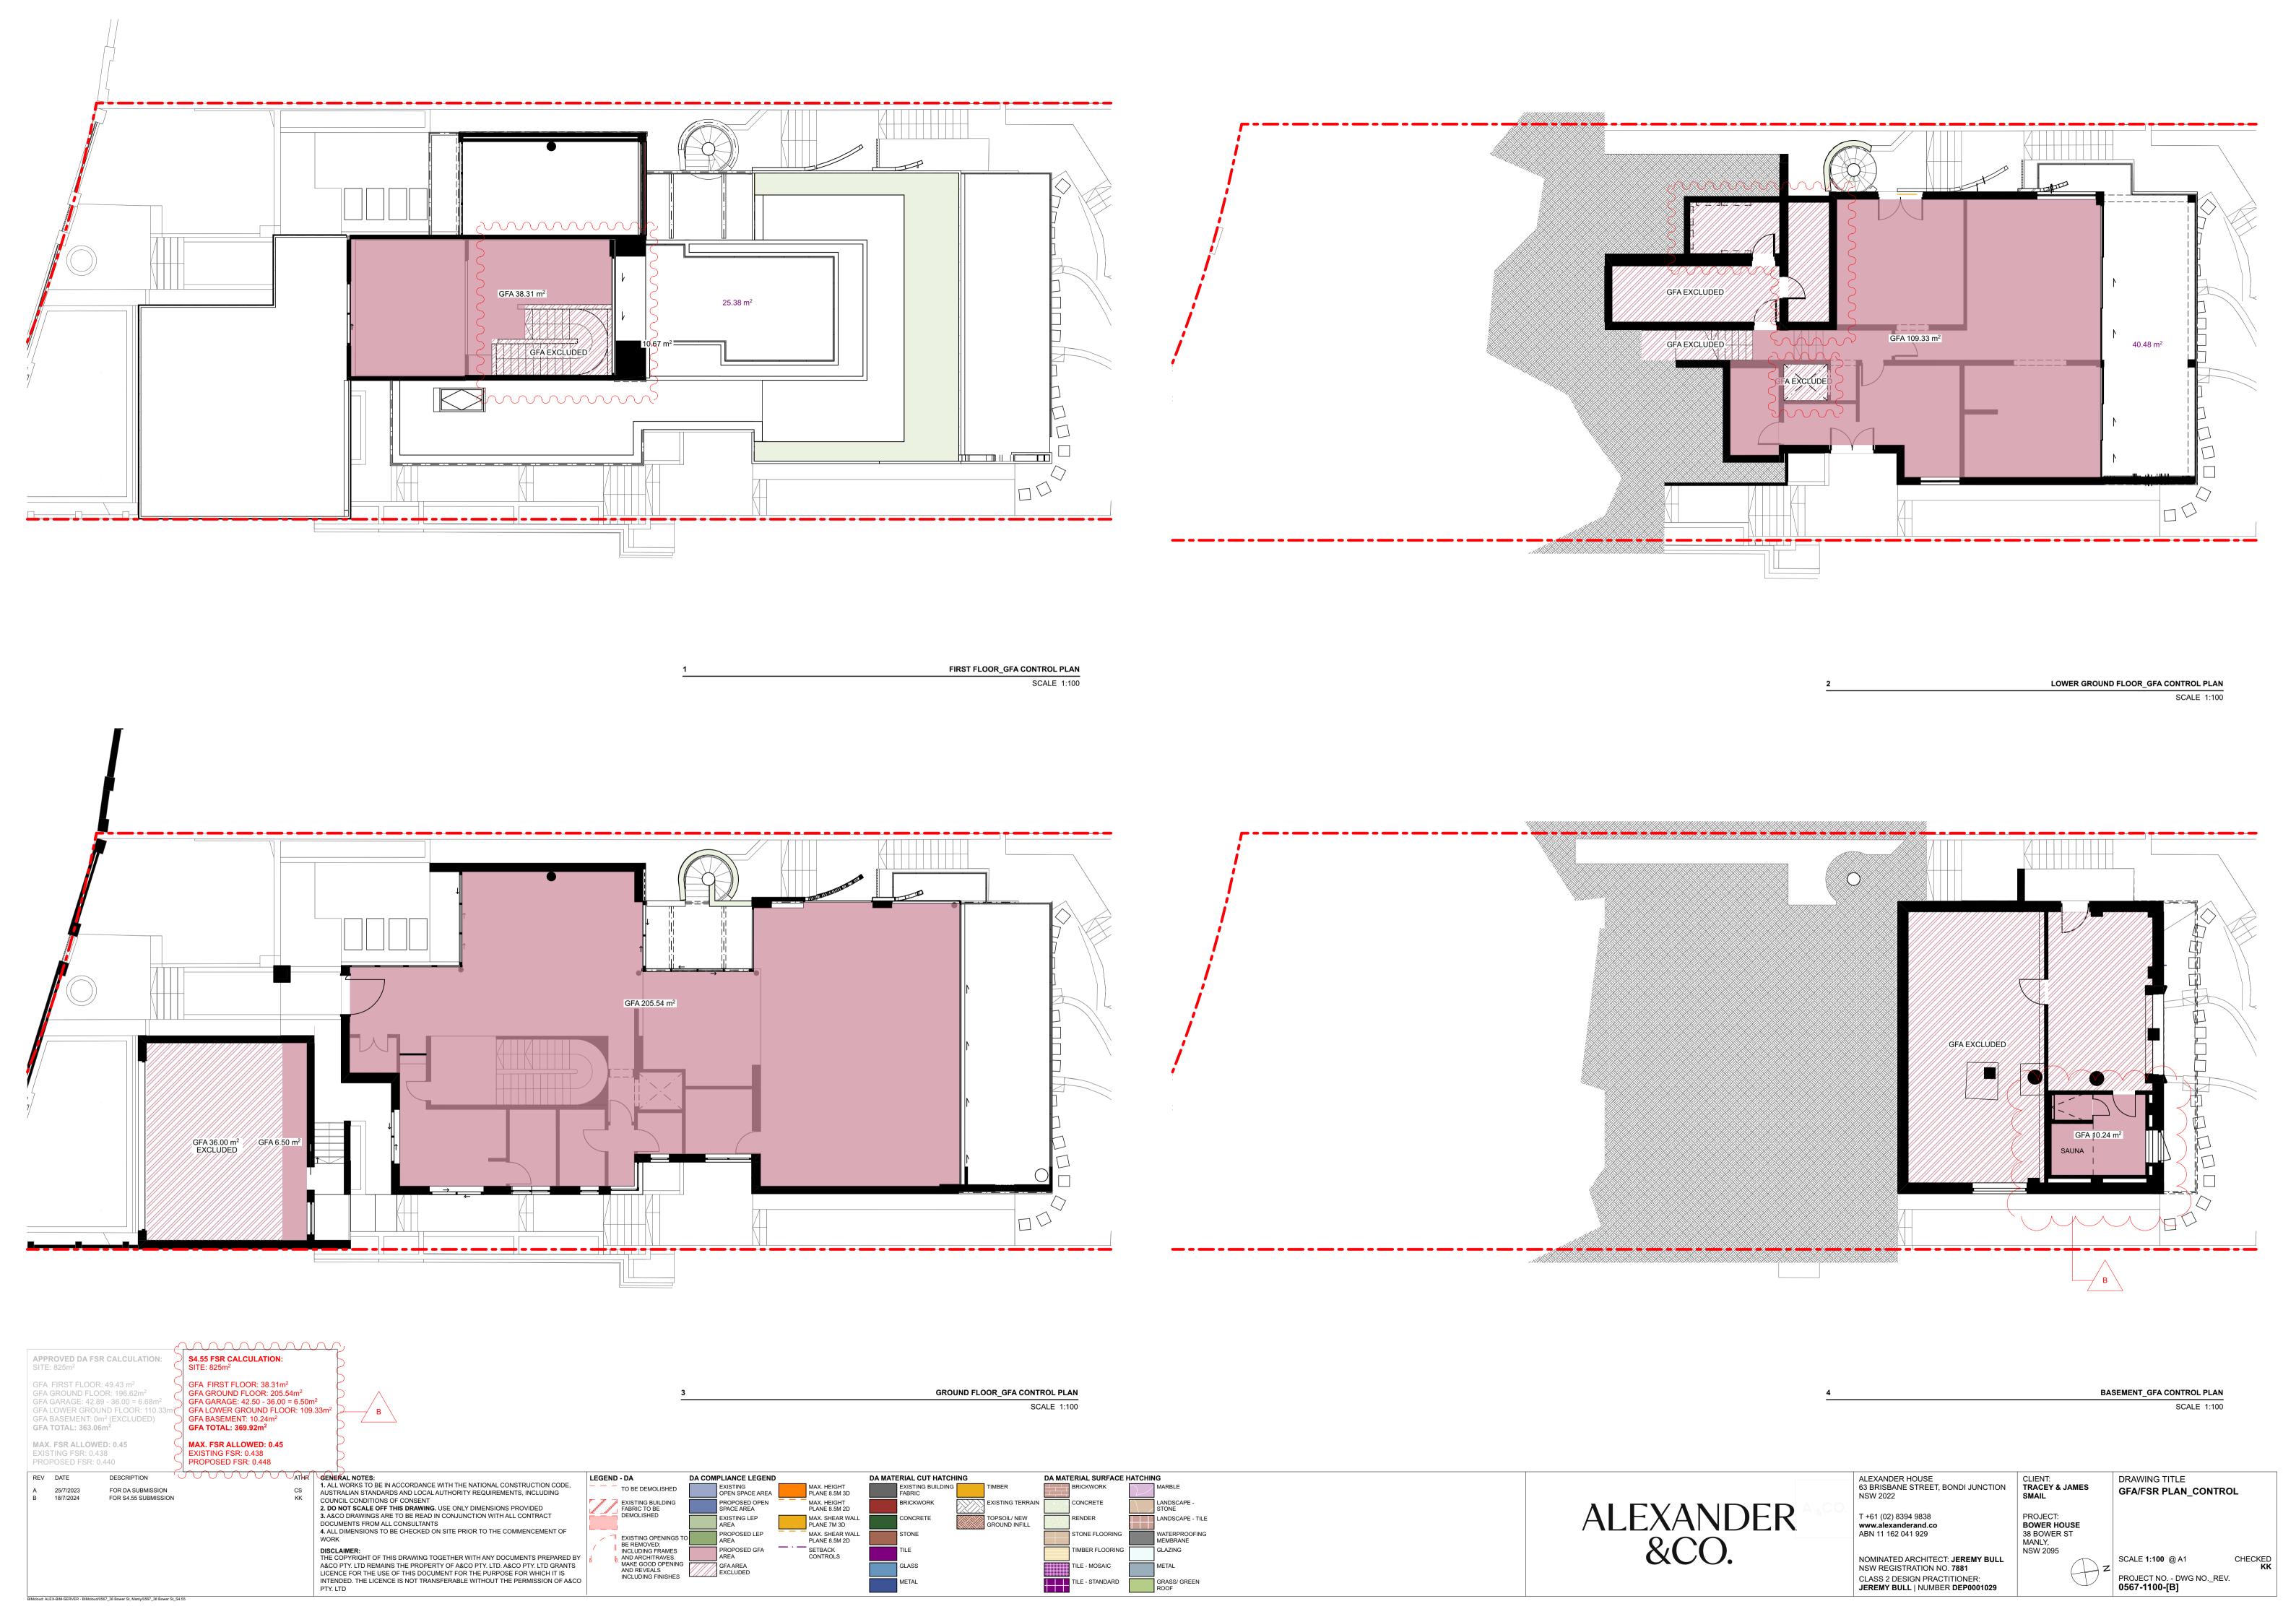







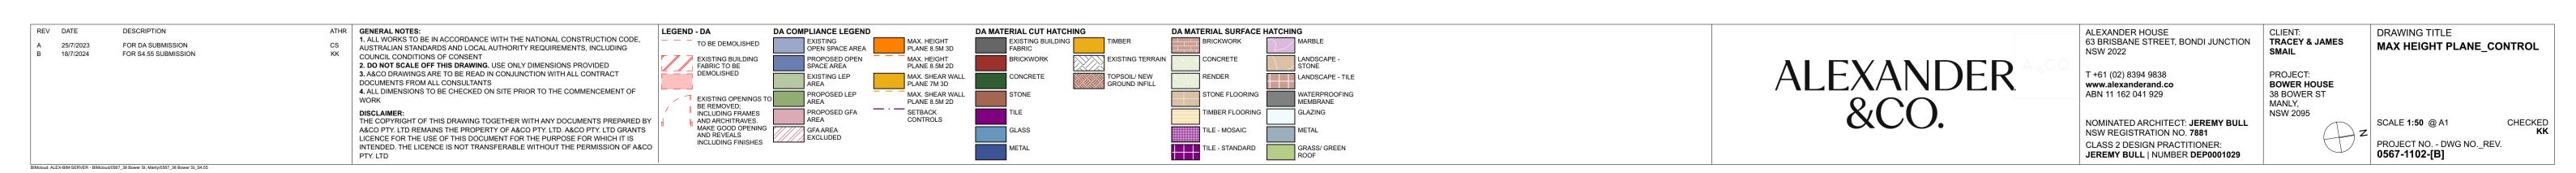



REV         DATE         DESCRIPTION           A         25/7/2023         FOR DA SUBMISSION           B         18/7/2024         FOR S4.55 SUBMISSION	ATHR GENERAL NOTES:  1. ALL WORKS TO BE IN ACCORDANCE WITH THE NATIONAL CONSTRUCTION CODE, AUSTRALIAN STANDARDS AND LOCAL AUTHORITY REQUIREMENTS, INCLUDING COUNCIL CONDITIONS OF CONSENT			CLIENT: TRACEY & JAMES SMAIL	DRAWING TITLE  MAX HEIGHT PLANE_CONTROL  EXISTING
	2. DO NOT SCALE OFF THIS DRAWING. USE ONLY DIMENSIONS PROVIDED 3. A&CO DRAWINGS ARE TO BE READ IN CONJUNCTION WITH ALL CONTRACT DOCUMENTS FROM ALL CONSULTANTS 4. ALL DIMENSIONS TO BE CHECKED ON SITE PRIOR TO THE COMMENCEMENT OF WORK	ALEXANDER	T +61 (02) 8394 9838 www.alexanderand.co ABN 11 162 041 929	PROJECT: BOWER HOUSE 38 BOWER ST MANLY.	LAIGHNO
	DISCLAIMER: THE COPYRIGHT OF THIS DRAWING TOGETHER WITH ANY DOCUMENTS PREPARED BY A&CO PTY. LTD REMAINS THE PROPERTY OF A&CO PTY. LTD. A&CO PTY. LTD GRANTS LICENCE FOR THE USE OF THIS DOCUMENT FOR THE PURPOSE FOR WHICH IT IS INTENDED. THE LICENCE IS NOT TRANSFERABLE WITHOUT THE PERMISSION OF A&CO	&CO.	NOMINATED ARCHITECT: JEREMY BULL NSW REGISTRATION NO. 7881 CLASS 2 DESIGN PRACTITIONER: JEREMY BULL   NUMBER DEP0001029	MANLY, NSW 2095	SCALE @ A1 CHECKED KK PROJECT NO DWG NOREV. 0567-1103-[B]

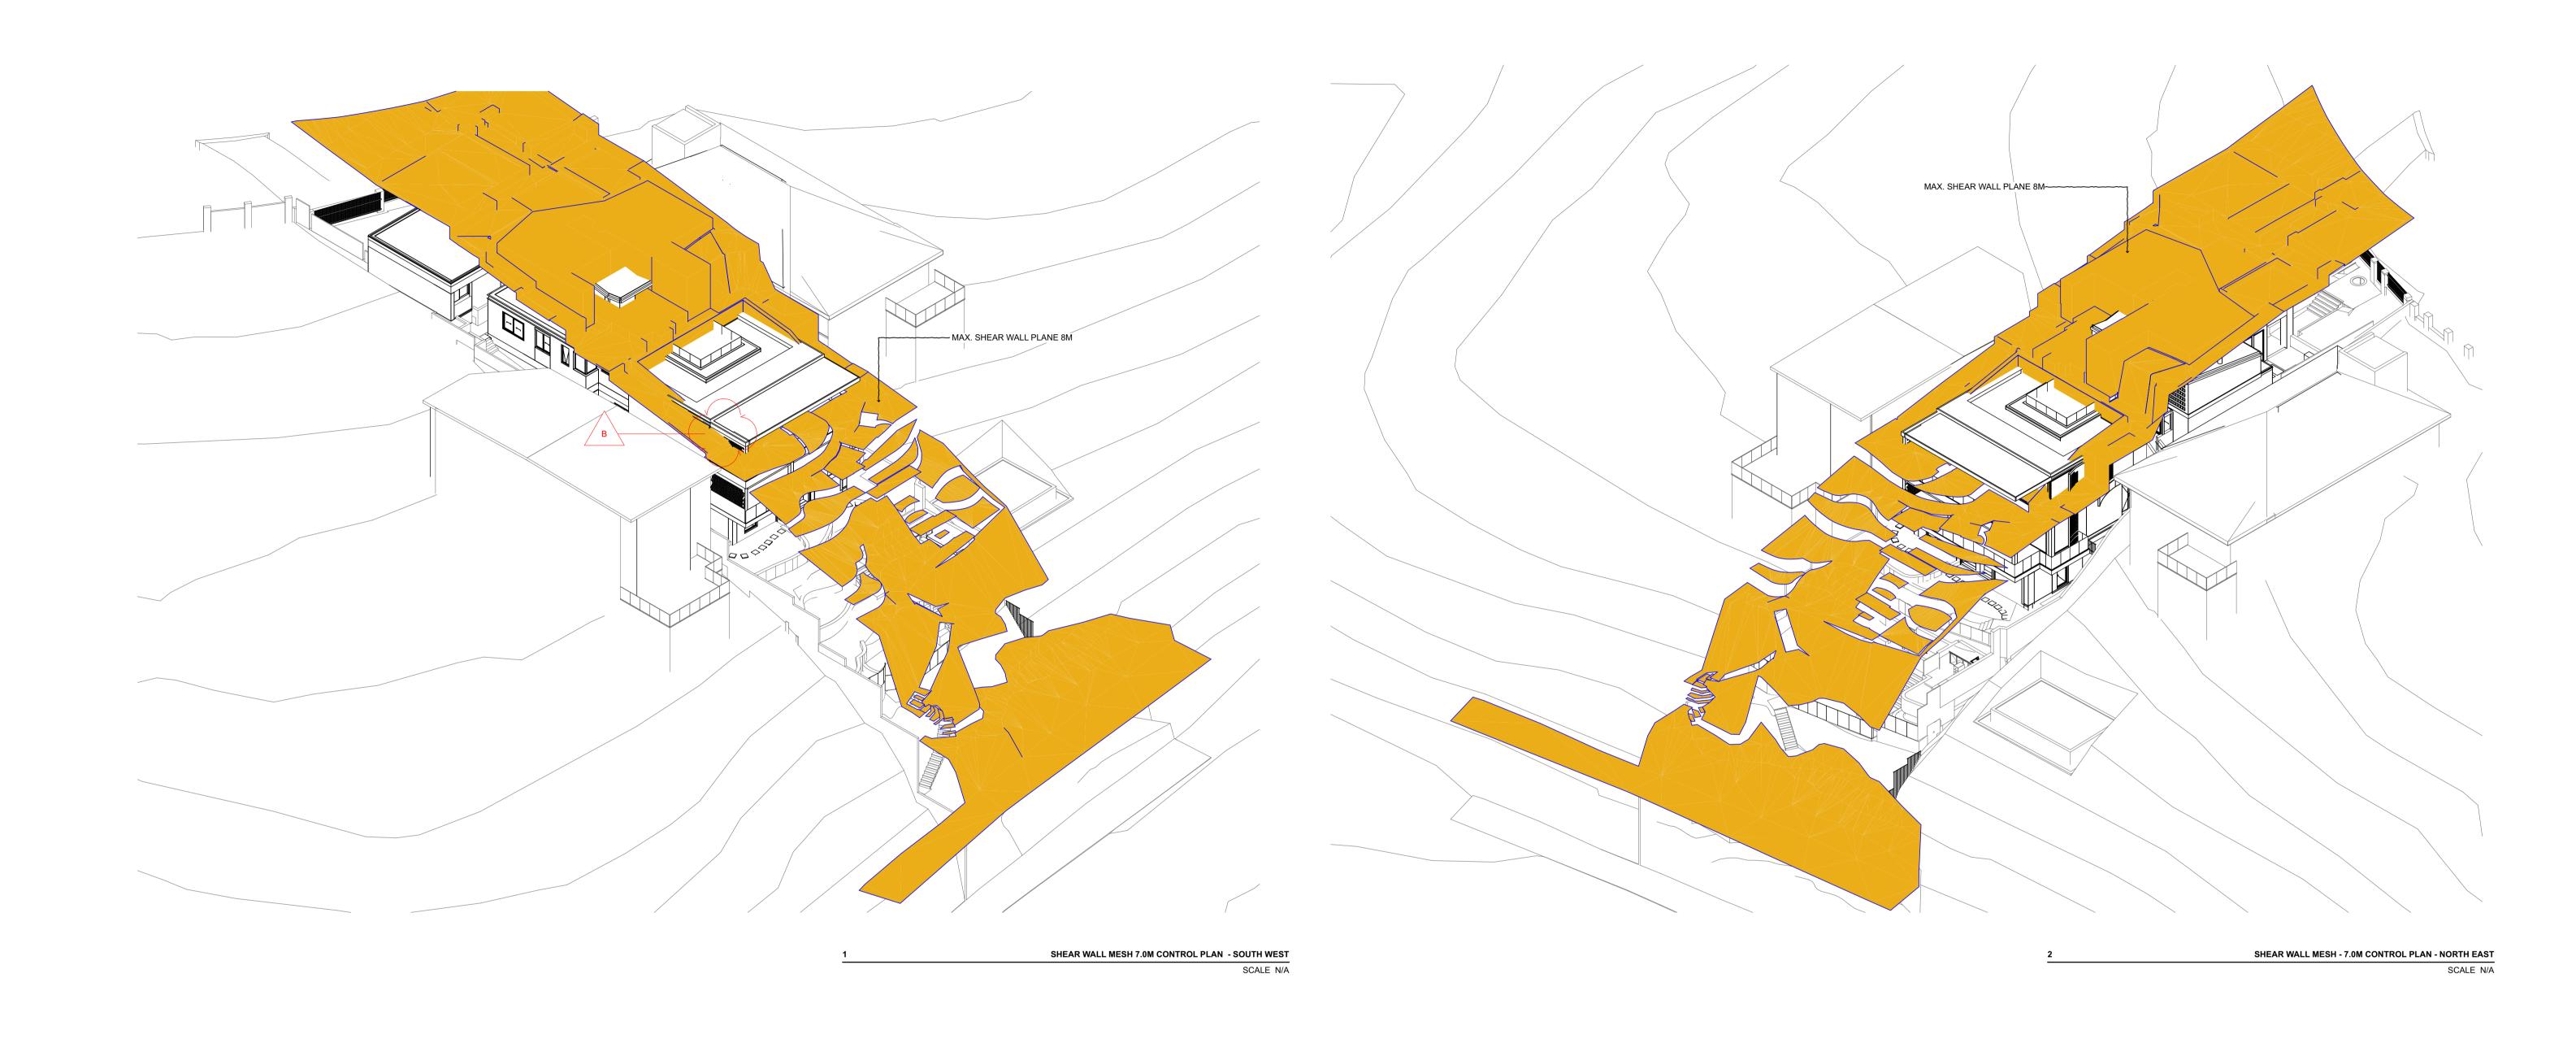

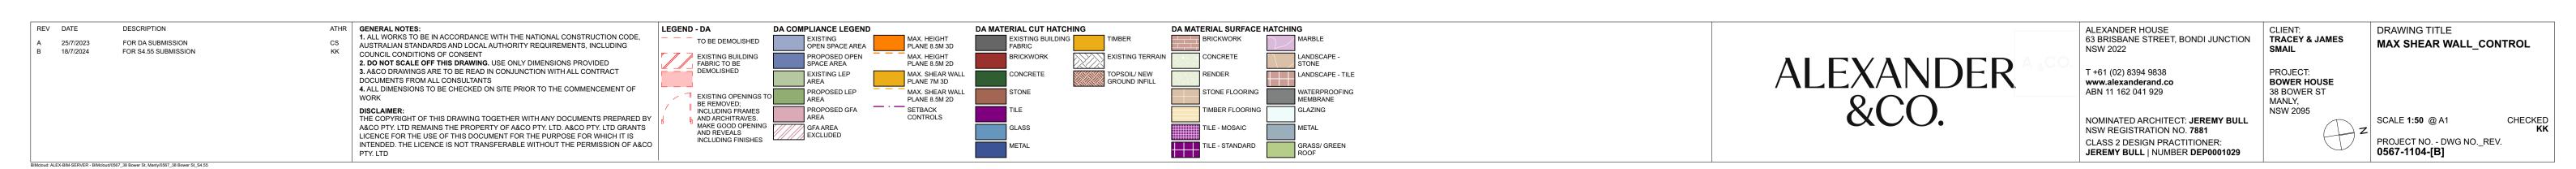



ATHR

CS
KK


1. ALL WORKS TO BE IN ACCORDANCE WITH THE NATIONAL CONSTRUCTION CODE, AUSTRALIAN STANDARDS AND LOCAL AUTHORITY REQUIREMENTS, INCLUDING COUNCIL CONDITIONS OF CONSENT

2. DO NOT SCALE OFF THIS DRAWING. USE ONLY DIMENSIONS PROVIDED

3. A&CO DRAWINGS ARE TO BE READ IN CONJUNCTION WITH ALL CONTRACT DOCUMENTS FROM ALL CONSULTANTS

4. ALL DIMENSIONS TO BE CHECKED ON SITE PRIOR TO THE COMMENCEMENT OF WORK ALEXANDER HOUSE
63 BRISBANE STREET, BONDI JUNCTION
NSW 2022

CLIENT:
TRACEY & JAMES
SMAIL REV DATE DRAWING TITLE DESCRIPTION MAX SHEAR WALL\_CONTROL A 25/7/2023 B 18/7/2024 FOR DA SUBMISSION FOR S4.55 SUBMISSION ALEXANDER &CO. EXISTING T +61 (02) 8394 9838 www.alexanderand.co ABN 11 162 041 929 PROJECT: BOWER HOUSE 38 BOWER ST MANLY, NSW 2095 DISCLAIMER:
THE COPYRIGHT OF THIS DRAWING TOGETHER WITH ANY DOCUMENTS PREPARED BY A&CO PTY. LTD REMAINS THE PROPERTY OF A&CO PTY. LTD. A&CO PTY. LTD GRANTS LICENCE FOR THE USE OF THIS DOCUMENT FOR THE PURPOSE FOR WHICH IT IS INTENDED. THE LICENCE IS NOT TRANSFERABLE WITHOUT THE PERMISSION OF A&CO PTY. LTD NOMINATED ARCHITECT: **JEREMY BULL** NSW REGISTRATION NO. **7881** CHECKED **KK** SCALE @ A1 PROJECT NO. - DWG NO.\_REV. **0567-1105-[B]** CLASS 2 DESIGN PRACTITIONER: JEREMY BULL | NUMBER DEP0001029 BIMcloud: ALEX-BIM-SERVER - BIMcloud/0567\_38 Bower St, Manly/0567\_38 Bower St\_S4.55

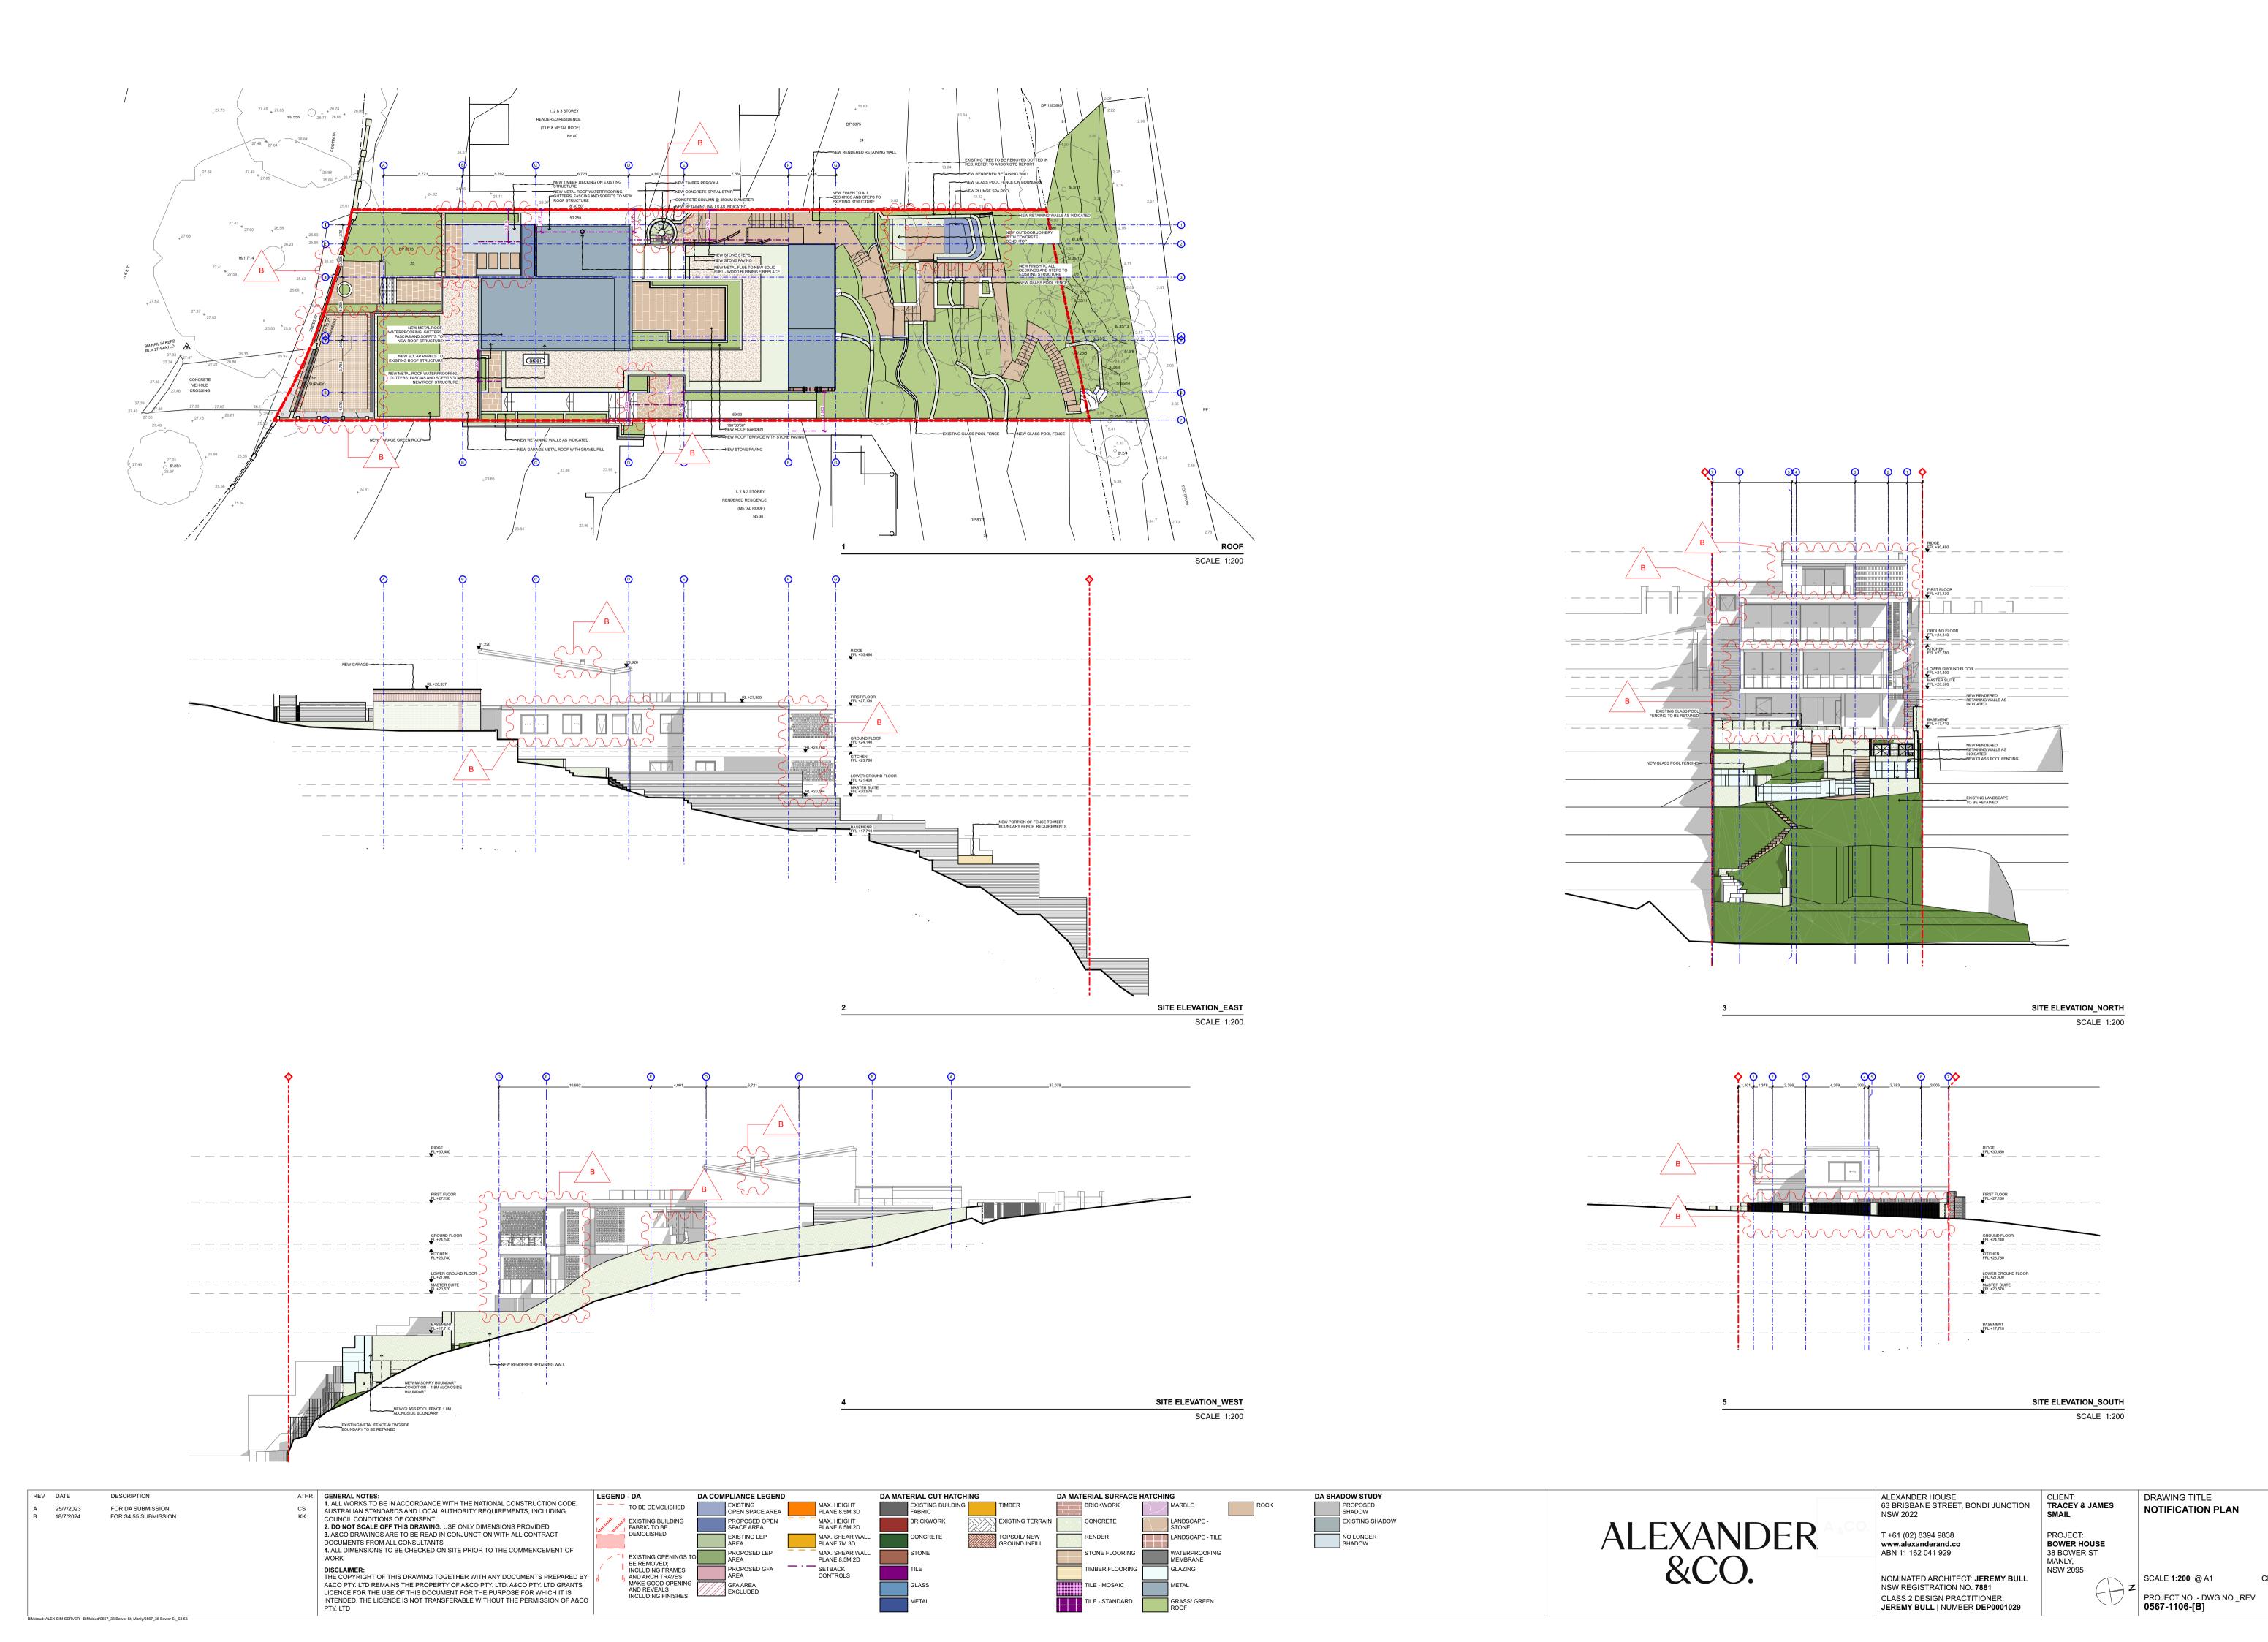

## STANDARDS, STATUTORY REGULATIONS AND LOCAL AUTHORITY REQUIREMENTS. IN ACCORDANCE WITH DEVELOPMENT APPLICATION CONDITIONS ALL HAZARDOUS SUBSTANCES LOCATED ON SITE ARE TO BE IDENTIFIED IN A REPORT PREPARED IN ACCORDANCE WITH AS2601. THIS IS TO BE PREPARED BY A SUITABLY QUALIFIED COMPETENT PERSON AND SUBMITTED TO THE PCA FOR APPROVAL AND SUBMISSION TO COUNCIL CONTRACTOR IS RESPONSIBLE FOR THE ORGANISATION OF AND PROVISION OF TEMPORARY SERVICES TO BE ABLE TO CARRY OUT ANY AND ALL DEMOLITION WORKS AS DOCUMENTED THESE DOCUMENTS ARE COMPOSITE DRAWINGS TAKEN FROM EXISTING CONDITIONS DRAWINGS, SURVEY & SITE MEASUREMENTS; DRAWINGS ARE INDICATIVE ONLY. CONTRACTOR MUST VERIFY & CHECK ALL SITE CONDITIONS INCLUDING BUT NOT LIMITED TO CEILING HEIGHTS AND DIMENSIONS BEFORE COMMENCING WORK ON SITE OR PREPARING SHOP DRAWINGS. CONTRACTOR TO ADVISE OF ANY INCONSISTENCIES TO DIMENSIONS SHOWN PRIOR TO ANY CONSTRUCTION; FINAL SET OUT TO BE APPROVED BY ALEXANDER &CO. DEMOLITION DRAWINGS TO BE READ IN CONJUNCTION WITH PROPOSED ARCHITECTURAL PACKAGE & SPECIFICATIONS. ALL EXISTING FLOOR FINISHES, SUBSTRATES, MEMBRANES TO BE REMOVED AS DOCUMENTED. MAKE GOOD TO ALL STRUCTURAL ELEMENTS AND ENSURE STRUCTURAL INTEGRITY IS RETAINED. STRUCTURAL EXISTING POOL FENCE TO RETAINED——— ENGINEER TO SIGN OFF AND APPROVE PRIOR TO ANY STRUCTURAL WORKS ALL HYDRAULIC LOCATIONS ARE INDICATIVE ONLY AND TO BE EXISTING FENCE TO BE DEMOLISHED VERIFIED ON SITE; ALL WORKS TO BE MADE GOOD AND REROUTED AS PER PROPOSED DOCUMENTATION EXISTING FINISH TO BE REMOVED EXISTING STRUCTURE TO BE RETAINED ALL EXISTING FIXTURES AND JOINERY TO BE REMOVED UNLESS OTHERWISE DOCUMENTED ALL ELECTRICAL FITTINGS AND FIXTURES TO BE REMOVED INTERNALLY AND EXTERNALLY. CONTRACTOR TO ALLOW FOR DEMOLITION OF EXISTING DOOR NEW WIRING THROUGHOUT. OUTLINE OF BUILDING ABOVE CONTRACTOR TO ALLOW SUFFICIENT WEATHER PROTECTION CH 2,550 & SITE PROTECTION TO MAINTAIN THE REMAINING PARTS OF THE DWELLING DURING EACH STAGE OF DEMOLITION AND CONSTRUCTION. RETAIN EXISTING HYDRAULIC CONNECTIONS AS DOCUMENTED REMOVE ALL EXISTING DOOR FRAMES TO ALL DOORS AS INDICATED DOORS WITH A DOOR NUMBER TO BE REMOVED BUT RETAINED IN PREPARATION FOR RELOCATION ON SITE. ALL SKIRTING AND ARCHITRAVES TO BE REMOVED. PATCH AND REPAIR WALL AS NECESSARY FOR NEW FINISH. ALL EXISTING REDUNDANT RETICULATION TO BE REMOVED. UNDERCROFT EX. PLANT = = = FFL +17,710 FFL AND CH VARY DUE TO EXISTING ROCK FORMATION EXISTING GENERAL DUCTING IN PLANT ROOM TO BE RE/TAINED EXISTING STRUCTURAL ELEMENT TO BE RETAINED PARTIAL DEMOLITION FOR NEW OPENING ATHR GENERAL NOTES: 1. ALL WORKS TO BE IN ACCORDANCE WITH THE NATIONAL CONSTRUCTION CODE, LEGEND - DA DA COMPLIANCE LEGEND DA MATERIAL CUT HATCHING DA MATERIAL SURFACE HATCHING DA SHADOW STUDY DESCRIPTION DRAWING TITLE MAX. HEIGHT PLANE 8.5M 3D EXISTING BUILDING 63 BRISBANE STREET, BONDI JUNCTION TRACEY & JAMES TO BE DEMOLISHED **BASEMENT - GENERAL** FOR DA SUBMISSION AUSTRALIAN STANDARDS AND LOCAL AUTHORITY REQUIREMENTS, INCLUDING OPEN SPACE AREA NSW 2022 B 18/7/2024 FOR \$4.55 SUBMISSION PROPOSED OPEN SPACE AREA COUNCIL CONDITIONS OF CONSENT EXISTING BUILDING FABRIC TO BE DEMOLISHED MAX. HEIGHT PLANE 8.5M 2D EXISTING SHADOW ALEXANDER &CO. **ARRANGEMENT PLAN -**2. DO NOT SCALE OFF THIS DRAWING. USE ONLY DIMENSIONS PROVIDED **EXISTING & DEMOLITION** T +61 (02) 8394 9838 3. A&CO DRAWINGS ARE TO BE READ IN CONJUNCTION WITH ALL CONTRACT PROJECT: MAX. SHEAR WALL PLANE 7M 3D EXISTING LEP LANDSCAPE - TILE www.alexanderand.co ABN 11 162 041 929 DOCUMENTS FROM ALL CONSULTANTS **BOWER HOUSE** 4. ALL DIMENSIONS TO BE CHECKED ON SITE PRIOR TO THE COMMENCEMENT OF MAX. SHEAR WALL PLANE 8.5M 2D 38 BOWER ST EXISTING OPENINGS T BE REMOVED; INCLUDING FRAMES AND ARCHITRAVES. MAKE GOOD OPENING AND REVEALS **DISCLAIMER:**THE COPYRIGHT OF THIS DRAWING TOGETHER WITH ANY DOCUMENTS PREPARED BY SETBACK CONTROLS NSW 2095

NOMINATED ARCHITECT: **JEREMY BULL** 

NSW REGISTRATION NO. 7881

CLASS 2 DESIGN PRACTITIONER:

JEREMY BULL | NUMBER DEP0001029

SCALE 1:50 @ A1

0567-2000-[B]

PROJECT NO. - DWG NO.\_REV.

**DEMOLITION** 

ALL DEMOLITION WORK IN ACCORDANCE WITH THE NATIONAL CONSTRUCTION CODE OF AUSTRALIA, AUSTRALIAN

A&CO PTY. LTD REMAINS THE PROPERTY OF A&CO PTY. LTD. A&CO PTY. LTD GRANTS

LICENCE FOR THE USE OF THIS DOCUMENT FOR THE PURPOSE FOR WHICH IT IS INTENDED. THE LICENCE IS NOT TRANSFERABLE WITHOUT THE PERMISSION OF A&CO

### STANDARDS, STATUTORY REGULATIONS AND LOCAL AUTHORITY REQUIREMENTS. IN ACCORDANCE WITH DEVELOPMENT APPLICATION CONDITIONS ALL HAZARDOUS SUBSTANCES LOCATED ON SITE ARE TO BE IDENTIFIED IN A REPORT PREPARED IN ACCORDANCE WITH AS2601. THIS IS TO BE PREPARED BY A SUITABLY QUALIFIED COMPETENT PERSON AND SUBMITTED TO THE PCA FOR APPROVAL AND SUBMISSION TO COUNCIL CONTRACTOR IS RESPONSIBLE FOR THE ORGANISATION OF AND PROVISION OF TEMPORARY SERVICES TO BE ABLE TO CARRY OUT ANY AND ALL DEMOLITION WORKS AS DOCUMENTED THESE DOCUMENTS ARE COMPOSITE DRAWINGS TAKEN FROM EXISTING CONDITIONS DRAWINGS, SURVEY & SITE MEASUREMENTS; DRAWINGS ARE INDICATIVE ONLY. CONTRACTOR MUST VERIFY & CHECK ALL SITE CONDITIONS INCLUDING BUT NOT LIMITED TO CEILING HEIGHTS AND DIMENSIONS BEFORE COMMENCING WORK ON SITE OR PREPARING SHOP DRAWINGS. CONTRACTOR TO ADVISE OF ANY INCONSISTENCIES TO DIMENSIONS SHOWN PRIOR TO ANY CONSTRUCTION; FINAL SET OUT TO BE APPROVED BY ALEXANDER &CO. DEMOLITION DRAWINGS TO BE READ IN CONJUNCTION WITH PROPOSED ARCHITECTURAL PACKAGE & SPECIFICATIONS. ALL EXISTING FLOOR FINISHES, SUBSTRATES, MEMBRANES EXISTING MASONRY TO BE DEMOLISHED AND REPLACED-TO BE REMOVED AS DOCUMENTED. MAKE GOOD TO ALL STRUCTURAL ELEMENTS AND ENSURE STRUCTURAL INTEGRITY IS RETAINED. STRUCTURAL ENGINEER TO SIGN OFF AND APPROVE PRIOR TO ANY STRUCTURAL WORKS ALL HYDRAULIC LOCATIONS ARE INDICATIVE ONLY AND TO BE VERIFIED ON SITE; ALL WORKS TO BE MADE GOOD AND REROUTED AS PER PROPOSED DOCUMENTATION EXISTING SINK AND JOINERY BE DEMOLISHED ALL EXISTING FIXTURES AND JOINERY TO BE REMOVED UNLESS OTHERWISE DOCUMENTED ALL ELECTRICAL FITTINGS AND FIXTURES TO BE REMOVED INTERNALLY AND EXTERNALLY. CONTRACTOR TO ALLOW FOR NEW WIRING THROUGHOUT. ESTIMATED EXTENT OF CONTRACTOR TO ALLOW SUFFICIENT WEATHER PROTECTION EXCAVATION EXISTING DOOR TO BE DEMOLISHED & SITE PROTECTION TO MAINTAIN THE REMAINING PARTS OF THE DWELLING DURING EACH STAGE OF DEMOLITION AND CONSTRUCTION. RETAIN EXISTING HYDRAULIC CONNECTIONS AS DOCUMENTED REMOVE ALL EXISTING DOOR FRAMES TO ALL DOORS AS INDICATED EXISTING DOOR TO BE DEMOLISHED DOORS WITH A DOOR NUMBER TO BE REMOVED BUT ESTIMATED EXTENT OF RETAINED IN PREPARATION FOR RELOCATION ON SITE. EXCAVATION ( EXISTING MASONRY WALL & WINDOWS TO BE DEMOLISHED ALL SKIRTING AND ARCHITRAVES TO BE REMOVED. PATCH EXISTING PORTION OF MASONRY WALL AND REPAIR WALL AS NECESSARY FOR NEW FINISH. TO BE DEMOLISHED EXISTING TIMBER DECKING ALL EXISTING REDUNDANT RETICULATION TO BE REMOVED. TO BE DEMOLISHED EX. RUMPUS ROOM CH 2,910 FFL +20,520 **EX. PLANT ROOM** CH 2,950 EXISTING SLIDING DOOR BE DEMOLISHED EXISTING PORTION OF MASONRY WALL EXISTING FLOOR FINISHES BE DEMOLISHED & HINGE DOOR TO BE DEMOLISHED EXISTING CONCRETE SLAB TO BE RETAINED ÉXISTING STAIR STRUCTURE RETAINED EXISTING STEPS TO BE DEMOLISHED EXISITING FINISH ON STAIR THREADS TO BE EX. HALLWAY EXISTING HINGE DOOR TO BE DEMOLISHED DEMOLISHED> FFL +21,350 EXISTING PORTION OF MASONRY WALL CH 2,380 & HINGE DOOR TO BE DEMOLISHED BALUSTRADE TO BE DEMOLISHED STING PORTION OF MASONRY TO BE DEMOLISHED EXISTING CONCRETE SLAB INCLUDING FOOTINGS AND FLOOR FINISHES BE DEMOLISHED FFL +20.520 EXISTING WC TO BE DEMOLISHED INCLUDING PLUMBING FIXTURES EXISTING KITCHENETTE AND JOINERY TO BE DEMOLISHED EXISTING MASONRY WALL TO BE DEMOLISHED EX. SELF CONTAINED LIVING EXISTING SLIDING DOOR TO BE DEMOLISHED EXISTING ENSUITE TO BE DEMOLISHED FFL +20,520 EX. BEDROOM 04 EX. ENSUITE EXISTING PORTION OF MASONRY TO BE INCLUDING PLUMBING FIXTURES FFL +20,520 FFL +21,410 CH 2,950 DEMOLISHED EXISTING JOINERY BE DEMOLISHED FEH+2249400 CH 2,370 EXISTING CONCRETE SLAB INCLUDING EXISTING STEPS TO BE DEMOLISHED EXISTING FLOOR FINISHES TO BE DEMOLISHED /FOOTINGS AND FLOOR FINISHES BE DEMOLISHED EXISTING CONCRETE SLAB TO BE RETAINED EXISTING SLIDING DOOR TO BE DEMOLISHED EXISTING PORTION OF MASONRY TO BE DEMOLISHED EXISTING PORTION OF GLASS BALUSTRADE TO BE DEMOLISHED **EXISTING LIGHTWEIGHT WALL & WINDOWS TO** -EXISTING HINGE DOOR TO BE REMOVED BE DEMOLISHED EXISTING CONCRETE SLAB INCLUDING EXISTING PORTION OF MASONRY TO BE DEMOLISHED FOOTINGS AND FLOOR FINISHES TO BE DEMOLISHED DEMOLISH PORTION OF EXISTING PLANTER EXISTING WINDOW AND PORTION OF MASONRY WALL TO BE DEMOLISHED EXISTING STEPS TO BE DEMOLISHED-DA COMPLIANCE LEGEND DA MATERIAL SURFACE HATCHING DA SHADOW STUDY DESCRIPTION LEGEND - DA DA MATERIAL CUT HATCHING DRAWING TITLE 1. ALL WORKS TO BE IN ACCORDANCE WITH THE NATIONAL CONSTRUCTION CODE, 63 BRISBANE STREET, BONDI JUNCTION TRACEY & JAMES TO BE DEMOLISHED **LOWER GROUND FLOOR -**FOR DA SUBMISSION PLANE 8.5M 3D AUSTRALIAN STANDARDS AND LOCAL AUTHORITY REQUIREMENTS, INCLUDING OPEN SPACE AREA NSW 2022 18/7/2024 FOR \$4.55 SUBMISSION COUNCIL CONDITIONS OF CONSENT MAX. HEIGHT PLANE 8.5M 2D EXISTING SHADOW **GENERAL ARRANGEMENT PLAN** ALEXANDER &CO. 2. DO NOT SCALE OFF THIS DRAWING. USE ONLY DIMENSIONS PROVIDED SPACE AREA - EXISTING & DEMOLITION 3. A&CO DRAWINGS ARE TO BE READ IN CONJUNCTION WITH ALL CONTRACT DEMOLISHED T +61 (02) 8394 9838 PROJECT: MAX. SHEAR WALL PLANE 7M 3D EXISTING LEP LANDSCAPE - TILE www.alexanderand.co ABN 11 162 041 929 DOCUMENTS FROM ALL CONSULTANTS **BOWER HOUSE** 4. ALL DIMENSIONS TO BE CHECKED ON SITE PRIOR TO THE COMMENCEMENT OF MAX. SHEAR WALL PLANE 8.5M 2D 38 BOWER ST BE REMOVED; INCLUDING FRAMES AND ARCHITRAVES. **DISCLAIMER:**THE COPYRIGHT OF THIS DRAWING TOGETHER WITH ANY DOCUMENTS PREPARED BY SETBACK CONTROLS GLAZING NSW 2095 NOMINATED ARCHITECT: **JEREMY BULL** SCALE 1:50 @ A1

NSW REGISTRATION NO. 7881

CLASS 2 DESIGN PRACTITIONER:

JEREMY BULL | NUMBER DEP0001029

PROJECT NO. - DWG NO.\_REV.

0567-2001-[B]

MAKE GOOD OPENING AND REVEALS

A&CO PTY. LTD REMAINS THE PROPERTY OF A&CO PTY. LTD. A&CO PTY. LTD GRANTS

LICENCE FOR THE USE OF THIS DOCUMENT FOR THE PURPOSE FOR WHICH IT IS INTENDED. THE LICENCE IS NOT TRANSFERABLE WITHOUT THE PERMISSION OF A&CO

BIMcloud: ALEX-BIM-SERVER - BIMcloud/0567\_38 Bower St, Manly/0567\_38 Bower St\_S4.55

**DEMOLITION** 

ALL DEMOLITION WORK IN ACCORDANCE WITH THE NATIONAL CONSTRUCTION CODE OF AUSTRALIA. AUSTRALIAN

#### CONSTRUCTION CODE OF AUSTRALIA, AUSTRALIAN STANDARDS, STATUTORY REGULATIONS AND LOCAL AUTHORITY REQUIREMENTS. IN ACCORDANCE WITH DEVELOPMENT APPLICATION CONDITIONS ALL HAZARDOUS SUBSTANCES LOCATED ON SITE ARE TO BE IDENTIFIED IN A REPORT PREPARED IN ACCORDANCE WITH AS2601. THIS IS TO BE PREPARED BY A SUITABLY QUALIFIED COMPETENT PERSON AND SUBMITTED TO THE PCA FOR APPROVAL AND SUBMISSION TO COUNCIL CONTRACTOR IS RESPONSIBLE FOR THE ORGANISATION OF AND PROVISION OF TEMPORARY SERVICES TO BE ABLE TO CARRY OUT ANY AND ALL DEMOLITION WORKS AS DOCUMENTED THESE DOCUMENTS ARE COMPOSITE DRAWINGS TAKEN FROM EXISTING CONDITIONS DRAWINGS, SURVEY & SITE MEASUREMENTS; DRAWINGS ARE INDICATIVE ONLY. CONTRACTOR MUST VERIFY & CHECK ALL SITE CONDITIONS INCLUDING BUT NOT LIMITED TO CEILING HEIGHTS AND DIMENSIONS BEFORE COMMENCING WORK ON SITE OR PREPARING SHOP DRAWINGS. CONTRACTOR TO ADVISE OF ANY INCONSISTENCIES TO DIMENSIONS SHOWN PRIOR TO ANY CONSTRUCTION; FINAL SET OUT TO BE APPROVED BY ALEXANDER &CO. —EXISTING WINDOW TO BE DEMOLISHÈ DEMOLITION DRAWINGS TO BE READ IN CONJUNCTION WITH PROPOSED ARCHITECTURAL PACKAGE & SPECIFICATIONS. ALL EXISTING FLOOR FINISHES, SUBSTRATES, MEMBRANES TO BE REMOVED AS DOCUMENTED. EXISTING SLIDING DOOR TO BE DEMOLISHED MAKE GOOD TO ALL STRUCTURAL ELEMENTS AND ENSURE EXISTING WINDOW TO BE DEMOLISHED STRUCTURAL INTEGRITY IS RETAINED. STRUCTURAL ENGINEER TO SIGN OFF AND APPROVE PRIOR TO ANY STRUCTURAL WORKS ALL HYDRAULIC LOCATIONS ARE INDICATIVE ONLY AND TO BE VERIFIED ON SITE; ALL WORKS TO BE MADE GOOD AND REROUTED AS PER PROPOSED DOCUMENTATION ALL EXISTING FIXTURES AND JOINERY TO BE REMOVED UNLESS OTHERWISE DOCUMENTED ALL ELECTRICAL FITTINGS AND FIXTURES TO BE REMOVED INTERNALLY AND EXTERNALLY. CONTRACTOR TO ALLOW FOR NEW WIRING THROUGHOUT. EXISTING JOINERY TO BE DEMOLISHED BALCONY CONTRACTOR TO ALLOW SUFFICIENT WEATHER PROTECTION BELOW & SITE PROTECTION TO MAINTAIN THE REMAINING PARTS OF THE DWELLING DURING EACH STAGE OF DEMOLITION AND CONSTRUCTION. EXISTING WINDOW TO BE RETAIN EXISTING HYDRAULIC CONNECTIONS AS DEMOLISHED EX. FAMILY DOCUMENTED FFL +24,140 EXISTING GLASS ROOF OVERHEAD TO BE DEMOLISHED REMOVE ALL EXISTING DOOR FRAMES TO ALL DOORS AS EX. DECK **CH VARIES** INDICATED EXISTING GATE LANDING TO BE DEMOLISHED FFL)+24,100 DOORS WITH A DOOR NUMBER TO BE REMOVED BUT RETAINED IN PREPARATION FOR RELOCATION ON SITE. EXISTING WINDOW TO BE EXISTING FLOOR FINISHES TO BE DEMOLISH DEMOLISHED ALL SKIRTING AND ARCHITRAVES TO BE REMOVED. PATCH = = ‡ = = ‡ = = |= = |= = AND REPAIR WALL AS NECESSARY FOR NEW FINISH. PATH AND STEPS TO BE EXISTING FLOOR FINISHES TO BE DEMOLISHED ALL EXISTING REDUNDANT RETICULATION TO BE REMOVED. DEMOLISHED EXISTING PORTION OF MASONRY WALL TO BE DEMOLISHED EX. TERRACE EXISTING SLIDING DOOR TO BE DEMOLISHED-FFL +24,100 GLASS BALUSTRADE TO BE DEMOLISHED CH 2,900 EX. HALLWAY EXISTING ENTRY DOOR TO BE DEMOLISHED FFL +24,140 FFL +23,730 INCLUDING SIDE WINDOWS CH 3,255 EXISTING SLIDING DOOR TO BE DEMOLISHED CH 2,915 EXISTING HINGE DOOR TO BE DEMOLISHED-EXISTING SKYLIGHTS INCLUDING TSTRUCTURE TO BE DEMOLISHED EXISTING PORTION OF MASONRY TO BE DEMOLISHED = = ± = = ± = = |= = |= EXISTING HINGE DOOR TO BE DEMOLISHED—— EXISTING STEPS TO BE DEMOLISHED: EX. POWDER ROOM EXISTING PORTION OF MASONRY WALL TO 4 "|| || || || || || || || || |<sub>M\\ 1</sub> || || || || || || EX. KITCHEN TBE DEMOLISHED FFL +24,140 FFL +24,140 EXISTING SLIDING DOOR TO BE DEMOLISHED. CH 3,255 CH 2,390 EXISTING PORTION OF MASONRY TO BE DEMOLISHED— \_\_\_\_\_ EXISTING PORTION OF MASONRY TO BE DEMOLISHED EXISTING NIB WALL TO BE DEMOLISHED \_ \_ \_ \_ EXISTING\_WINDOW TO BE DEMOLISHED EXISTING HINGE DOOR TO BE DEMOLISHED EX. MASTER WIR EXISTING MASTER WIR TO BE EXISTING HINGE DOOR TO BE DEMOLISHED FFL +23,730 DEMOLISHED INCLUDING JOINERY CH 2,915 EXISTING JOINERY TO BE DEMOLISHED EX. MASTER BEDROOM NCLUDING PLUMBING FIXTURES EX. PANTRY FFL +23,730 EXISTING SLIDING DOOR TO BE DEMOLISHED EXISTING STEPS TO BE DEMOLISHED FFL +24,140 EXISTING PORTION OF MASONRY WALL TO EX. BEDROOM 02 CH 2,390 BE DEMOLISHED FFL +2<mark>4,140</mark> EX. BEDROOM 03 EXISTING FLOOR FINISHES TO BE DEMOLISHED EX. MASTER ENSUITE CH 2,590 FFL +24,140 FFL +23,730 EXISTING JOINERY TO BE DEMOLISHED EXISTING WINDOW BE DEMOLISHED CH 2,915 EXISTING MASONRY WALL TO BE DEMOLISHED EX. GARAGE EXISTING MASTER ENSUITE TO BE DEMOLISHED FFL +24,844 INCLUDING PLUMBING FIXTURES EXISTING WINDOW BE DEMOLISHED CH 2,215 EXISTING WINDOW TO BE DEMOLISHED GLASS BALUSTRADE BE DEMOLISHED EXISTING WINDOW BE DEMOLISHED EXISTING WINDOW TO BE DEMOLISHED——— EXISTING PORTION OF MASONRY TO BE DEMOLISHED-EXISTING JOINERY TO BE DEMOLISHED-EXISTING PORTION OF MASONRY TO BE DEMOLISHED-**EXISTING LIGHTWEIGHT WALL & WINDOWS TO** BE DEMOLISHED EXISTING RETAINING WALL TO BE DEMOLISHED—— DA COMPLIANCE LEGEND DA MATERIAL CUT HATCHING DA MATERIAL SURFACE HATCHING **DA SHADOW STUDY** DESCRIPTION LEGEND - DA DRAWING TITLE 1. ALL WORKS TO BE IN ACCORDANCE WITH THE NATIONAL CONSTRUCTION CODE, KISTING BUILDING 63 BRISBANE STREET, BONDI JUNCTION TRACEY & JAMES TO BE DEMOLISHED **GROUND FLOOR - GENERAL** FOR DA SUBMISSION PLANE 8.5M 3D AUSTRALIAN STANDARDS AND LOCAL AUTHORITY REQUIREMENTS, INCLUDING OPEN SPACE AREA NSW 2022 18/7/2024 FOR \$4.55 SUBMISSION COUNCIL CONDITIONS OF CONSENT MAX. HEIGHT PLANE 8.5M 2D EXISTING SHADOW ALEXANDER &CO. ARRANGEMENT PLAN -2. DO NOT SCALE OFF THIS DRAWING. USE ONLY DIMENSIONS PROVIDED SPACE AREA **EXISTING & DEMOLITION** 3. A&CO DRAWINGS ARE TO BE READ IN CONJUNCTION WITH ALL CONTRACT DEMOLISHED T +61 (02) 8394 9838 PROJECT: MAX. SHEAR WALL PLANE 7M 3D CONCRETE EXISTING LEP LANDSCAPE - TILE www.alexanderand.co ABN 11 162 041 929 DOCUMENTS FROM ALL CONSULTANTS **BOWER HOUSE** 4. ALL DIMENSIONS TO BE CHECKED ON SITE PRIOR TO THE COMMENCEMENT OF MAX. SHEAR WALL PLANE 8.5M 2D 38 BOWER ST EXISTING OPENINGS T BE REMOVED; INCLUDING FRAMES AND ARCHITRAVES. **DISCLAIMER:**THE COPYRIGHT OF THIS DRAWING TOGETHER WITH ANY DOCUMENTS PREPARED BY SETBACK GLAZING NSW 2095 NOMINATED ARCHITECT: **JEREMY BULL** SCALE 1:50 @ A1 A&CO PTY. LTD REMAINS THE PROPERTY OF A&CO PTY. LTD. A&CO PTY. LTD GRANTS MAKE GOOD OPENING AND REVEALS NSW REGISTRATION NO. 7881 LICENCE FOR THE USE OF THIS DOCUMENT FOR THE PURPOSE FOR WHICH IT IS

PROJECT NO. - DWG NO.\_REV.

0567-2002-[B]

CLASS 2 DESIGN PRACTITIONER:

JEREMY BULL | NUMBER DEP0001029

**DEMOLITION** 

ALL DEMOLITION WORK IN ACCORDANCE WITH THE NATIONAL

INTENDED. THE LICENCE IS NOT TRANSFERABLE WITHOUT THE PERMISSION OF A&CO

# ALL DEMOLITION WORK IN ACCORDANCE WITH THE NATIONAL CONSTRUCTION CODE OF AUSTRALIA, AUSTRALIAN STANDARDS, STATUTORY REGULATIONS AND LOCAL AUTHORITY REQUIREMENTS. IN ACCORDANCE WITH DEVELOPMENT APPLICATION CONDITIONS ALL HAZARDOUS SUBSTANCES LOCATED ON SITE ARE TO BE IDENTIFIED IN A REPORT PREPARED IN ACCORDANCE WITH AS2601. THIS IS TO BE PREPARED BY A SUITABLY QUALIFIED COMPETENT PERSON AND SUBMITTED TO THE PCA FOR APPROVAL AND SUBMISSION TO COUNCIL CONTRACTOR IS RESPONSIBLE FOR THE ORGANISATION OF AND PROVISION OF TEMPORARY SERVICES TO BE ABLE TO CARRY OUT ANY AND ALL DEMOLITION WORKS AS DOCUMENTED THESE DOCUMENTS ARE COMPOSITE DRAWINGS TAKEN FROM EXISTING CONDITIONS DRAWINGS, SURVEY & SITE MEASUREMENTS; DRAWINGS ARE INDICATIVE ONLY. CONTRACTOR MUST VERIFY & CHECK ALL SITE CONDITIONS INCLUDING BUT NOT LIMITED TO CEILING HEIGHTS AND DIMENSIONS BEFORE COMMENCING WORK ON SITE OR PREPARING SHOP DRAWINGS. CONTRACTOR TO ADVISE OF ANY INCONSISTENCIES TO DIMENSIONS SHOWN PRIOR TO ANY CONSTRUCTION; FINAL SET OUT TO BE APPROVED BY ALEXANDER &CO. DEMOLITION DRAWINGS TO BE READ IN CONJUNCTION WITH PROPOSED ARCHITECTURAL PACKAGE & SPECIFICATIONS. ALL EXISTING FLOOR FINISHES, SUBSTRATES, MEMBRANES TO BE REMOVED AS DOCUMENTED. MAKE GOOD TO ALL STRUCTURAL ELEMENTS AND ENSURE STRUCTURAL INTEGRITY IS RETAINED. STRUCTURAL EXISTING PLANTER TO BE DEMOLISHED ENGINEER TO SIGN OFF AND APPROVE PRIOR TO ANY EXISTING PLANTS AND FRAGIPANI TREE TO BE REPLANTED STRUCTURAL WORKS ALL HYDRAULIC LOCATIONS ARE INDICATIVE ONLY AND TO BE VERIFIED ON SITE; ALL WORKS TO BE MADE GOOD AND REROUTED AS PER PROPOSED DOCUMENTATION ALL EXISTING FIXTURES AND JOINERY TO BE REMOVED UNLESS OTHERWISE DOCUMENTED ALL ELECTRICAL FITTINGS AND FIXTURES TO BE REMOVED INTERNALLY AND EXTERNALLY. CONTRACTOR TO ALLOW FOR EXISTING WINDOW TO BE DEMOLISHED NEW WIRING THROUGHOUT. EXISTING WINDOW TO BE DEMOLISHED CONTRACTOR TO ALLOW SUFFICIENT WEATHER PROTECTION & SITE PROTECTION TO MAINTAIN THE REMAINING PARTS OF THE DWELLING DURING EACH STAGE OF DEMOLITION AND CONSTRUCTION. TING ROOFING, EAVES, SOFFIT, FASCIAS RETAIN EXISTING HYDRAULIC CONNECTIONS AS AND GUTTERS TO BE DEMOLISHED DOCUMENTED VOID REMOVE ALL EXISTING DOOR FRAMES TO ALL DOORS AS INDICATED DOORS WITH A DOOR NUMBER TO BE REMOVED BUT RETAINED IN PREPARATION FOR RELOCATION ON SITE. andereka (makeraka) ALL SKIRTING AND ARCHITRAVES TO BE REMOVED. PATCH AND REPAIR WALL AS NECESSARY FOR NEW FINISH. ALL EXISTING REDUNDANT RETICULATION TO BE REMOVED. EXISTING WALL TO BE DEMOLISHED-EXISTING WINDOW TO BE DEMOLISHED EX. STUDY FFL +27,080 EXISTING JOINERY TO BE DEMOLISHED EXISTING ROOF TO BE DEMOLISHED~ CH HEIGHEST POINT 3150 CH LOWEST POINT 2250 EXISTING ROOFING, EAVES, SOFFIT, FASCIAS AND GUTTERS TO BE DEMOLISHED ROOF STRUCTURE TO BE RETAINED EXISTING STAIR TO BE DEMOLISHED-# ----EXISTING ROOF TO BE DEMOLISHED-<del>. . . || . . . . | . . . . | . . . . || . . . || . . . || . . . || . . . || . . . || . . . || . . . || . . . || . . . || . . . || . . . || . . . || . . . || . . . || . . . || . . . ||</del> randra di malandra di malandra di m EXISTING STAIRS TO BE DEMOLISHED 111 | 111 | 1 <del>┖╏╏</del>╫╫╫╫ anderederederedereder EXISTING PLANTER TO BE DEMOLISHED EXISTING PLANTS AND FRAGIPANI TREE TO BE REPLANTED EXISTING GARAGE ROOF TO BE EXISTING RETAINING WALL TO BE DEMOLISHED EXISTING RETAINING WALL TO BE DEMOLISHED-DEMOLISHED

DESCRIPTION ALEXANDER HOUSE DRAWING TITLE 1. ALL WORKS TO BE IN ACCORDANCE WITH THE NATIONAL CONSTRUCTION CODE, 63 BRISBANE STREET, BONDI JUNCTION TRACEY & JAMES FOR DA SUBMISSION **FIRST FLOOR - GENERAL** AUSTRALIAN STANDARDS AND LOCAL AUTHORITY REQUIREMENTS, INCLUDING NSW 2022 18/7/2024 FOR \$4.55 SUBMISSION COUNCIL CONDITIONS OF CONSENT ALEXANDER &CO. **ARRANGEMENT PLAN -**2. DO NOT SCALE OFF THIS DRAWING. USE ONLY DIMENSIONS PROVIDED **EXISTING & DEMOLITION** T +61 (02) 8394 9838 3. A&CO DRAWINGS ARE TO BE READ IN CONJUNCTION WITH ALL CONTRACT PROJECT: www.alexanderand.co ABN 11 162 041 929 DOCUMENTS FROM ALL CONSULTANTS **BOWER HOUSE** 4. ALL DIMENSIONS TO BE CHECKED ON SITE PRIOR TO THE COMMENCEMENT OF 38 BOWER ST MANLY, **DISCLAIMER:**THE COPYRIGHT OF THIS DRAWING TOGETHER WITH ANY DOCUMENTS PREPARED BY NSW 2095 NOMINATED ARCHITECT: **JEREMY BULL** SCALE 1:50 @ A1 A&CO PTY. LTD REMAINS THE PROPERTY OF A&CO PTY. LTD. A&CO PTY. LTD GRANTS NSW REGISTRATION NO. 7881 LICENCE FOR THE USE OF THIS DOCUMENT FOR THE PURPOSE FOR WHICH IT IS PROJECT NO. - DWG NO.\_REV. CLASS 2 DESIGN PRACTITIONER: INTENDED. THE LICENCE IS NOT TRANSFERABLE WITHOUT THE PERMISSION OF A&CO 0567-2003-[B] JEREMY BULL | NUMBER DEP0001029

BIMcloud: ALEX-BIM-SERVER - BIMcloud/0567\_38 Bower St, Manly/0567\_38 Bower St\_\$4.55

**DEMOLITION** 

## CONSTRUCTION CODE OF AUSTRALIA. AUSTRALIAN STANDARDS, STATUTORY REGULATIONS AND LOCAL AUTHORITY REQUIREMENTS. IN ACCORDANCE WITH DEVELOPMENT APPLICATION CONDITIONS ALL HAZARDOUS SUBSTANCES LOCATED ON SITE ARE TO BE IDENTIFIED IN A REPORT PREPARED IN ACCORDANCE WITH AS2601. THIS IS TO BE PREPARED BY A SUITABLY QUALIFIED COMPETENT PERSON AND SUBMITTED TO THE PCA FOR APPROVAL AND SUBMISSION TO COUNCIL CONTRACTOR IS RESPONSIBLE FOR THE ORGANISATION OF AND PROVISION OF TEMPORARY SERVICES TO BE ABLE TO CARRY OUT ANY AND ALL DEMOLITION WORKS AS DOCUMENTED THESE DOCUMENTS ARE COMPOSITE DRAWINGS TAKEN FROM EXISTING CONDITIONS DRAWINGS, SURVEY & SITE MEASUREMENTS; DRAWINGS ARE INDICATIVE ONLY. G CONTRACTOR MUST VERIFY & CHECK ALL SITE CONDITIONS INCLUDING BUT NOT LIMITED TO CEILING HEIGHTS AND DIMENSIONS BEFORE COMMENCING WORK ON SITE OR PREPARING SHOP DRAWINGS. CONTRACTOR TO ADVISE OF ANY INCONSISTENCIES TO DIMENSIONS SHOWN PRIOR TO ANY CONSTRUCTION; FINAL SET OUT TO BE APPROVED BY ALEXANDER &CO. EXISTING PLANTER TO BE DEMOLITION DRAWINGS TO BE READ IN CONJUNCTION WITH DEMOLISHED EXISTING ROOFING, EAVES, SOFFIT, PROPOSED ARCHITECTURAL PACKAGE & SPECIFICATIONS. -FASCIAS AND GUTTERS AND ROOF EXISTING FINISH TO BE STRUCTURE TO BE DEMOLISHED DEMOLISHED ALL EXISTING FLOOR FINISHES, SUBSTRATES, MEMBRANES STRUCTURE TO BE TO BE REMOVED AS DOCUMENTED. RETAINED MAKE GOOD TO ALL STRUCTURAL ELEMENTS AND ENSURE EXISTING RETAINING WALL TO BE RETAINED STRUCTURAL INTEGRITY IS RETAINED. STRUCTURAL ENGINEER TO SIGN OFF AND APPROVE PRIOR TO ANY STRUCTURAL WORKS ALL HYDRAULIC LOCATIONS ARE INDICATIVE ONLY AND TO BE VERIFIED ON SITE; ALL WORKS TO BE MADE GOOD AND REROUTED AS PER PROPOSED DOCUMENTATION ALL EXISTING FIXTURES AND JOINERY TO BE REMOVED \_\_\_\_\_\_ UNLESS OTHERWISE DOCUMENTED ALL ELECTRICAL FITTINGS AND FIXTURES TO BE REMOVED INTERNALLY AND EXTERNALLY. CONTRACTOR TO ALLOW FOR NEW WIRING THROUGHOUT. CONTRACTOR TO ALLOW SUFFICIENT WEATHER PROTECTION & SITE PROTECTION TO MAINTAIN THE REMAINING PARTS OF THE DWELLING DURING EACH STAGE OF DEMOLITION AND CONSTRUCTION. RETAIN EXISTING HYDRAULIC CONNECTIONS AS DOCUMENTED ודום מוחודודום מוחודודום! REMOVE ALL EXISTING DOOR FRAMES TO ALL DOORS AS INDICATED DOORS WITH A DOOR NUMBER TO BE REMOVED BUT RETAINED IN PREPARATION FOR RELOCATION ON SITE. (|----|----|----|----|---|----|----| ALL SKIRTING AND ARCHITRAVES TO BE REMOVED. PATCH AND REPAIR WALL AS NECESSARY FOR NEW FINISH. ALL EXISTING REDUNDANT RETICULATION TO BE REMOVED. ----<del>-</del>----\_\_\_\_\_\_ 0 0 (Հայ հայ հայ հայ արագրագրության արգագրությանը հայ հայ հայ հայիսակությանը արագրագրությանը հայ հայ արագրությանը -----1||----| · - -|- -<sub>\*</sub>-| EXISTING ROOF STRUCTURE TO BE DEMOLISHED EXISTING GLASS BALUSTRADE TO BE DEMOLISHED EXISTING PLANTER TO BE DEMOLISHED EXISTING FLOOR FINISH BE DEMOLISHED ROOF STRUCTURE TO BE RETAINED EXISTING ROOFING, EAVES, SOFFIT, FASCIAS AND GUTTERS TO BE EXISTING PLANTER TO BE DEMOLISHED DEMOLISHED ROOF STRUCTURE TO BE RETAINED EXISTING STEPS TO BE DEMOLISHED DA COMPLIANCE LEGEND DA MATERIAL CUT HATCHING DA MATERIAL SURFACE HATCHING DA SHADOW STUDY DESCRIPTION LEGEND - DA ALEXANDER HOUSE DRAWING TITLE 1. ALL WORKS TO BE IN ACCORDANCE WITH THE NATIONAL CONSTRUCTION CODE, KISTING BUILDING 63 BRISBANE STREET, BONDI JUNCTION TRACEY & JAMES TO BE DEMOLISHED **ROOF - GENERAL** FOR DA SUBMISSION PLANE 8.5M 3D AUSTRALIAN STANDARDS AND LOCAL AUTHORITY REQUIREMENTS, INCLUDING OPEN SPACE AREA NSW 2022 18/7/2024 FOR \$4.55 SUBMISSION COUNCIL CONDITIONS OF CONSENT MAX. HEIGHT PLANE 8.5M 2D **ARRANGEMENT PLAN -**ALEXANDER &CO. 2. DO NOT SCALE OFF THIS DRAWING. USE ONLY DIMENSIONS PROVIDED SPACE AREA **EXISTING & DEMOLITION** T +61 (02) 8394 9838 3. A&CO DRAWINGS ARE TO BE READ IN CONJUNCTION WITH ALL CONTRACT DEMOLISHED PROJECT: MAX. SHEAR WALL PLANE 7M 3D CONCRETE EXISTING LEP LANDSCAPE - TILE www.alexanderand.co ABN 11 162 041 929 DOCUMENTS FROM ALL CONSULTANTS **BOWER HOUSE** 4. ALL DIMENSIONS TO BE CHECKED ON SITE PRIOR TO THE COMMENCEMENT OF MAX. SHEAR WALL PLANE 8.5M 2D 38 BOWER ST MANLY, BE REMOVED; INCLUDING FRAMES AND ARCHITRAVES.

NSW 2095

SCALE 1:50 @ A1

0567-2004-[B]

PROJECT NO. - DWG NO.\_REV.

NOMINATED ARCHITECT: **JEREMY BULL** 

JEREMY BULL | NUMBER DEP0001029

NSW REGISTRATION NO. 7881

CLASS 2 DESIGN PRACTITIONER:

**DEMOLITION** 

ALL DEMOLITION WORK IN ACCORDANCE WITH THE NATIONAL

**DISCLAIMER:**THE COPYRIGHT OF THIS DRAWING TOGETHER WITH ANY DOCUMENTS PREPARED BY

A&CO PTY. LTD REMAINS THE PROPERTY OF A&CO PTY. LTD. A&CO PTY. LTD GRANTS


INTENDED. THE LICENCE IS NOT TRANSFERABLE WITHOUT THE PERMISSION OF A&CO


LICENCE FOR THE USE OF THIS DOCUMENT FOR THE PURPOSE FOR WHICH IT IS


BIMcloud: ALEX-BIM-SERVER - BIMcloud/0567\_38 Bower St, Manly/0567\_38 Bower St\_S4.55

SETBACK CONTROLS

MAKE GOOD OPENING AND REVEALS

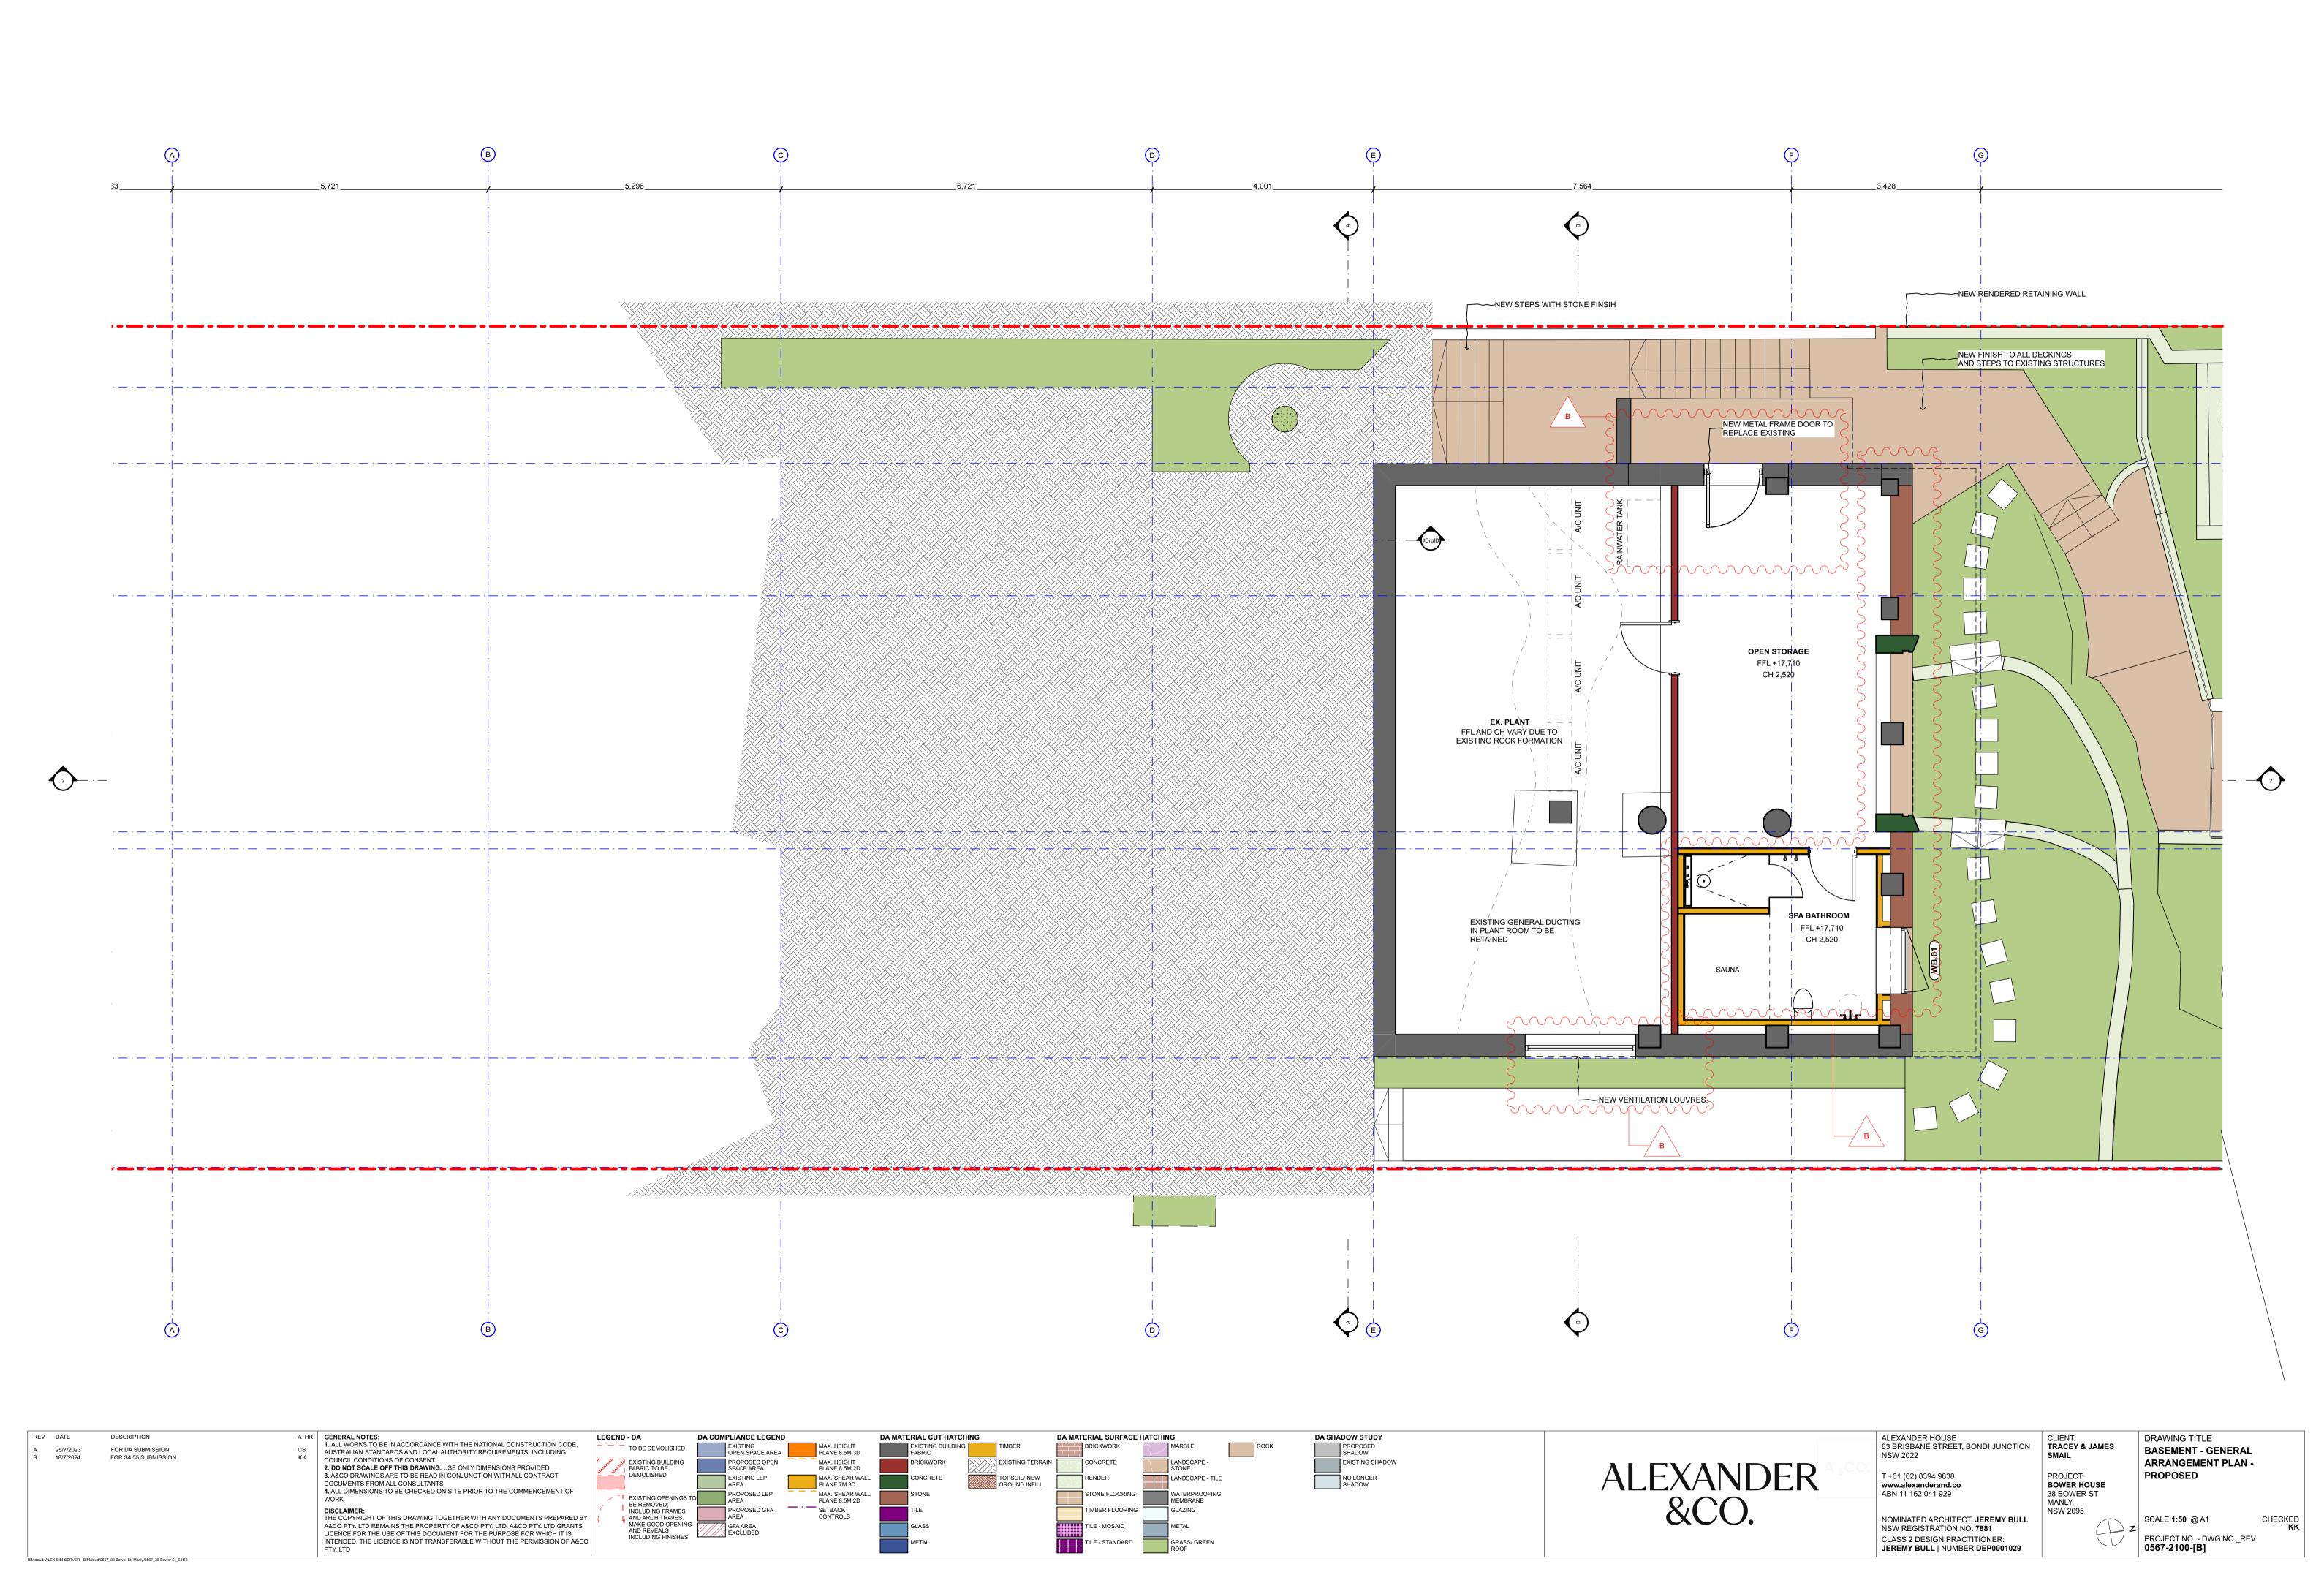

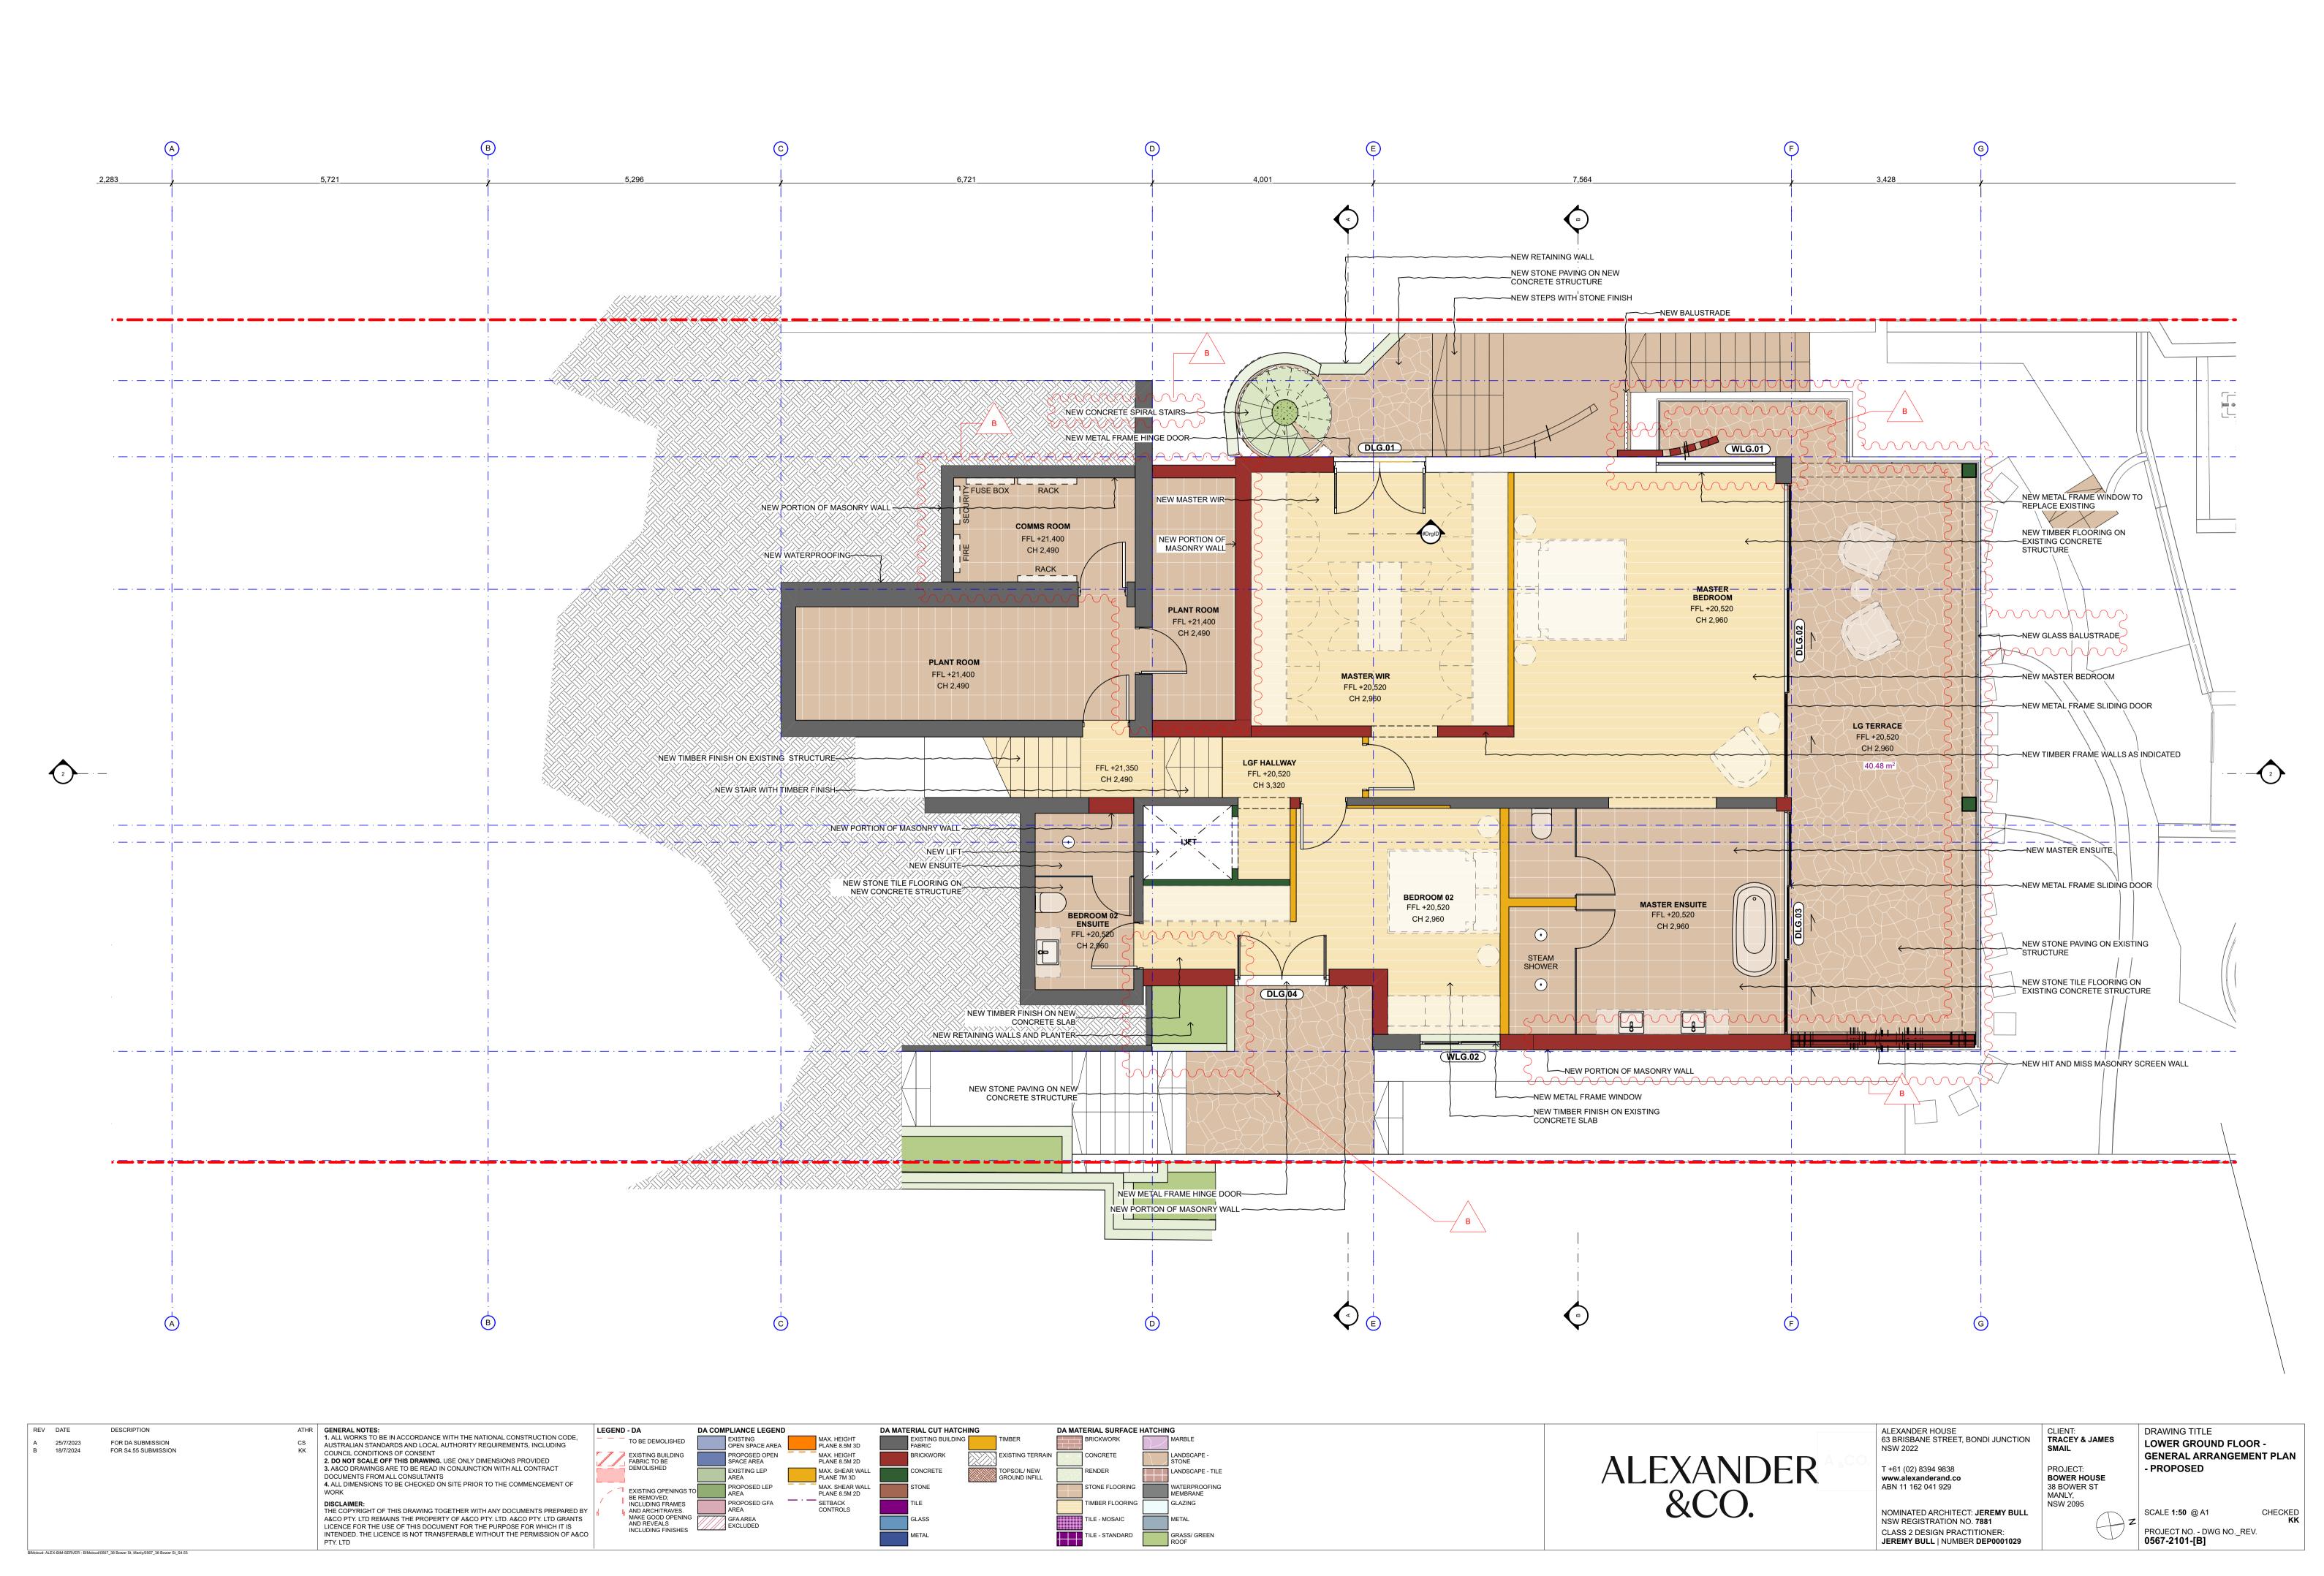


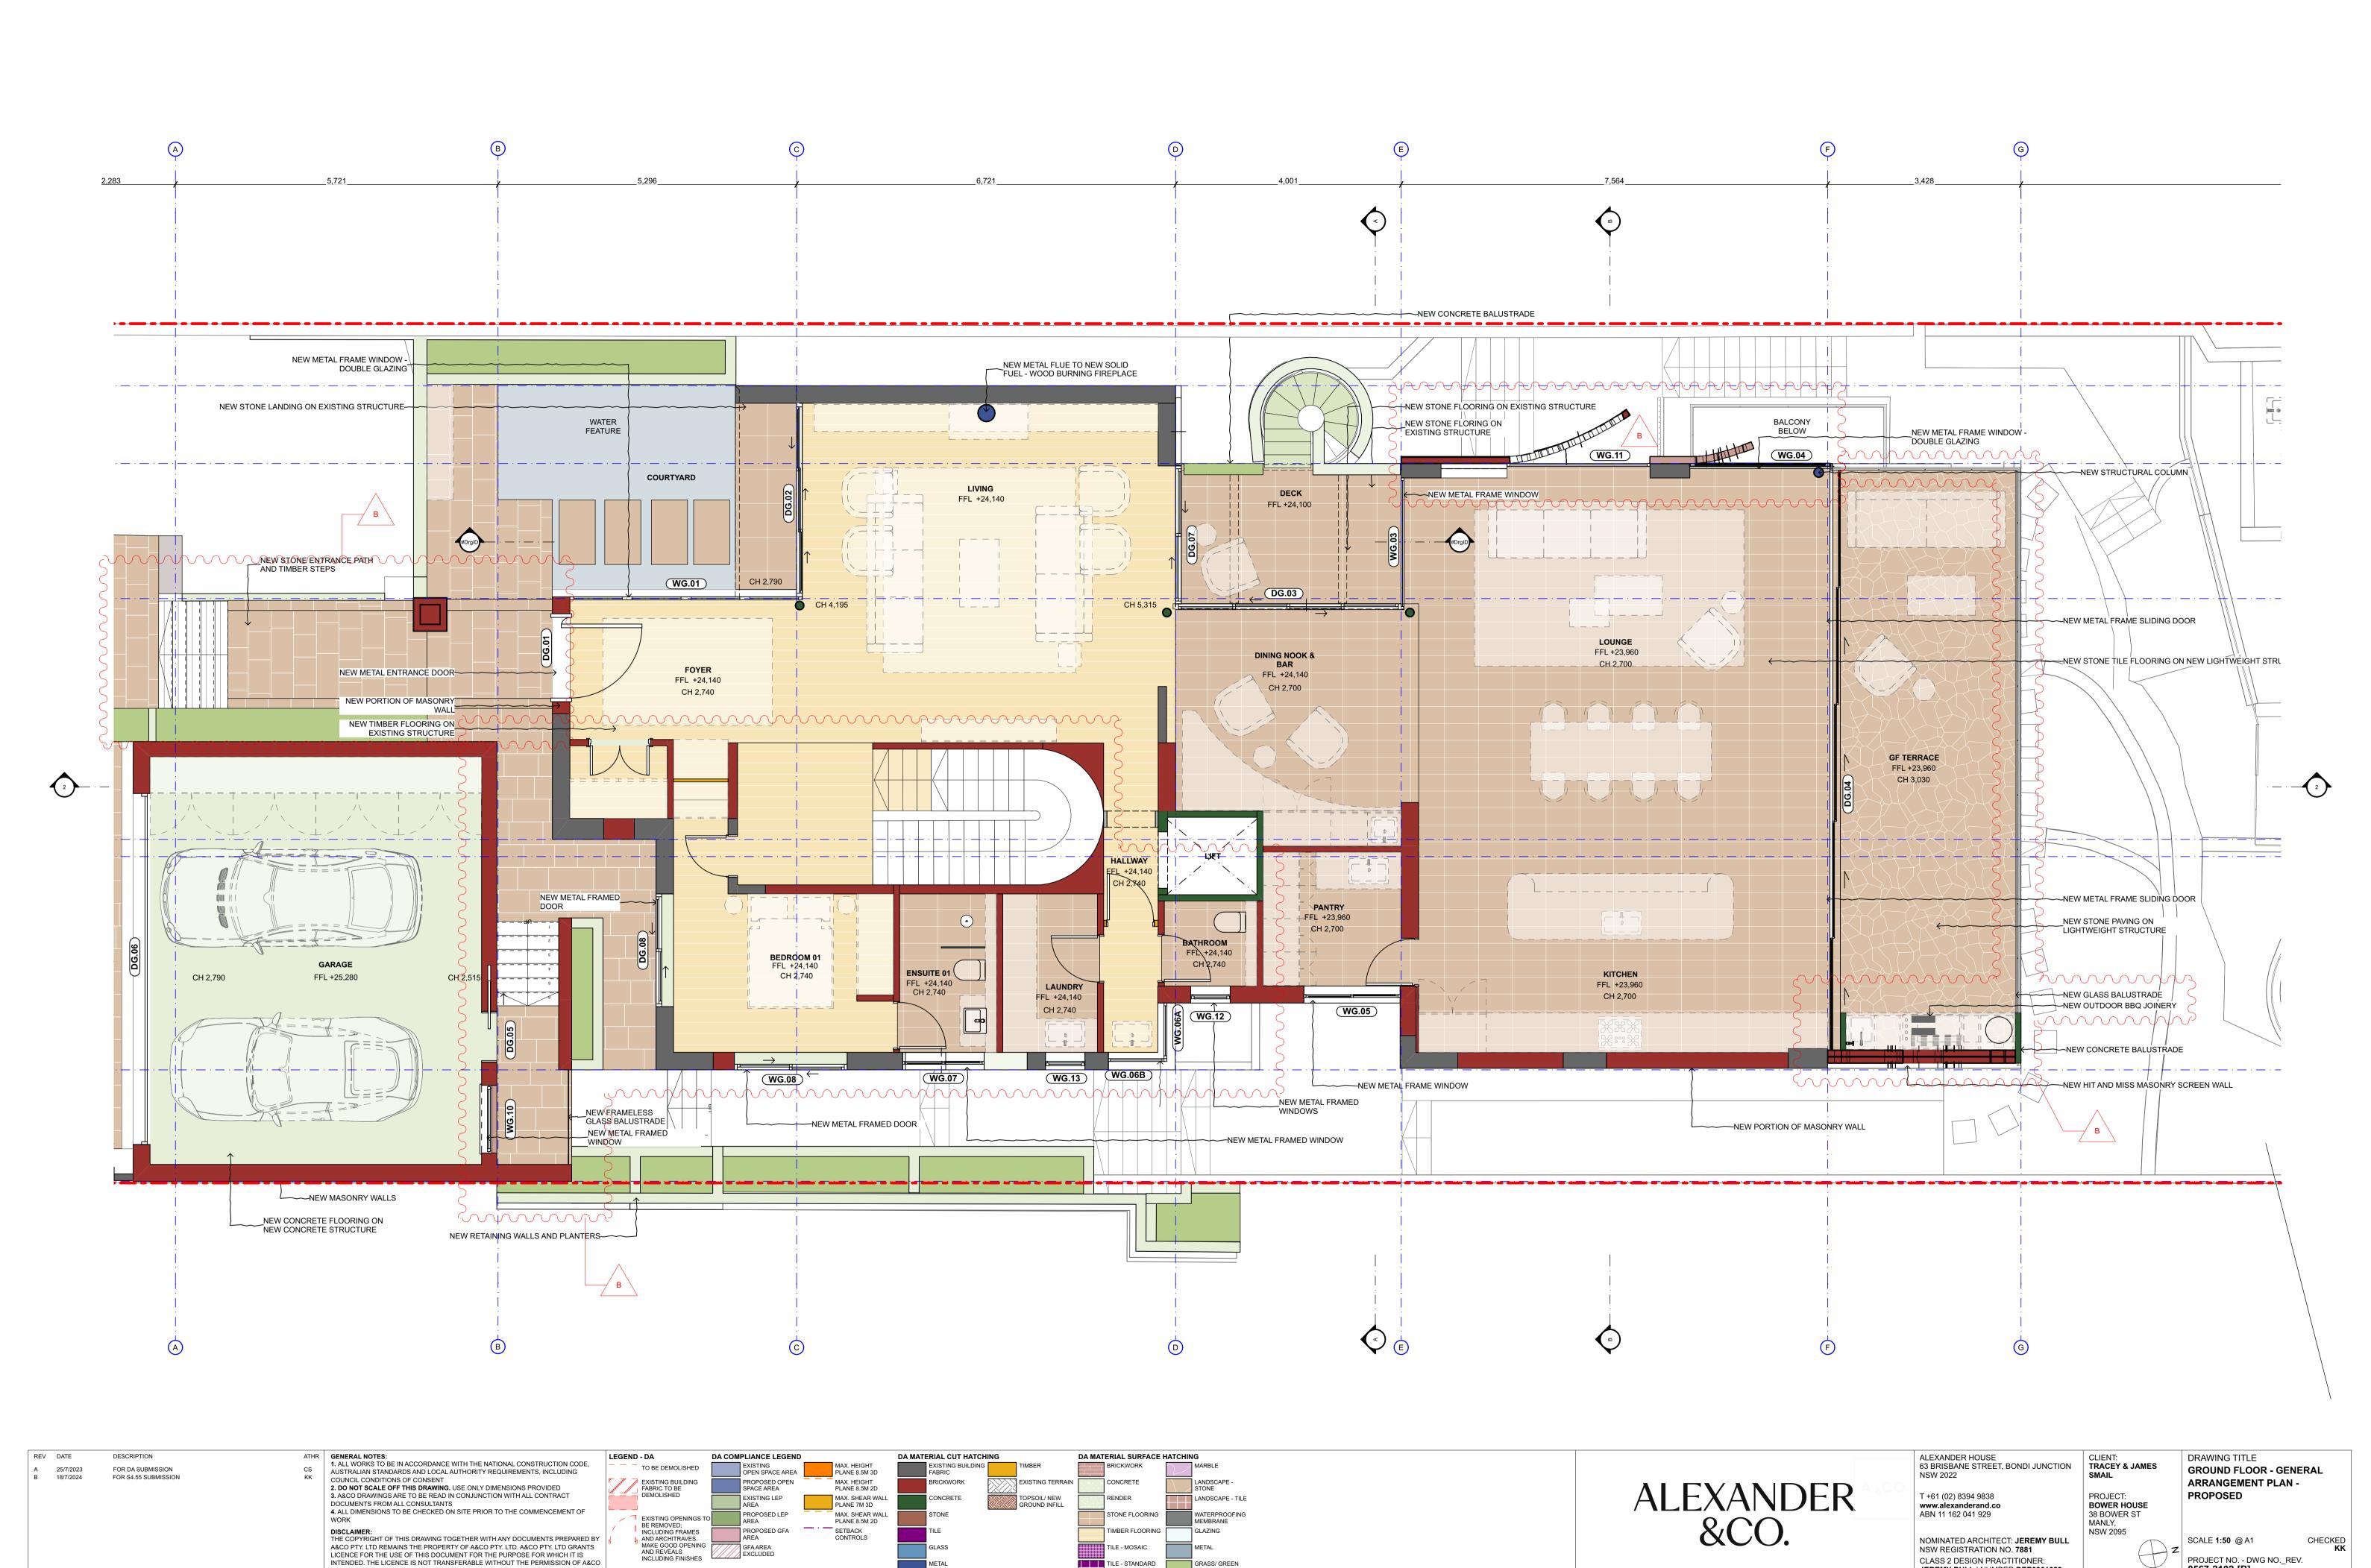


BIMcloud: ALEX-BIM-SERVER - BIMcloud/0567\_38 Bower St, Manly/0567\_38 Bower St\_S4.55

JEREMY BULL | NUMBER DEP0001029

0567-2102-[B]

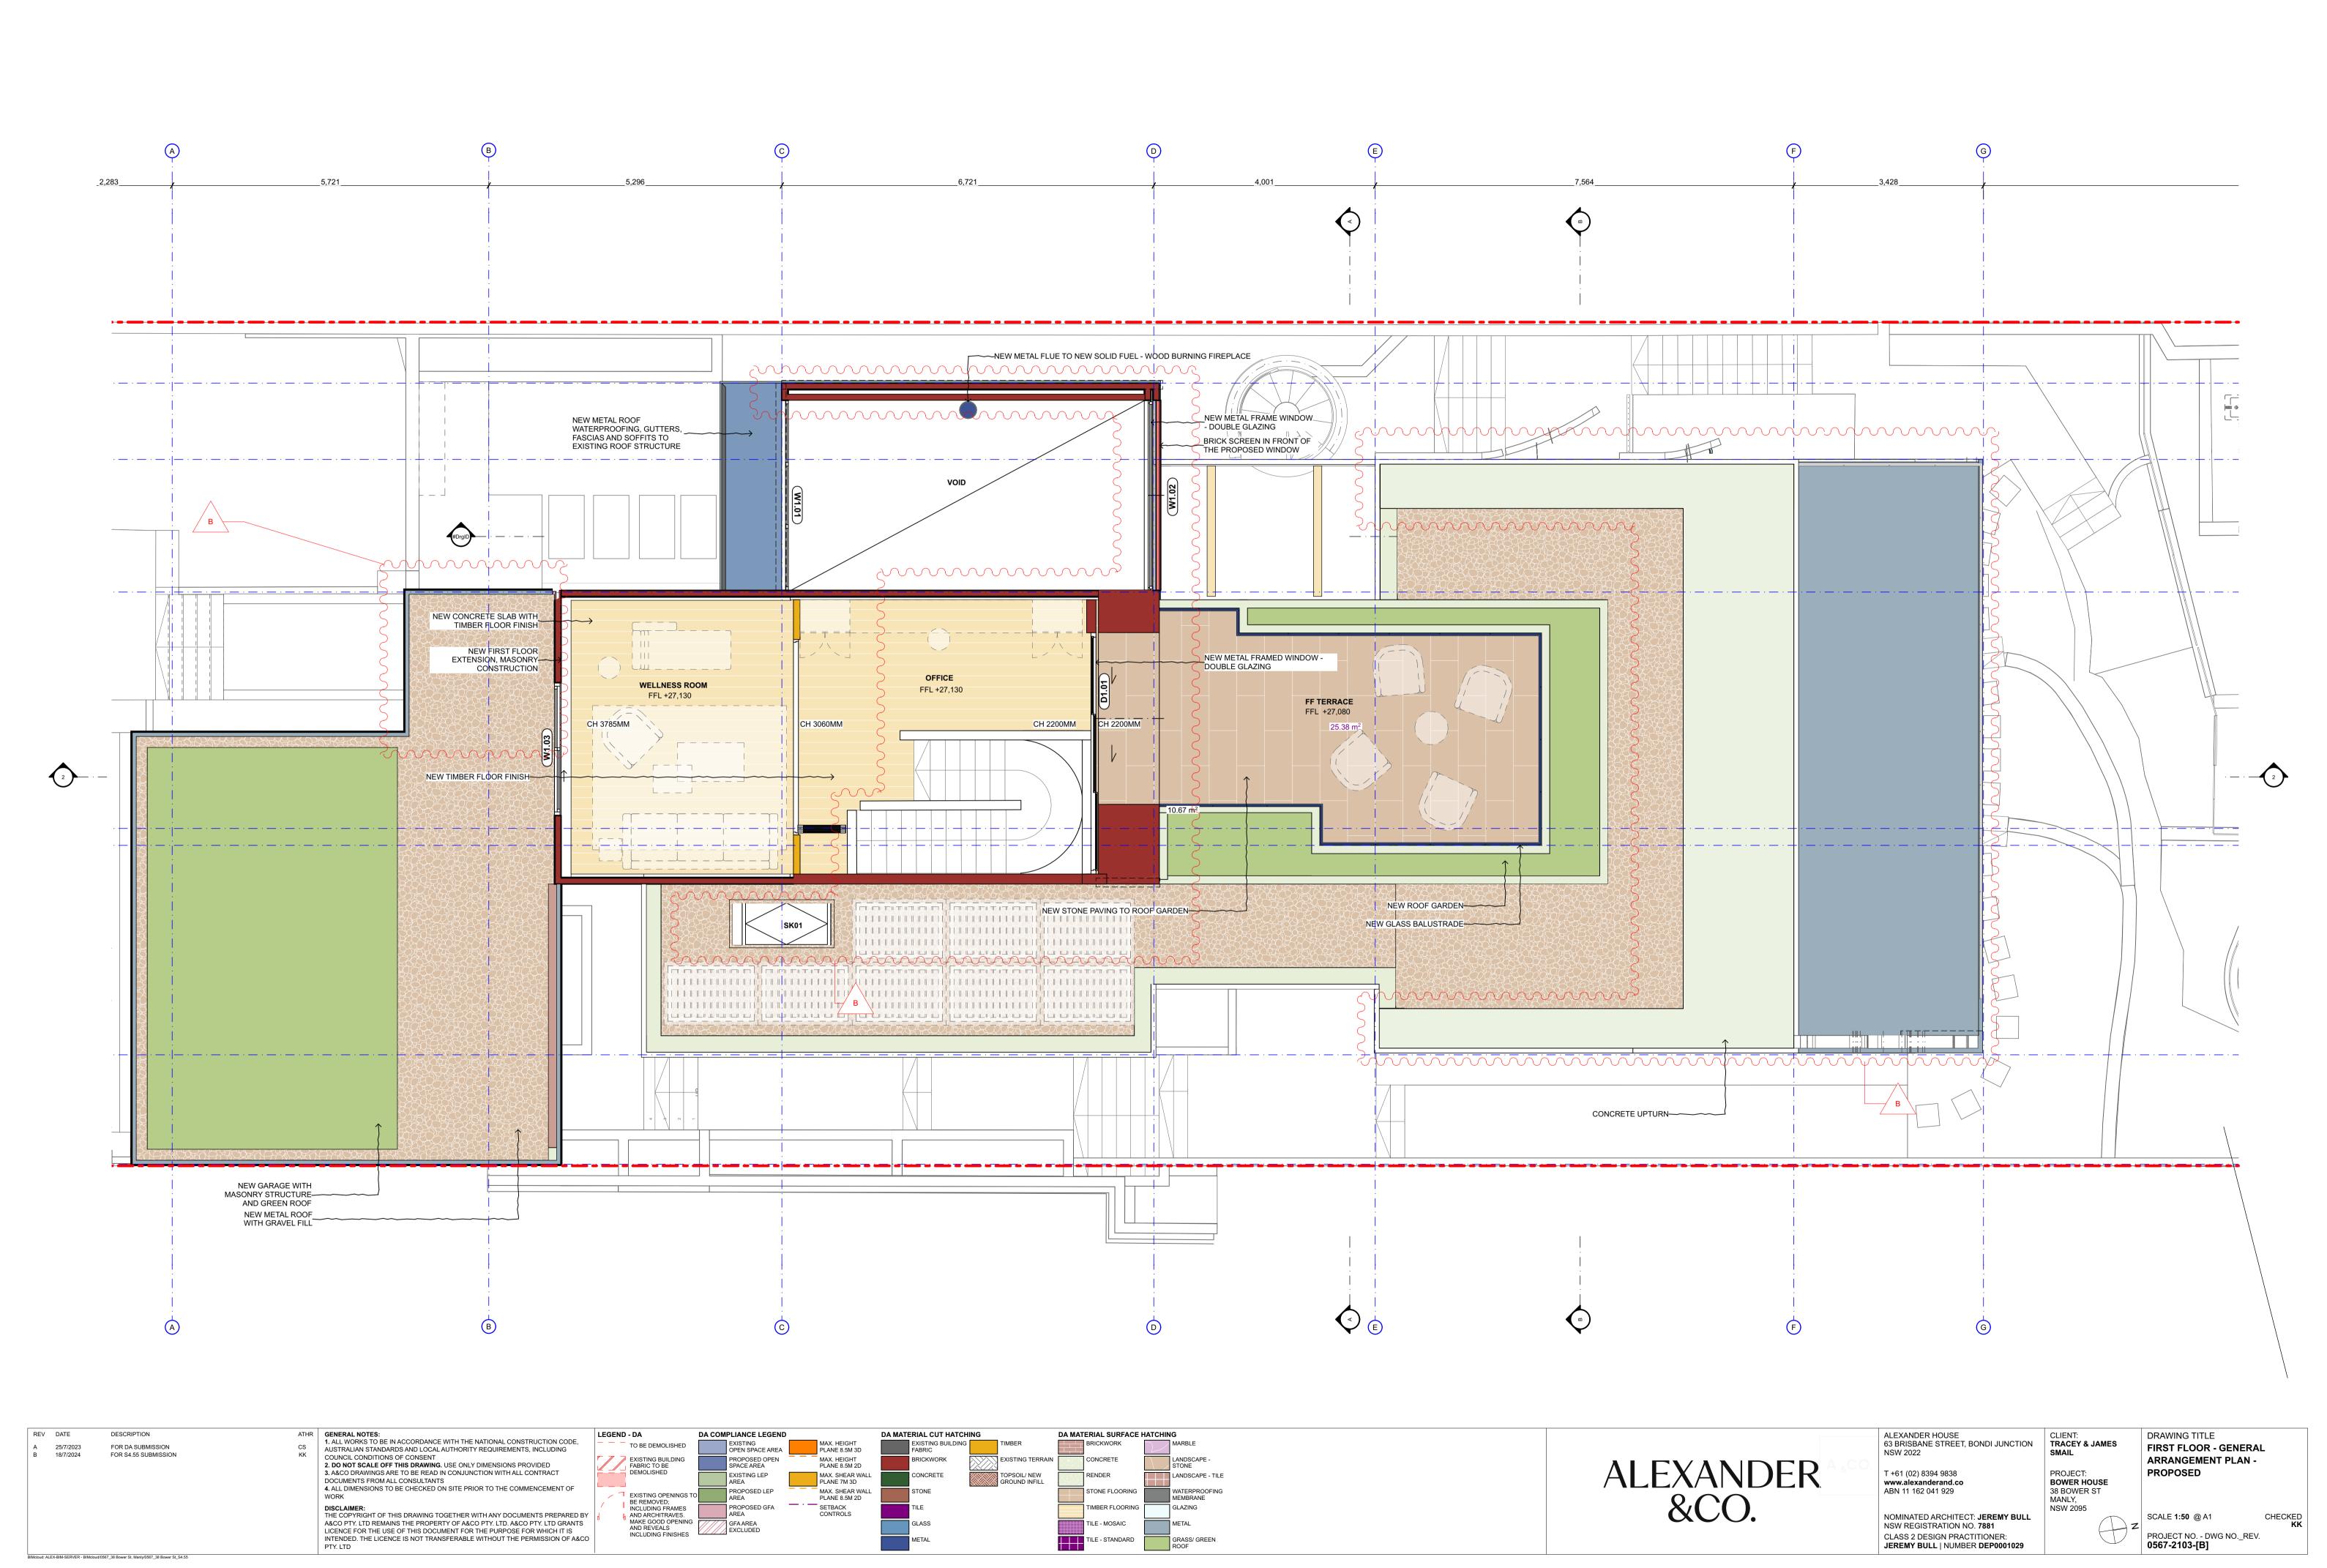

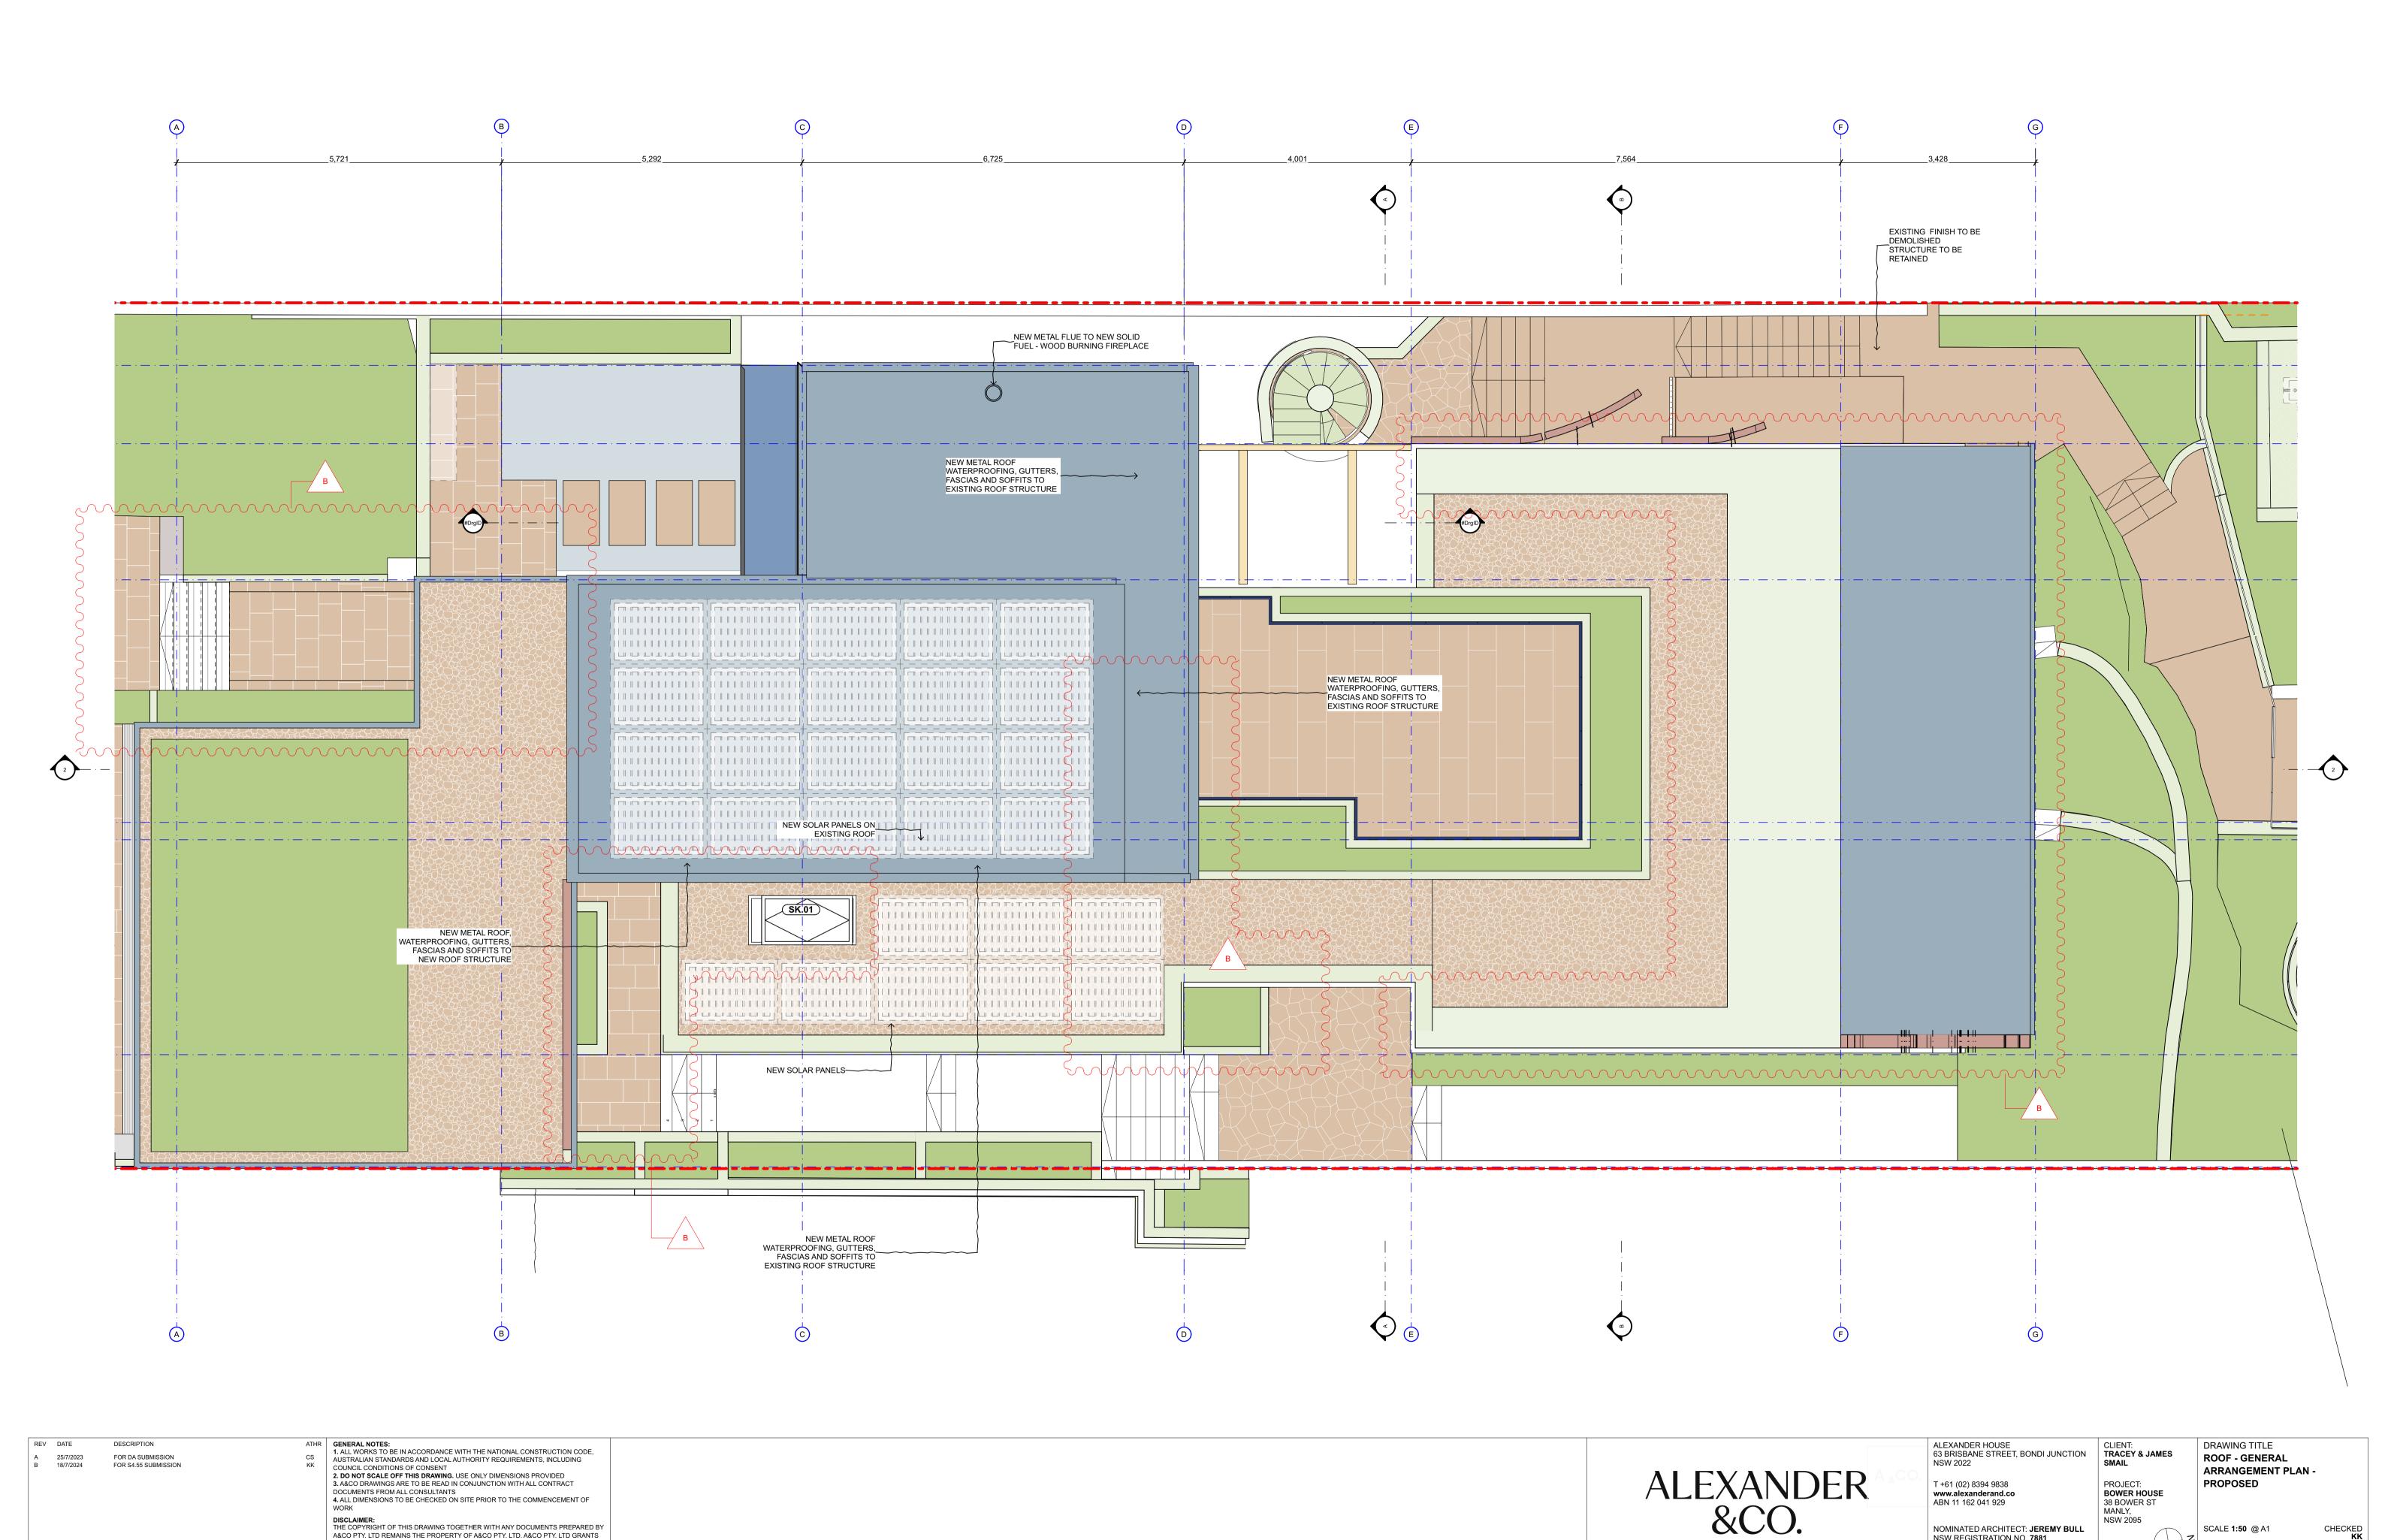

**DISCLAIMER:**THE COPYRIGHT OF THIS DRAWING TOGETHER WITH ANY DOCUMENTS PREPARED BY

A&CO PTY. LTD REMAINS THE PROPERTY OF A&CO PTY. LTD. A&CO PTY. LTD GRANTS

LICENCE FOR THE USE OF THIS DOCUMENT FOR THE PURPOSE FOR WHICH IT IS INTENDED. THE LICENCE IS NOT TRANSFERABLE WITHOUT THE PERMISSION OF A&CO

BIMcloud: ALEX-BIM-SERVER - BIMcloud/0567\_38 Bower St, Manly/0567\_38 Bower St\_S4.55

MANLY,

NOMINATED ARCHITECT: JEREMY BULL

NSW REGISTRATION NO. 7881

CLASS 2 DESIGN PRACTITIONER:


JEREMY BULL | NUMBER DEP0001029


NSW 2095


SCALE 1:50 @ A1


0567-2104-[B]


PROJECT NO. - DWG NO.\_REV.

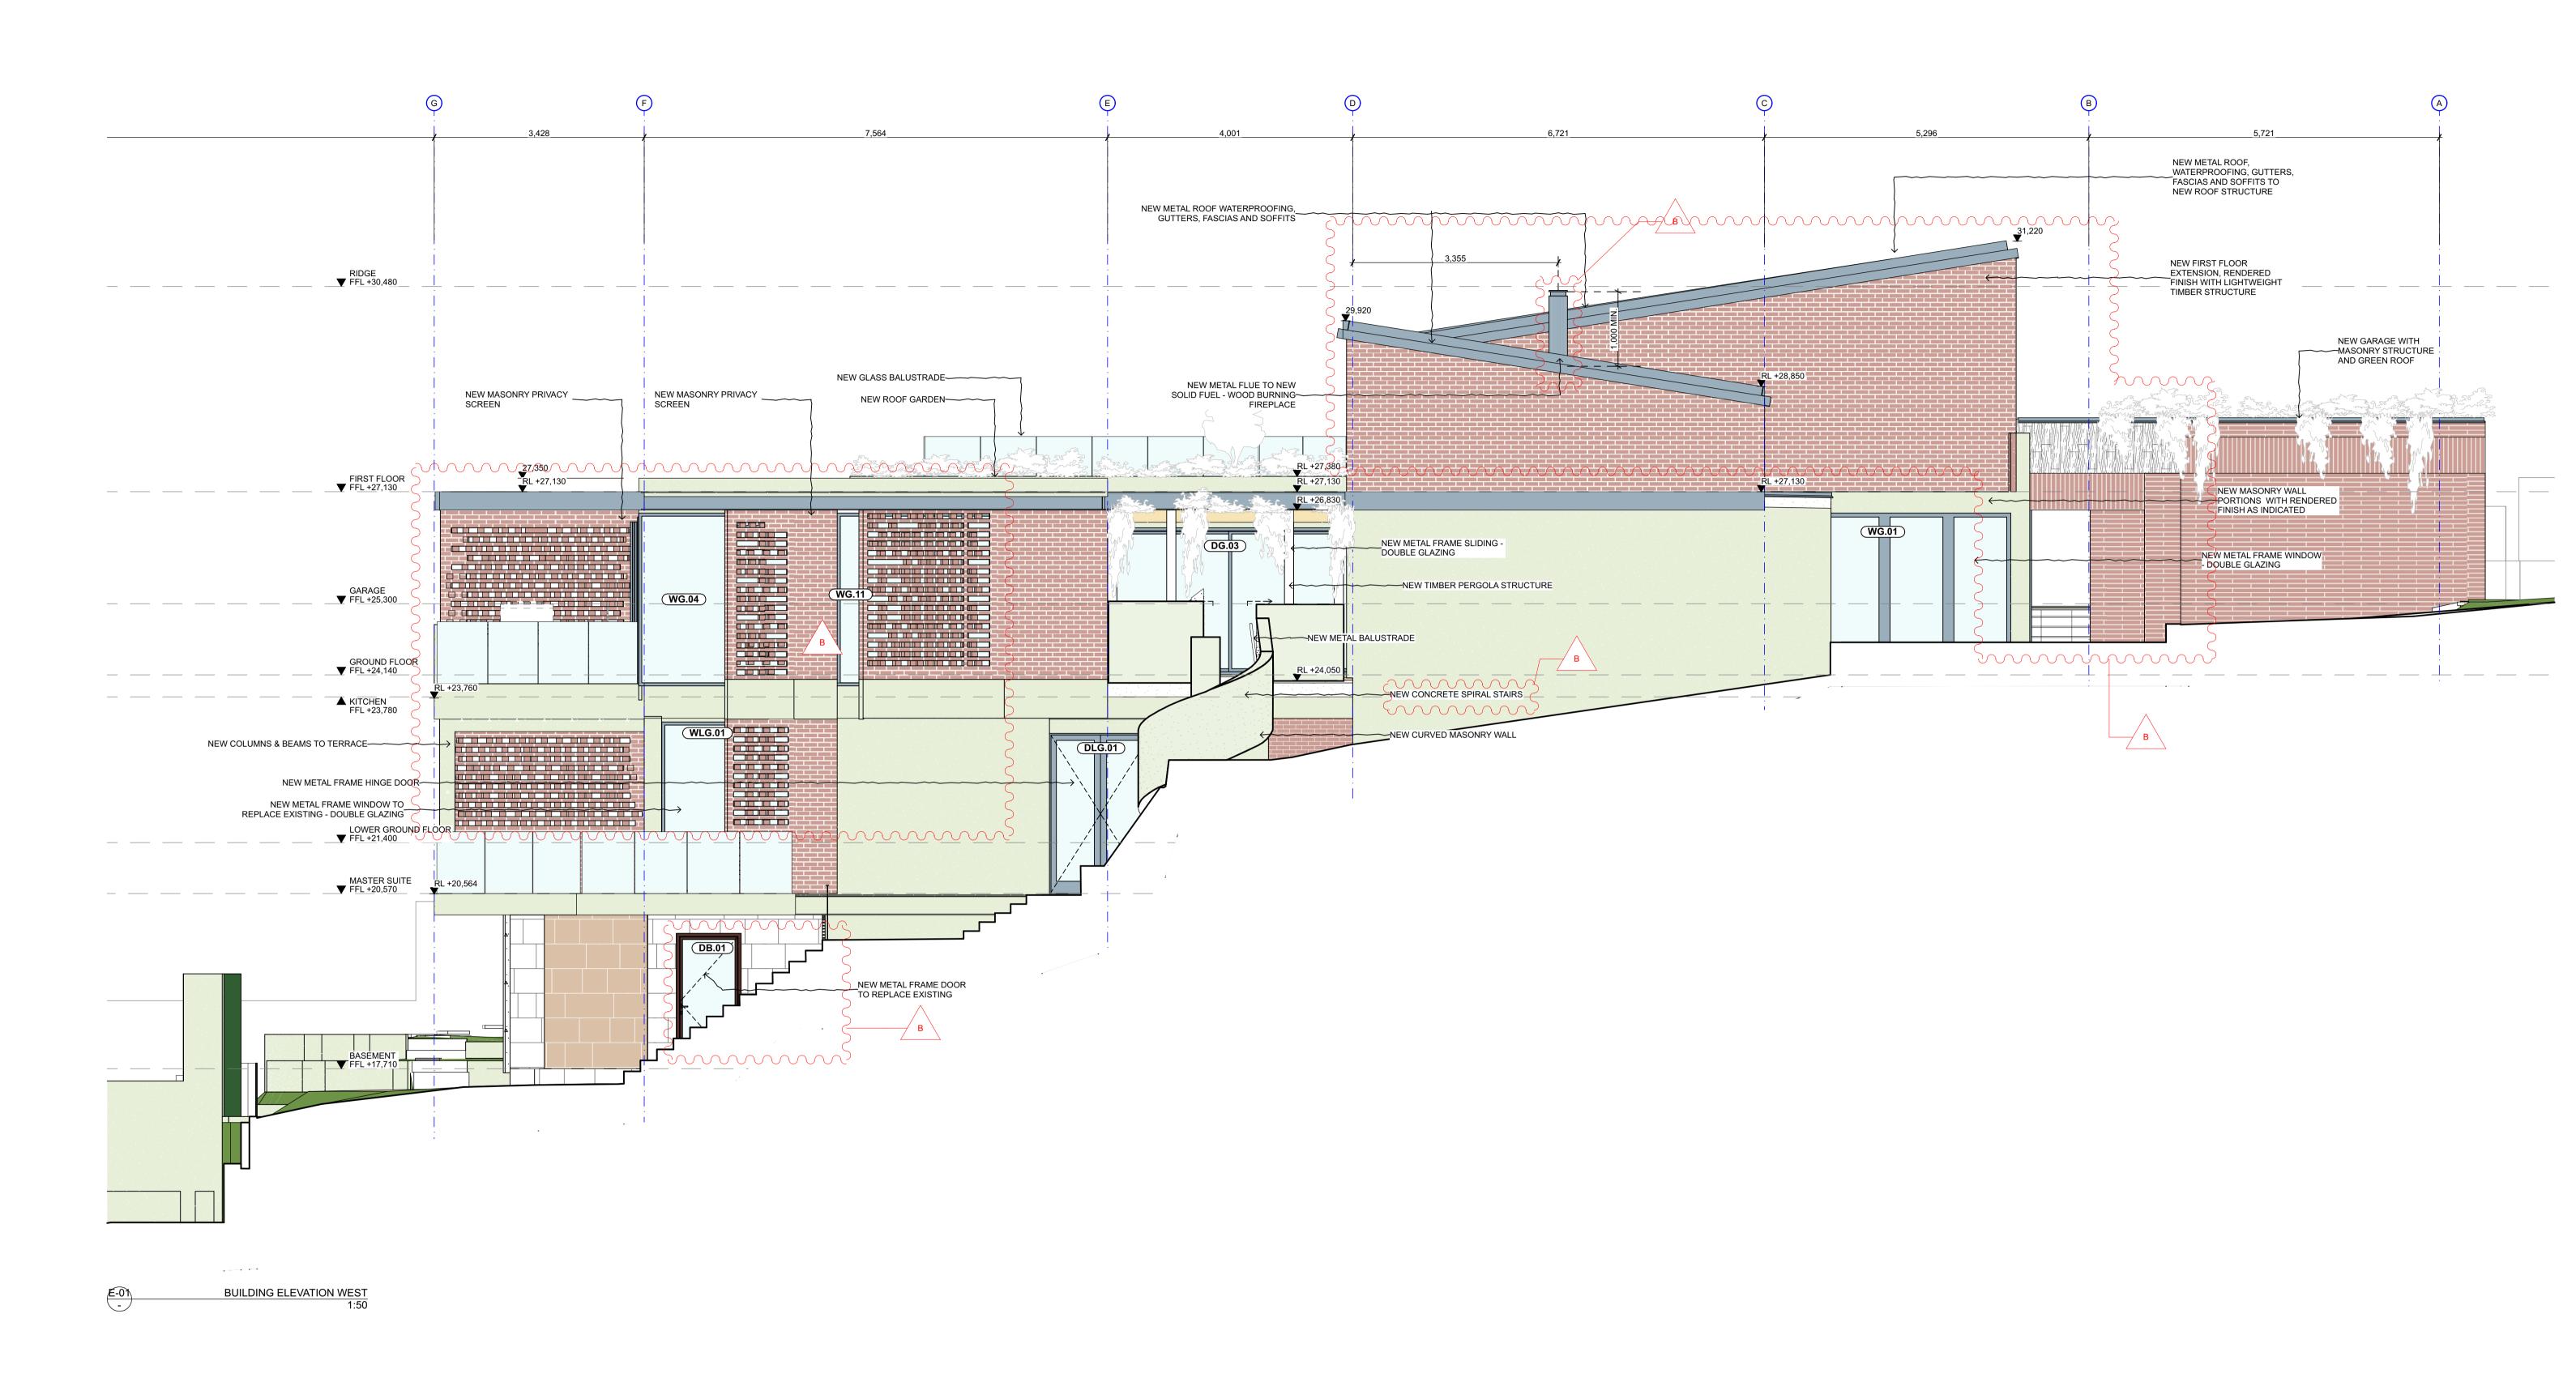


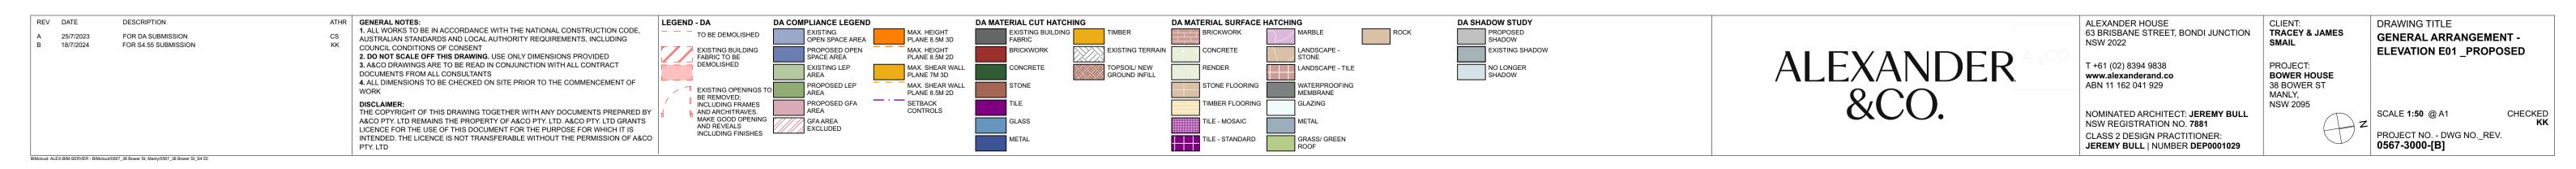


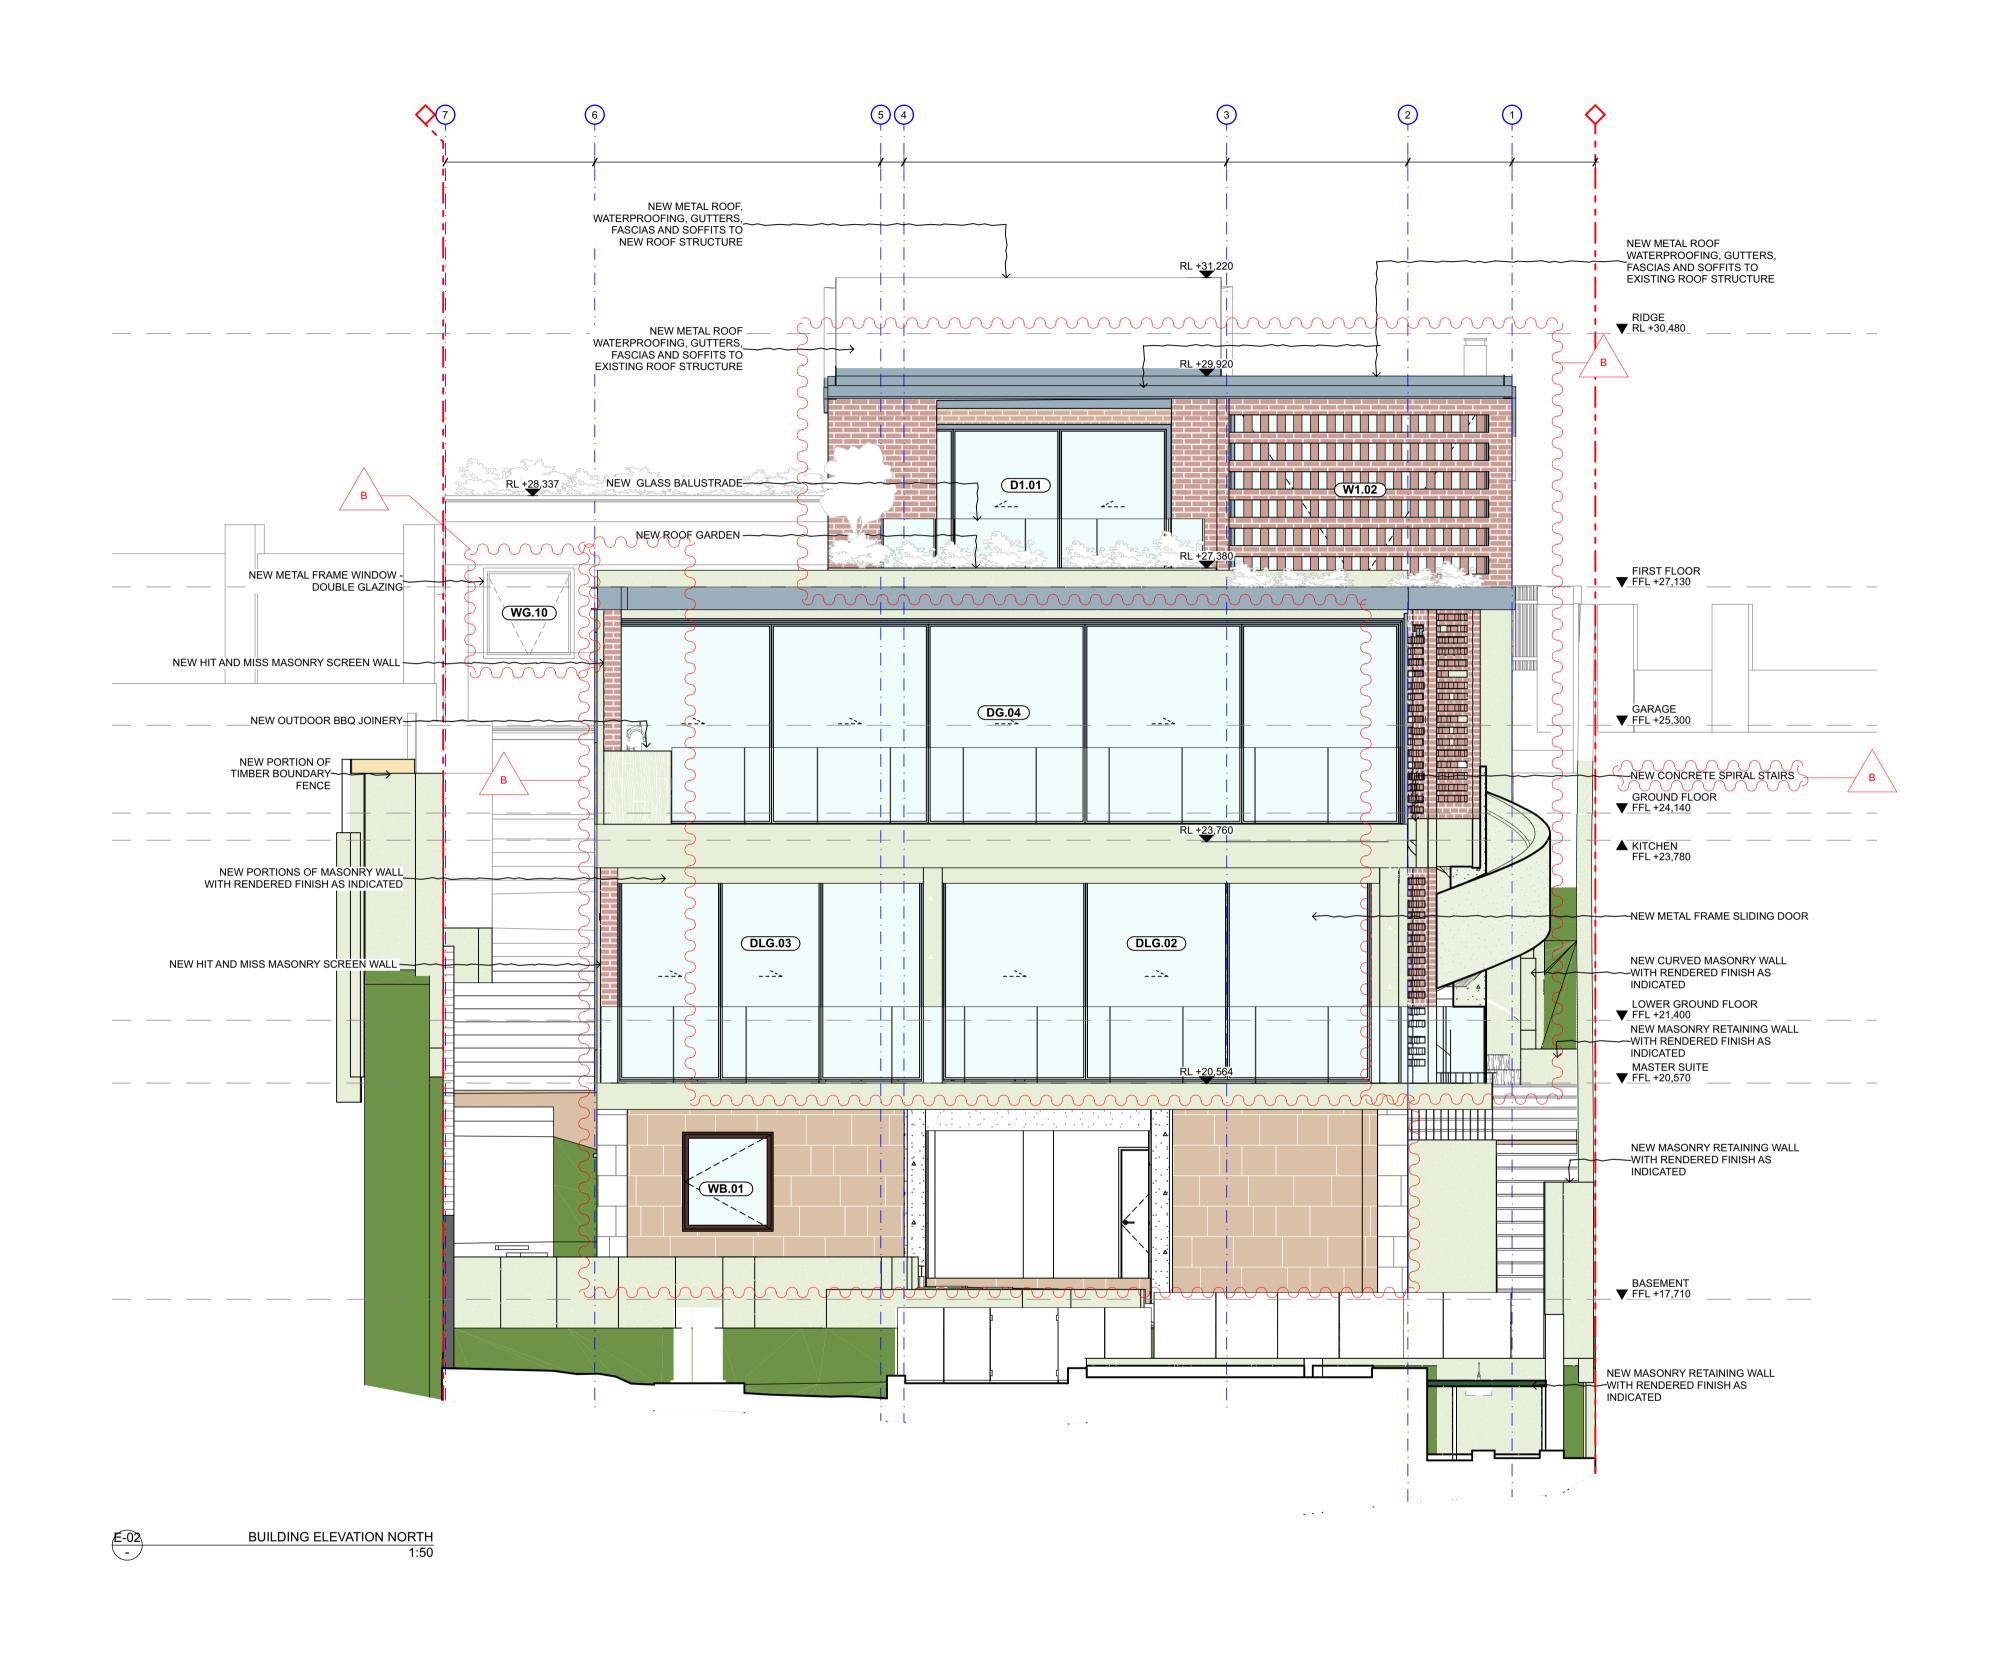


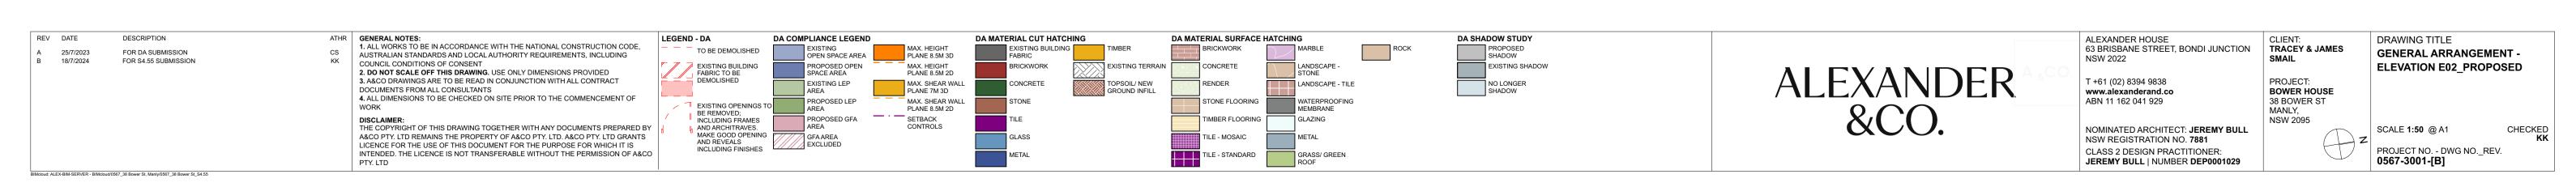


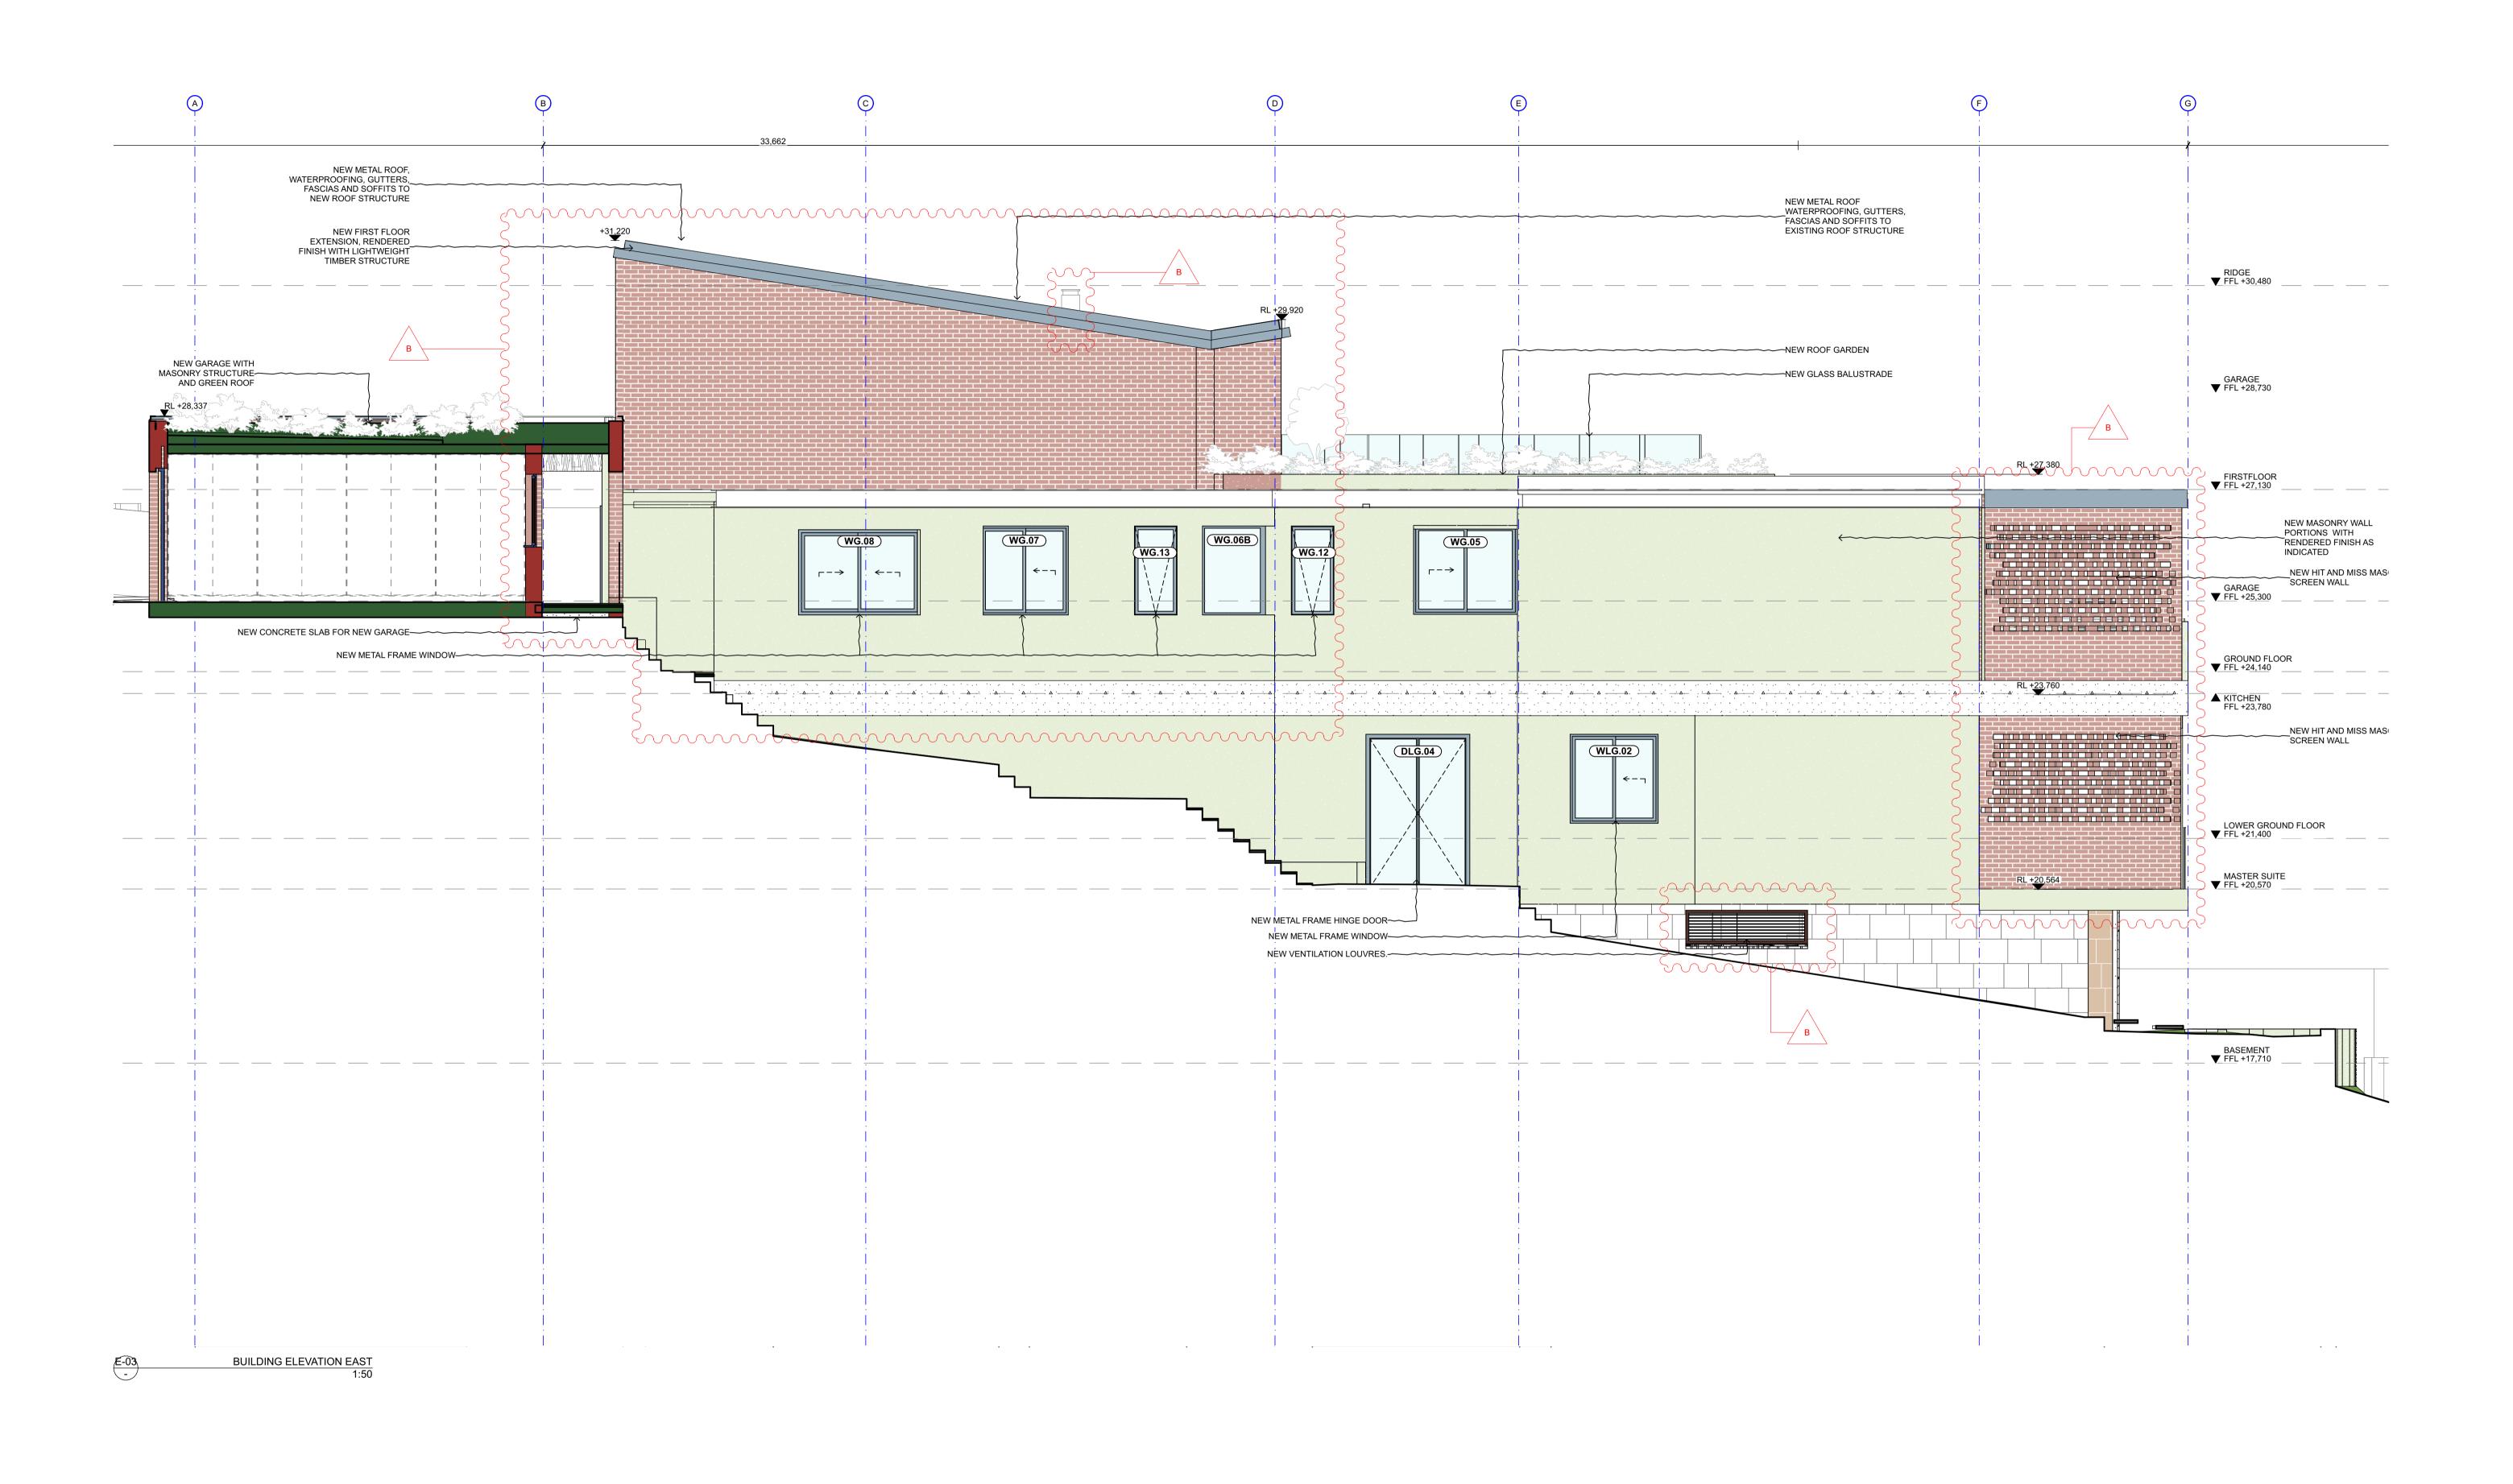

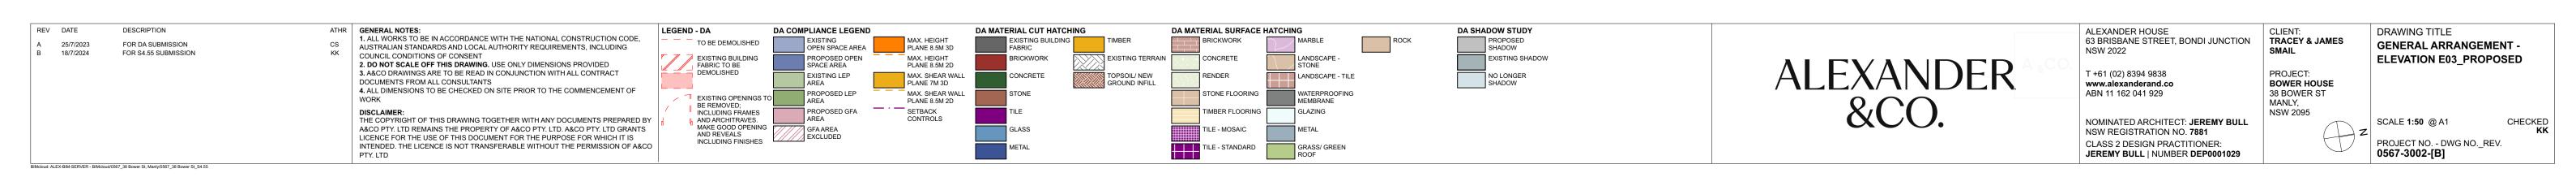

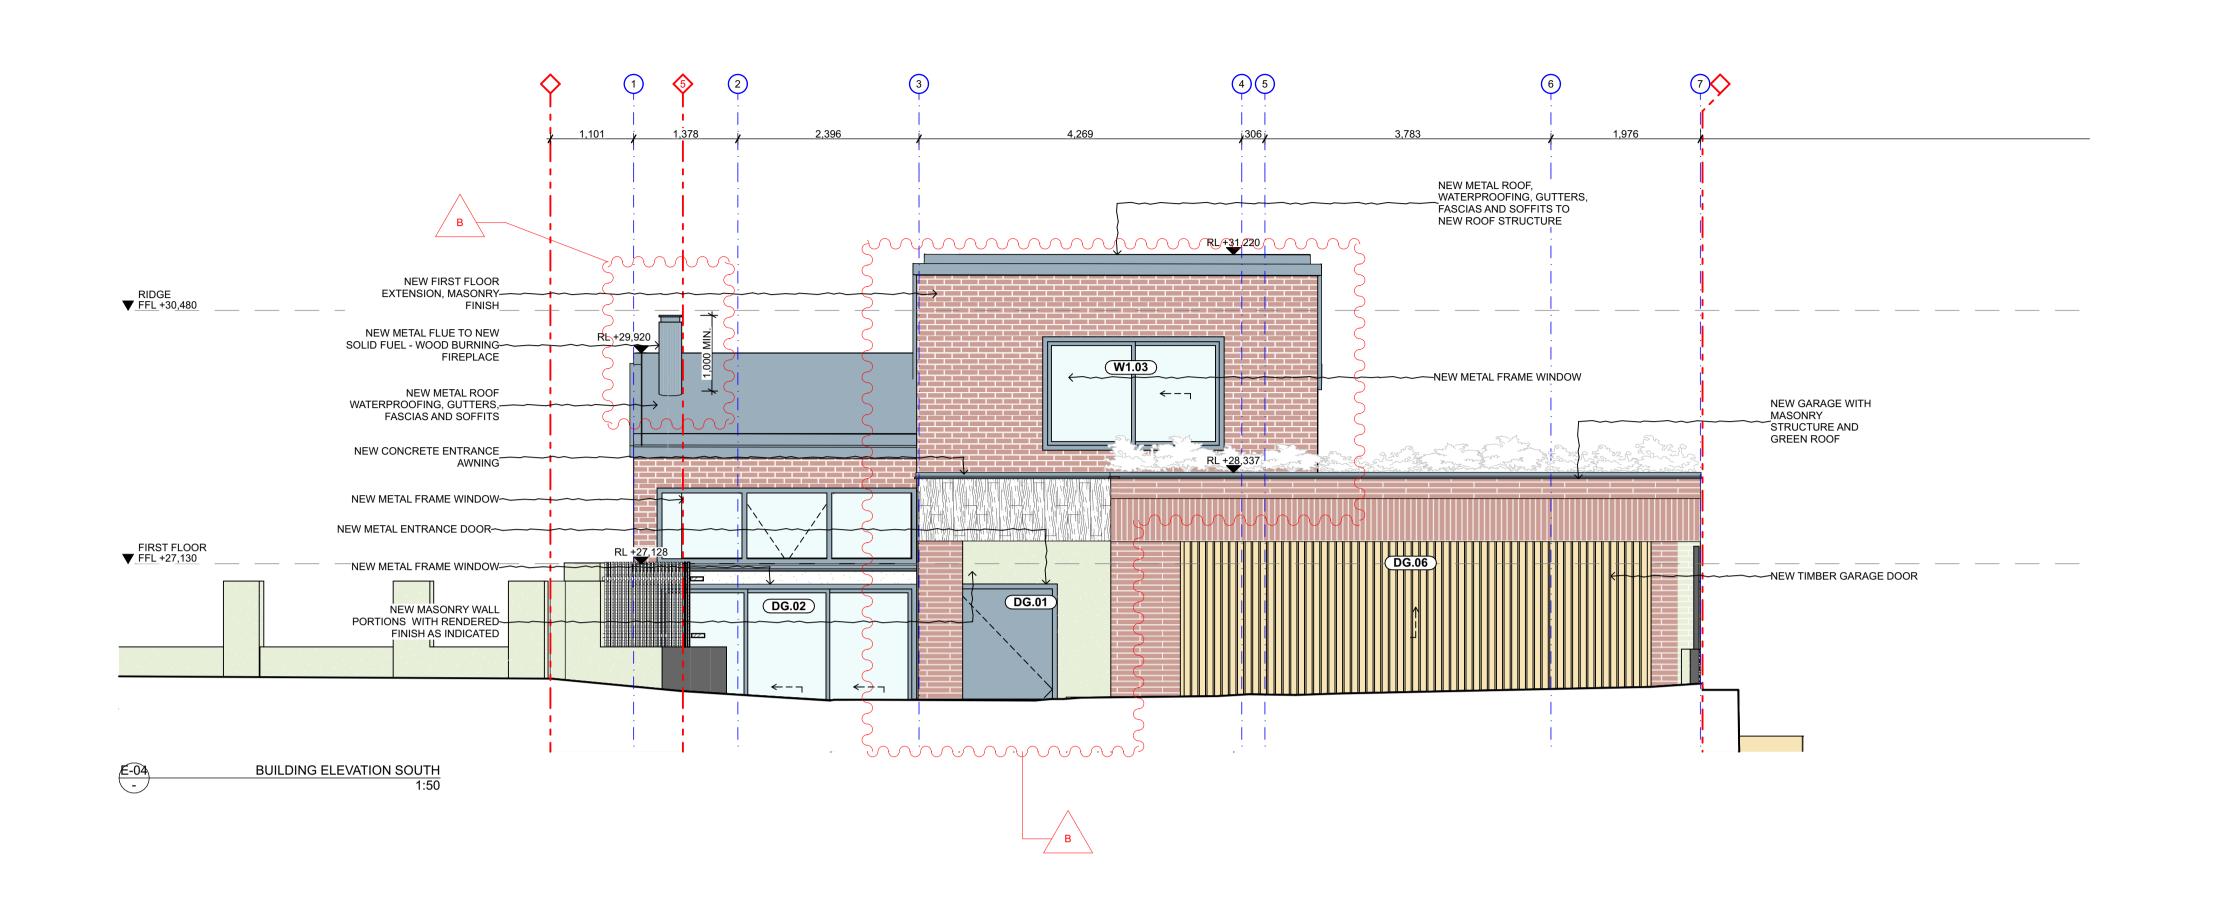

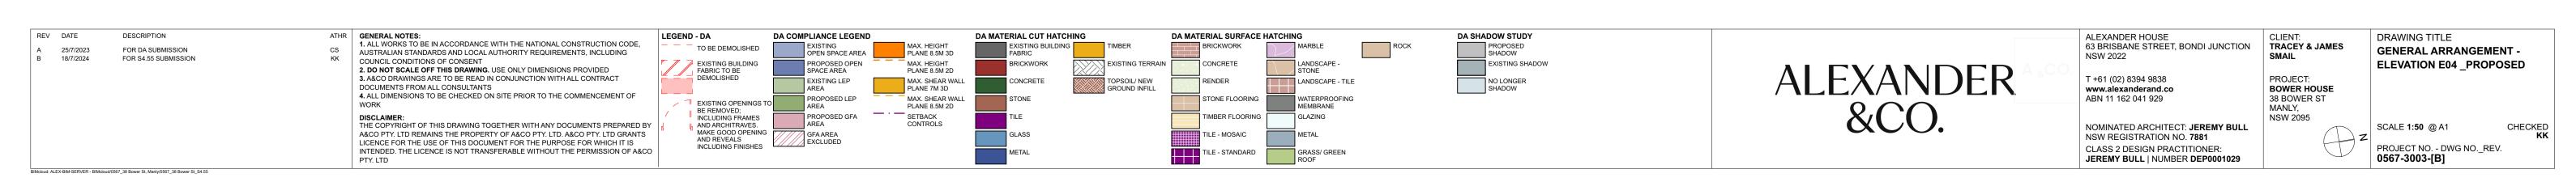

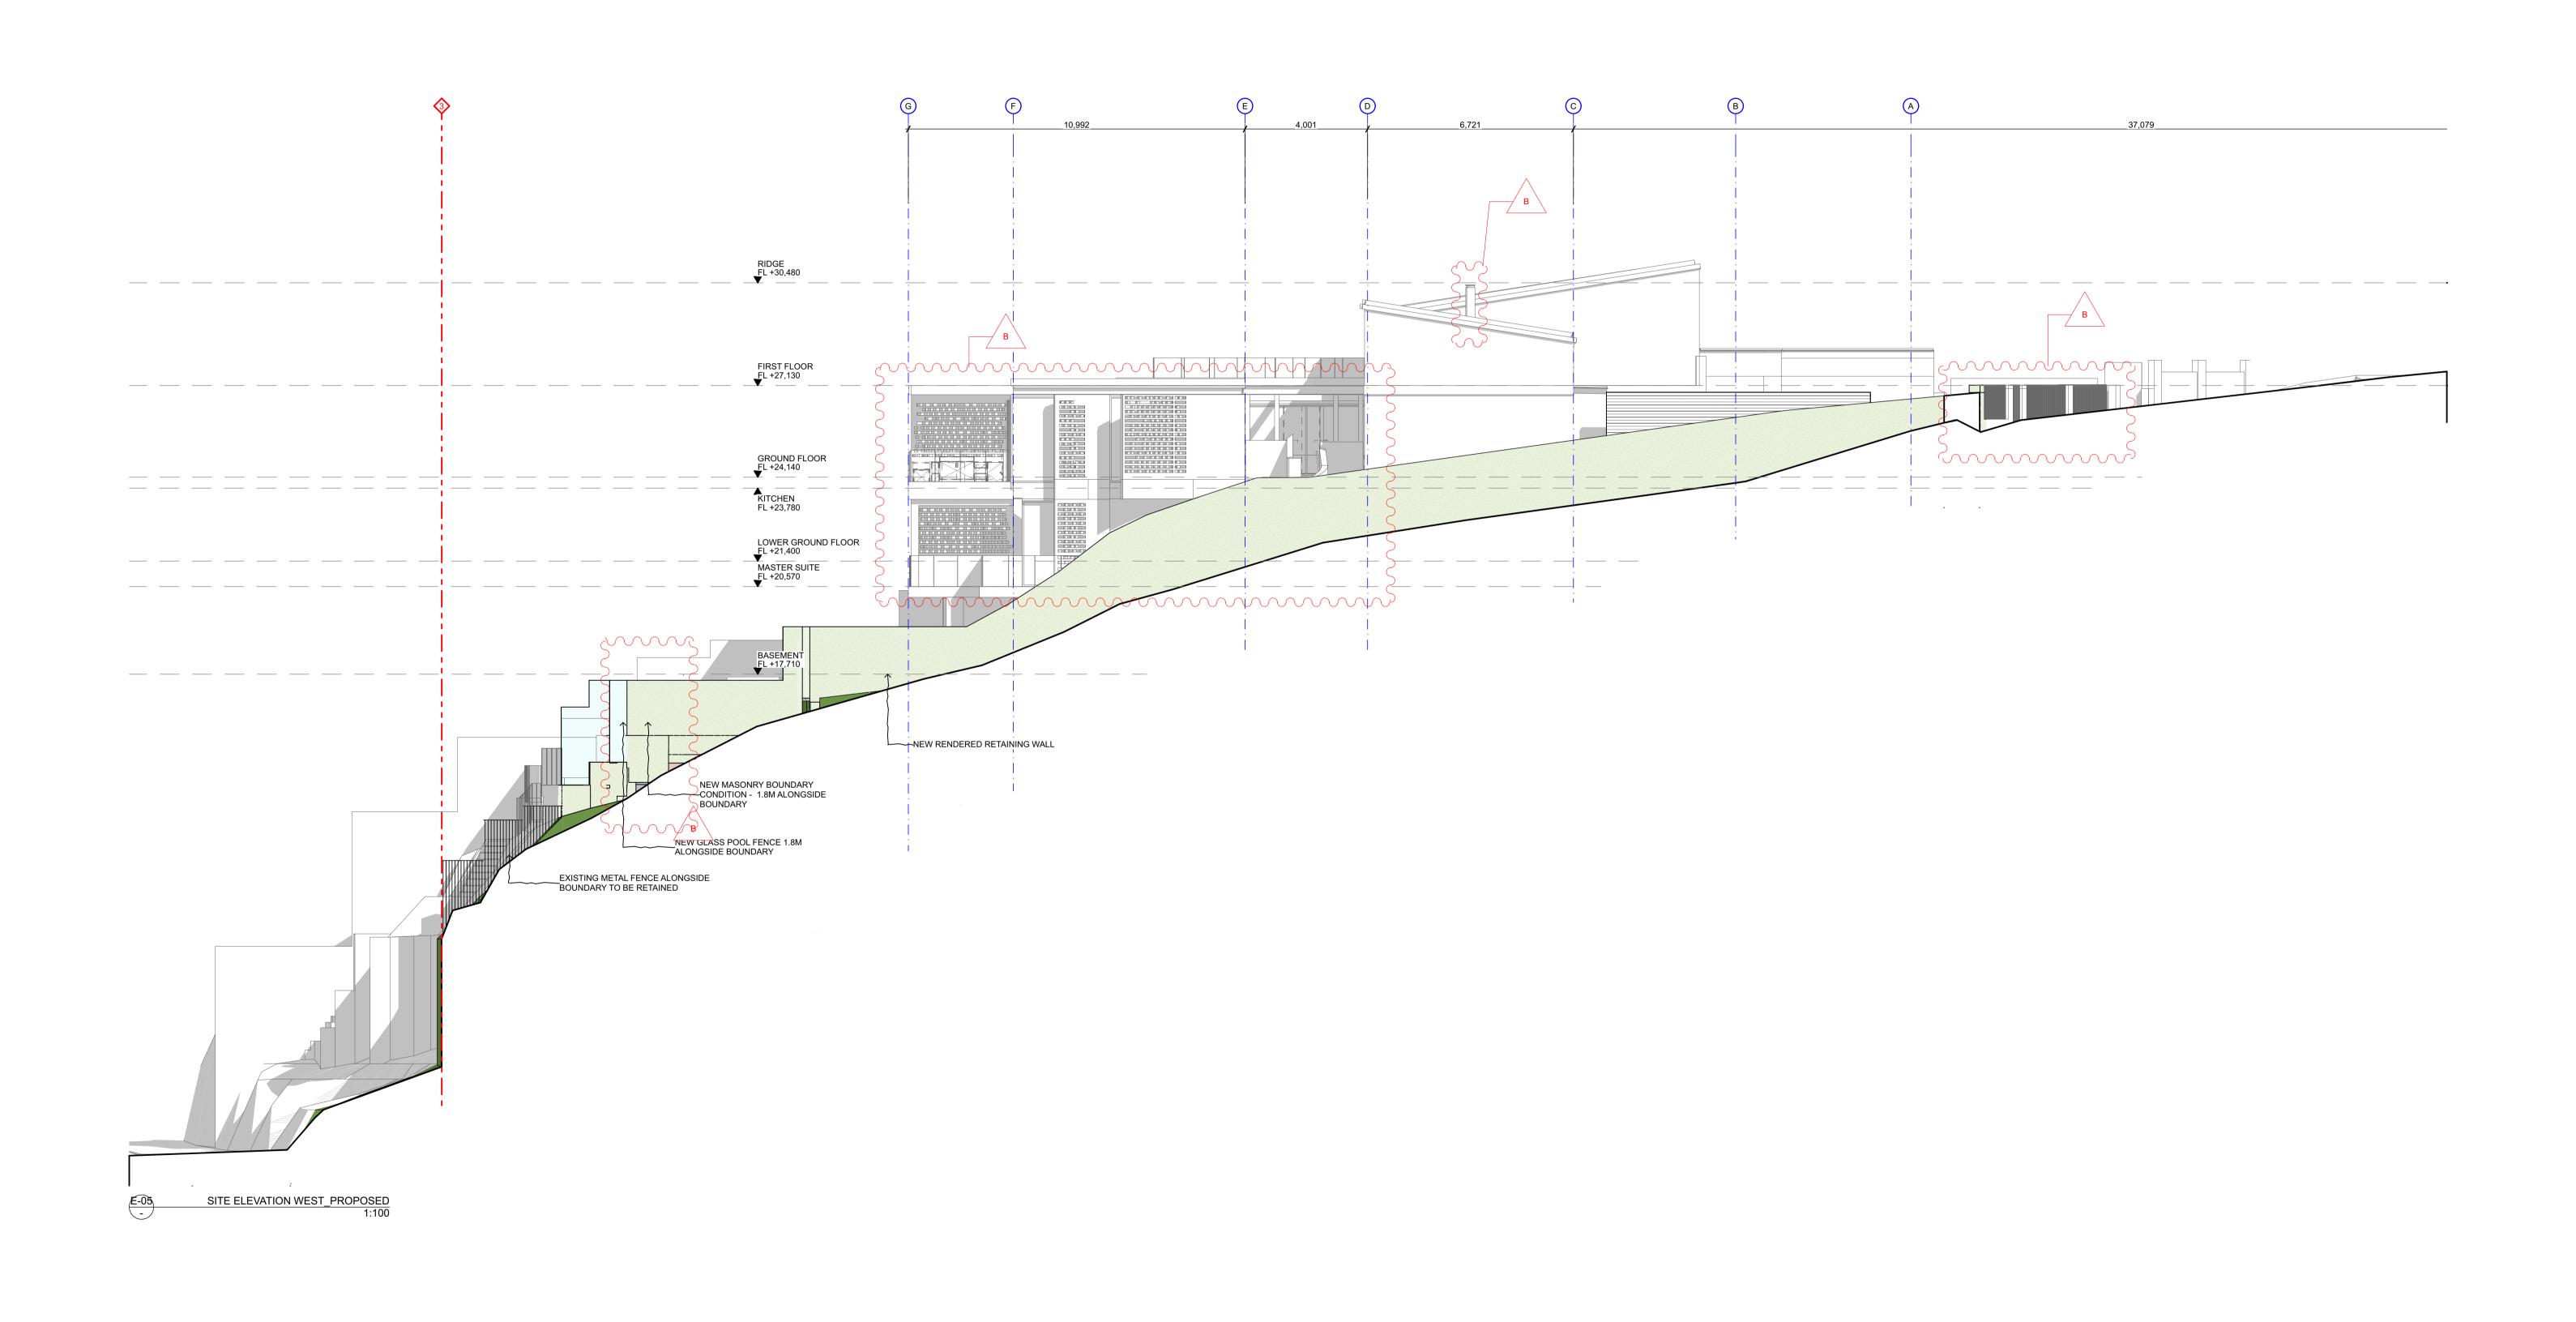

DA MATERIAL SURFACE HATCHING

LANDSCAPE - TILE

GLAZING

DA SHADOW STUDY

EXISTING SHADOW

ALEXANDER HOUSE
63 BRISBANE STREET, BONDI JUNCTION
NSW 2022

CLIENT:
TRACEY & JAMES
SMAIL

PROJECT:

MANLY,

NSW 2095

BOWER HOUSE 38 BOWER ST

T +61 (02) 8394 9838 www.alexanderand.co ABN 11 162 041 929

NOMINATED ARCHITECT: **JEREMY BULL** NSW REGISTRATION NO. **7881** 

CLASS 2 DESIGN PRACTITIONER: JEREMY BULL | NUMBER DEP0001029

ALEXANDER &CO.

DRAWING TITLE

E05\_PROPOSED

SCALE 1:100 @ A1

0567-3100-[B]

PROJECT NO. - DWG NO.\_REV.

SITE ELEVATIONS - ELEVATION

CHECKED **KK** 

ATHR

GENERAL NOTES:

1. ALL WORKS TO BE IN ACCORDANCE WITH THE NATIONAL CONSTRUCTION CODE, AUSTRALIAN STANDARDS AND LOCAL AUTHORITY REQUIREMENTS, INCLUDING COUNCIL CONDITIONS OF CONSENT

2. DO NOT SCALE OFF THIS DRAWING. USE ONLY DIMENSIONS PROVIDED

3. A&CO DRAWINGS ARE TO BE READ IN CONJUNCTION WITH ALL CONTRACT DOCUMENTS FROM ALL CONSULTANTS

4. ALL DIMENSIONS TO BE CHECKED ON SITE PRIOR TO THE COMMENCEMENT OF

**DISCLAIMER:**THE COPYRIGHT OF THIS DRAWING TOGETHER WITH ANY DOCUMENTS PREPARED BY

A&CO PTY. LTD REMAINS THE PROPERTY OF A&CO PTY. LTD. A&CO PTY. LTD GRANTS
LICENCE FOR THE USE OF THIS DOCUMENT FOR THE PURPOSE FOR WHICH IT IS
INTENDED. THE LICENCE IS NOT TRANSFERABLE WITHOUT THE PERMISSION OF A&CO
PTY. LTD

LEGEND - DA

TO BE DEMOLISHED

EXISTING BUILDING FABRIC TO BE DEMOLISHED

EXISTING OPENINGS TO
BE REMOVED;
INCLUDING FRAMES
AND ARCHITRAVES.
MAKE GOOD OPENING
AND REVEALS
INCLUDING FINISHES

DA COMPLIANCE LEGEND

EXISTING OPEN SPACE AREA

PROPOSED OPEN SPACE AREA

EXISTING LEP AREA

MAX. HEIGHT PLANE 8.5M 3D

MAX. HEIGHT PLANE 8.5M 2D

MAX. SHEAR WALL PLANE 7M 3D

MAX. SHEAR WALL PLANE 8.5M 2D

SETBACK CONTROLS

DA MATERIAL CUT HATCHING

CONCRETE

EXISTING BUILDING

REV DATE


A 25/7/2023 B 18/7/2024


DESCRIPTION


BIMcloud: ALEX-BIM-SERVER - BIMcloud/0567\_38 Bower St, Manly/0567\_38 Bower St\_S4.55


FOR DA SUBMISSION FOR S4.55 SUBMISSION




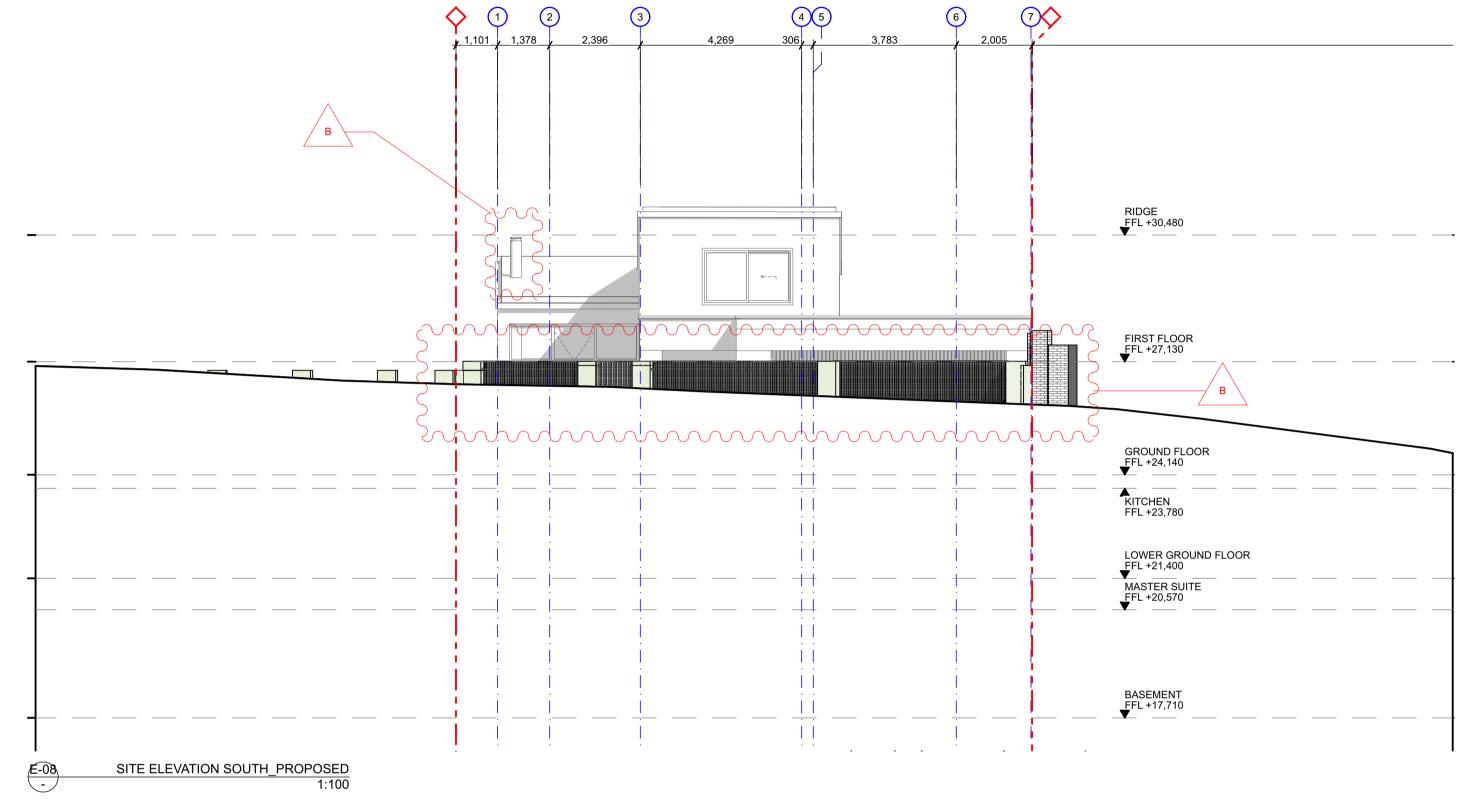


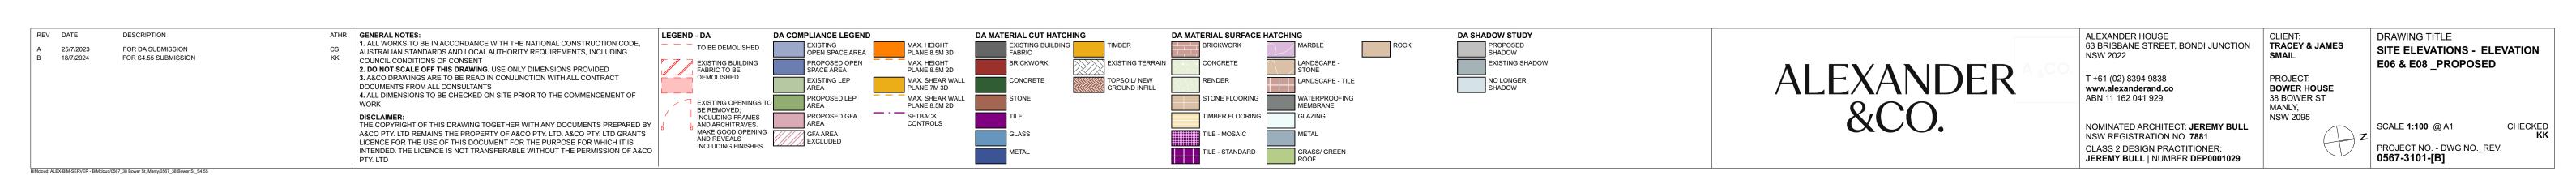

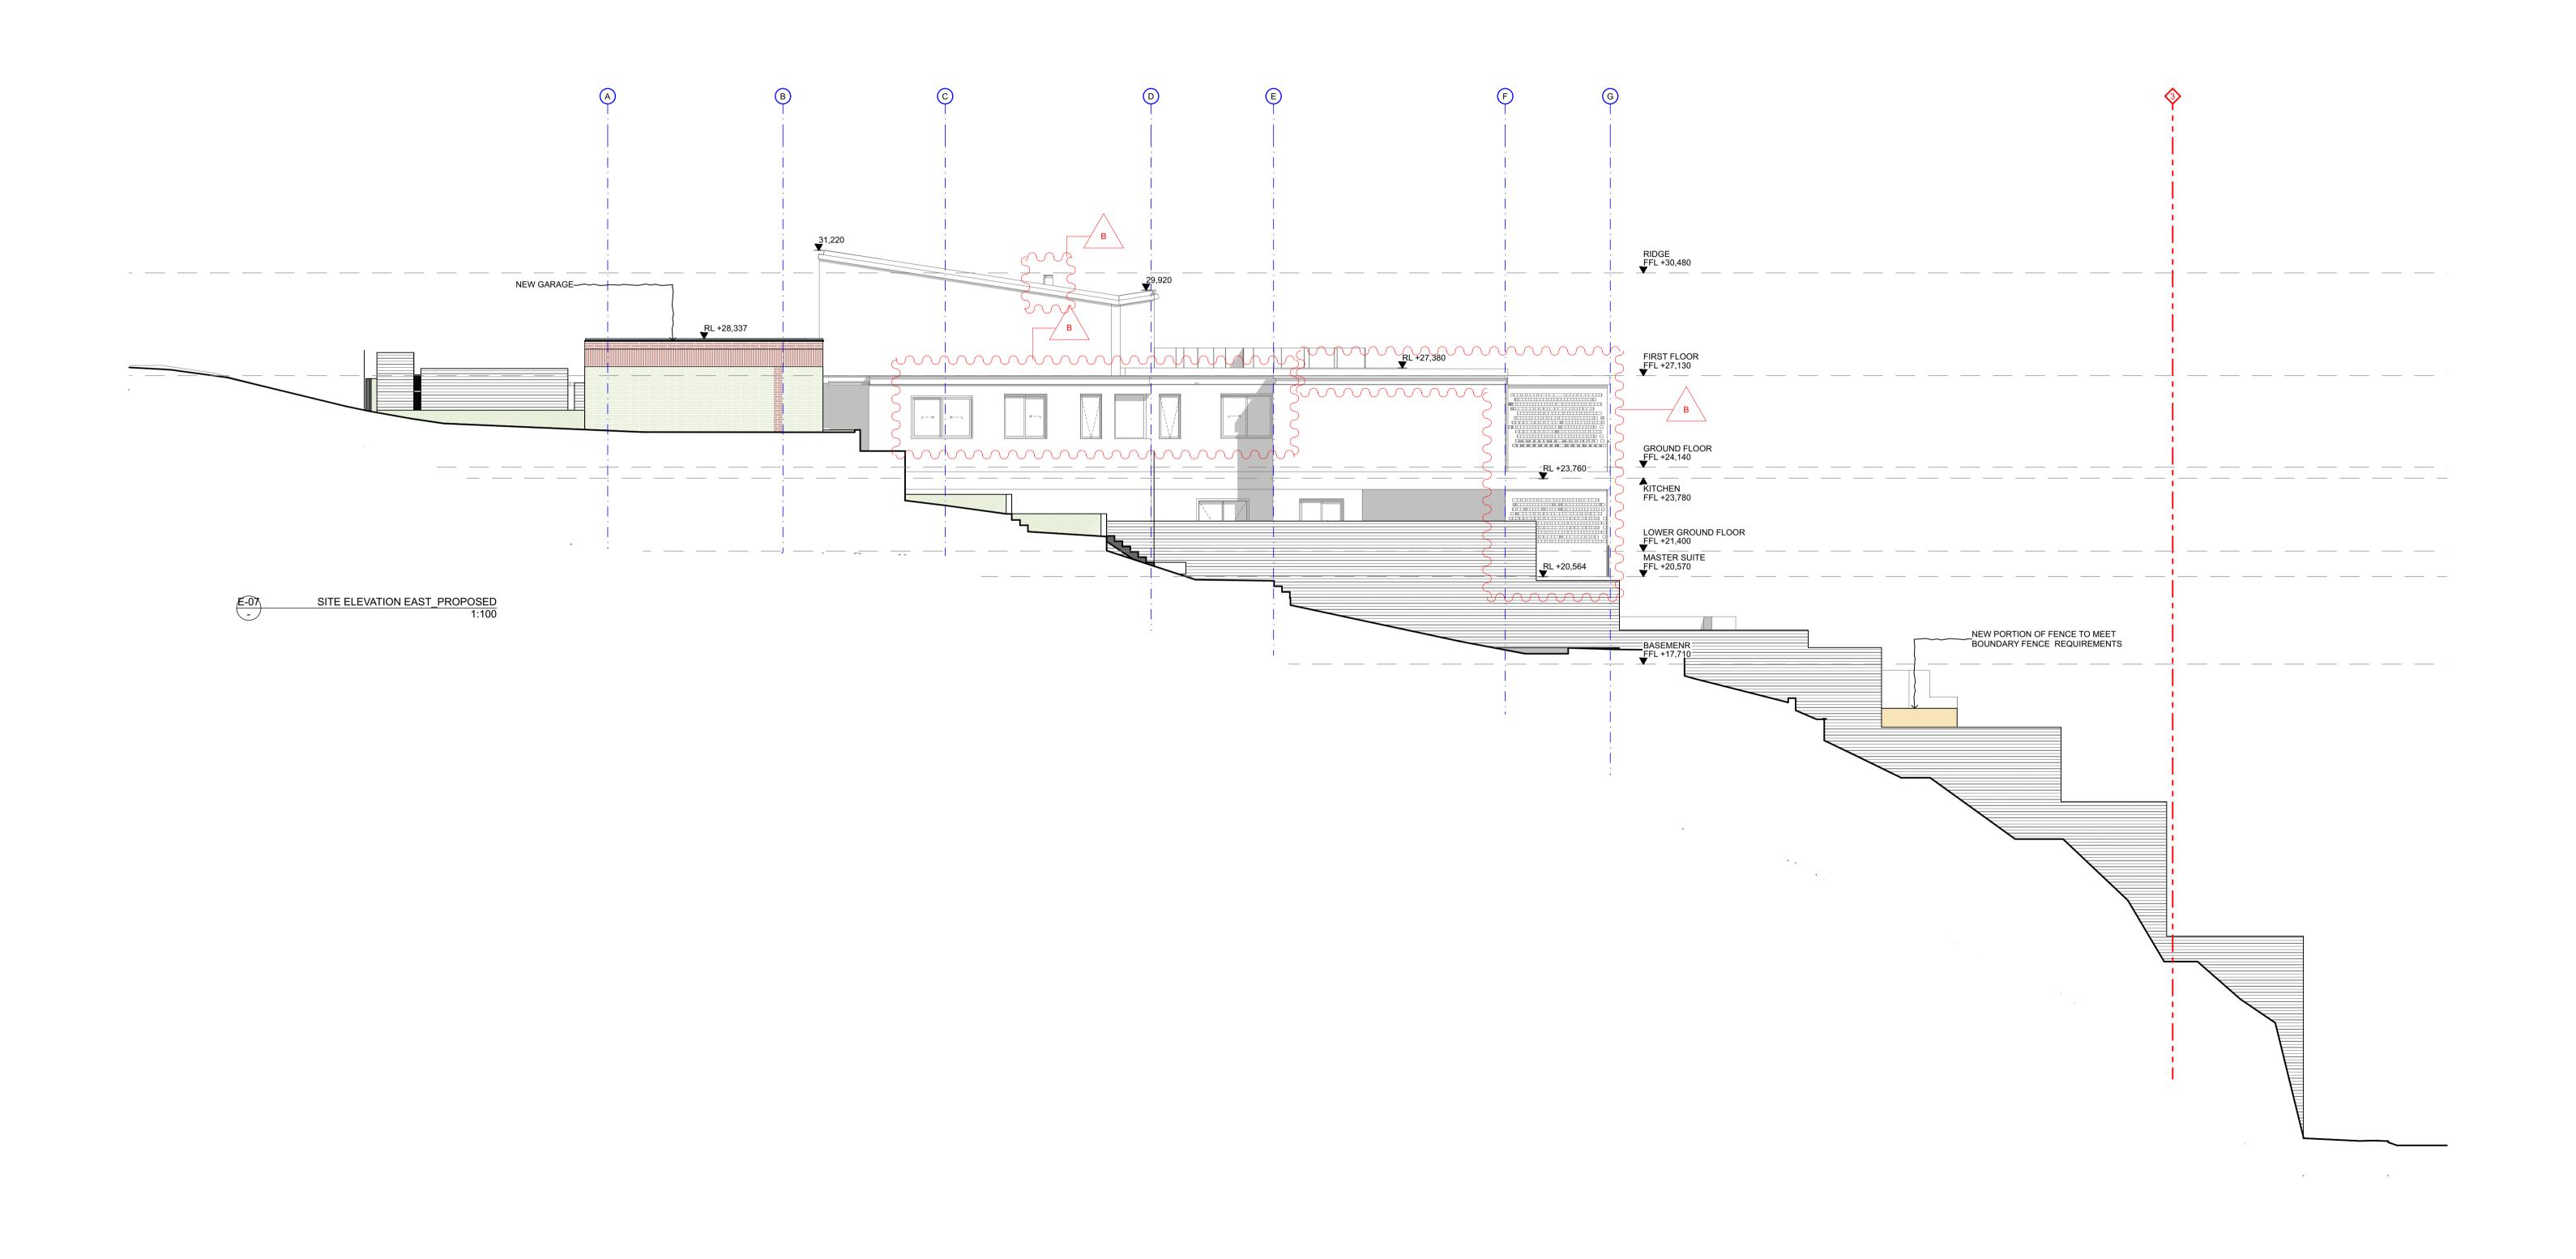


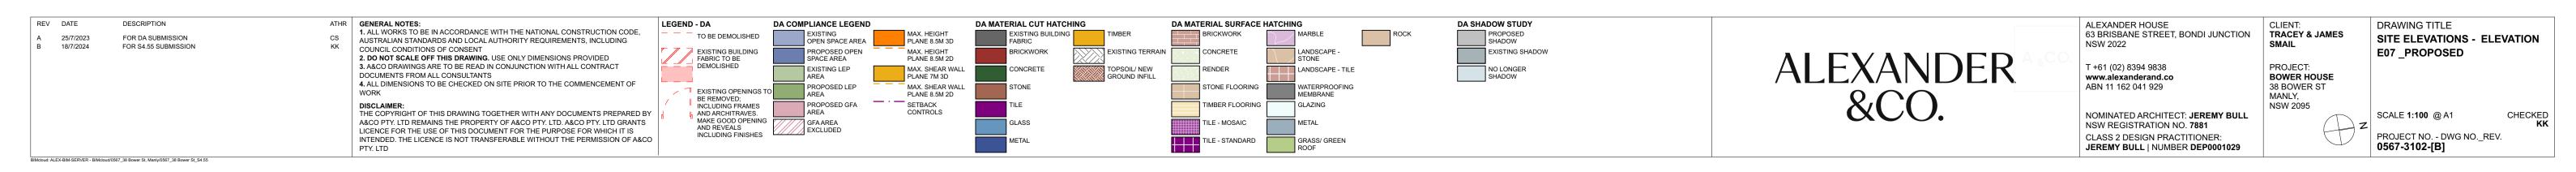


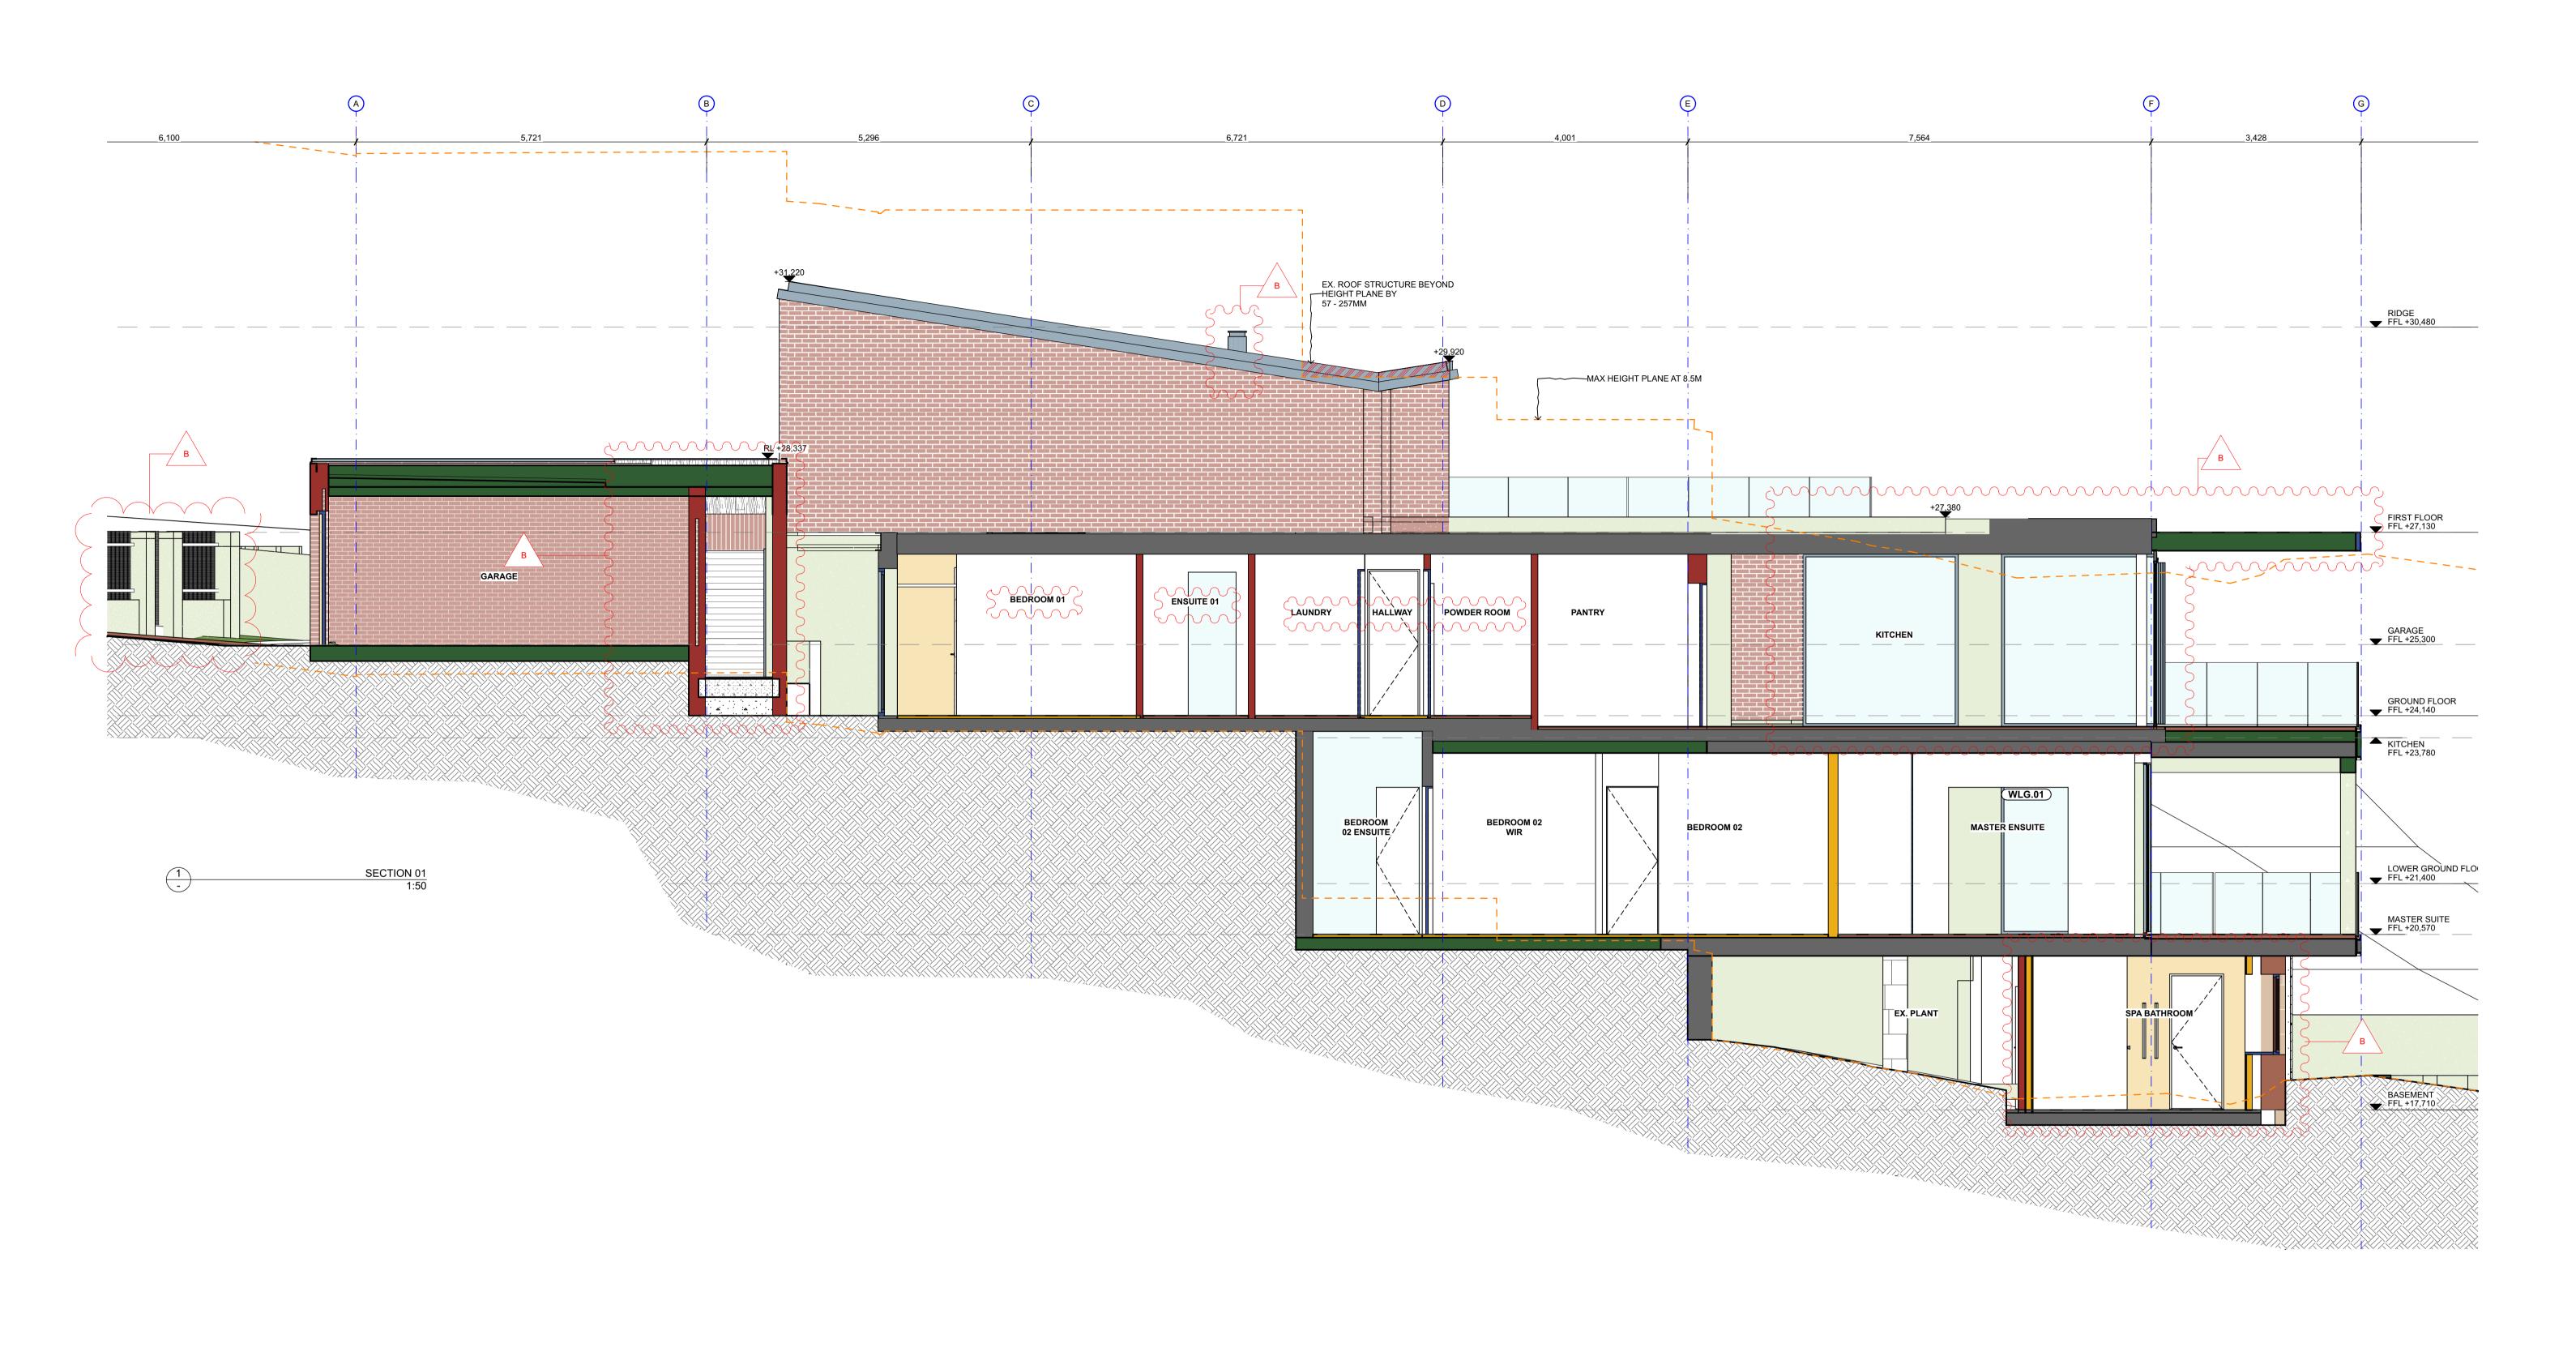


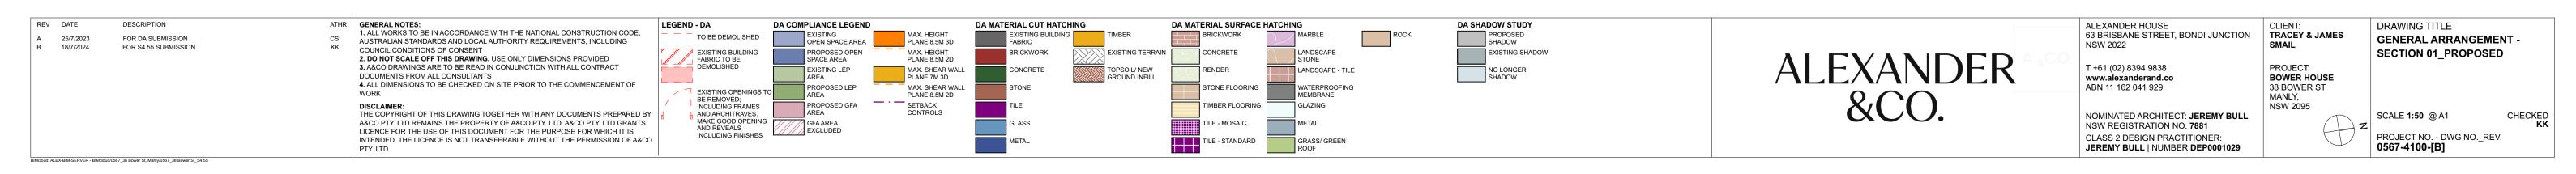





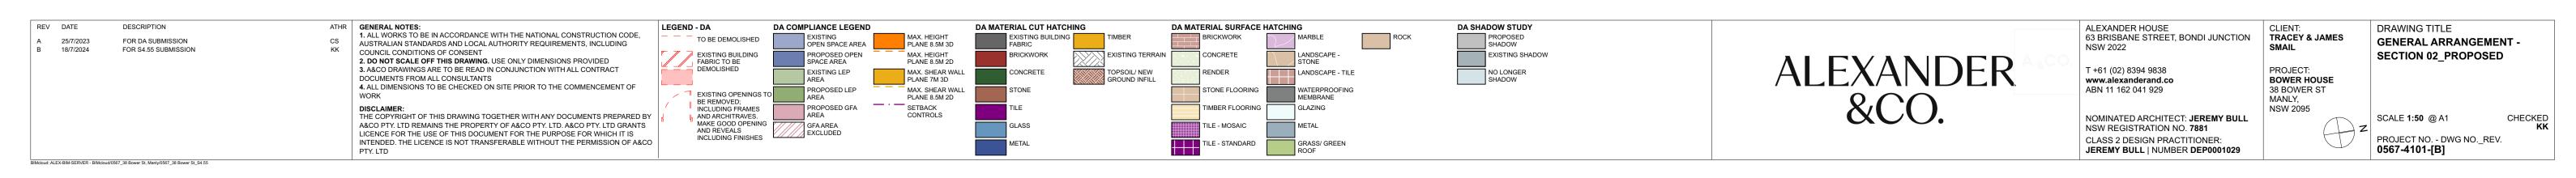


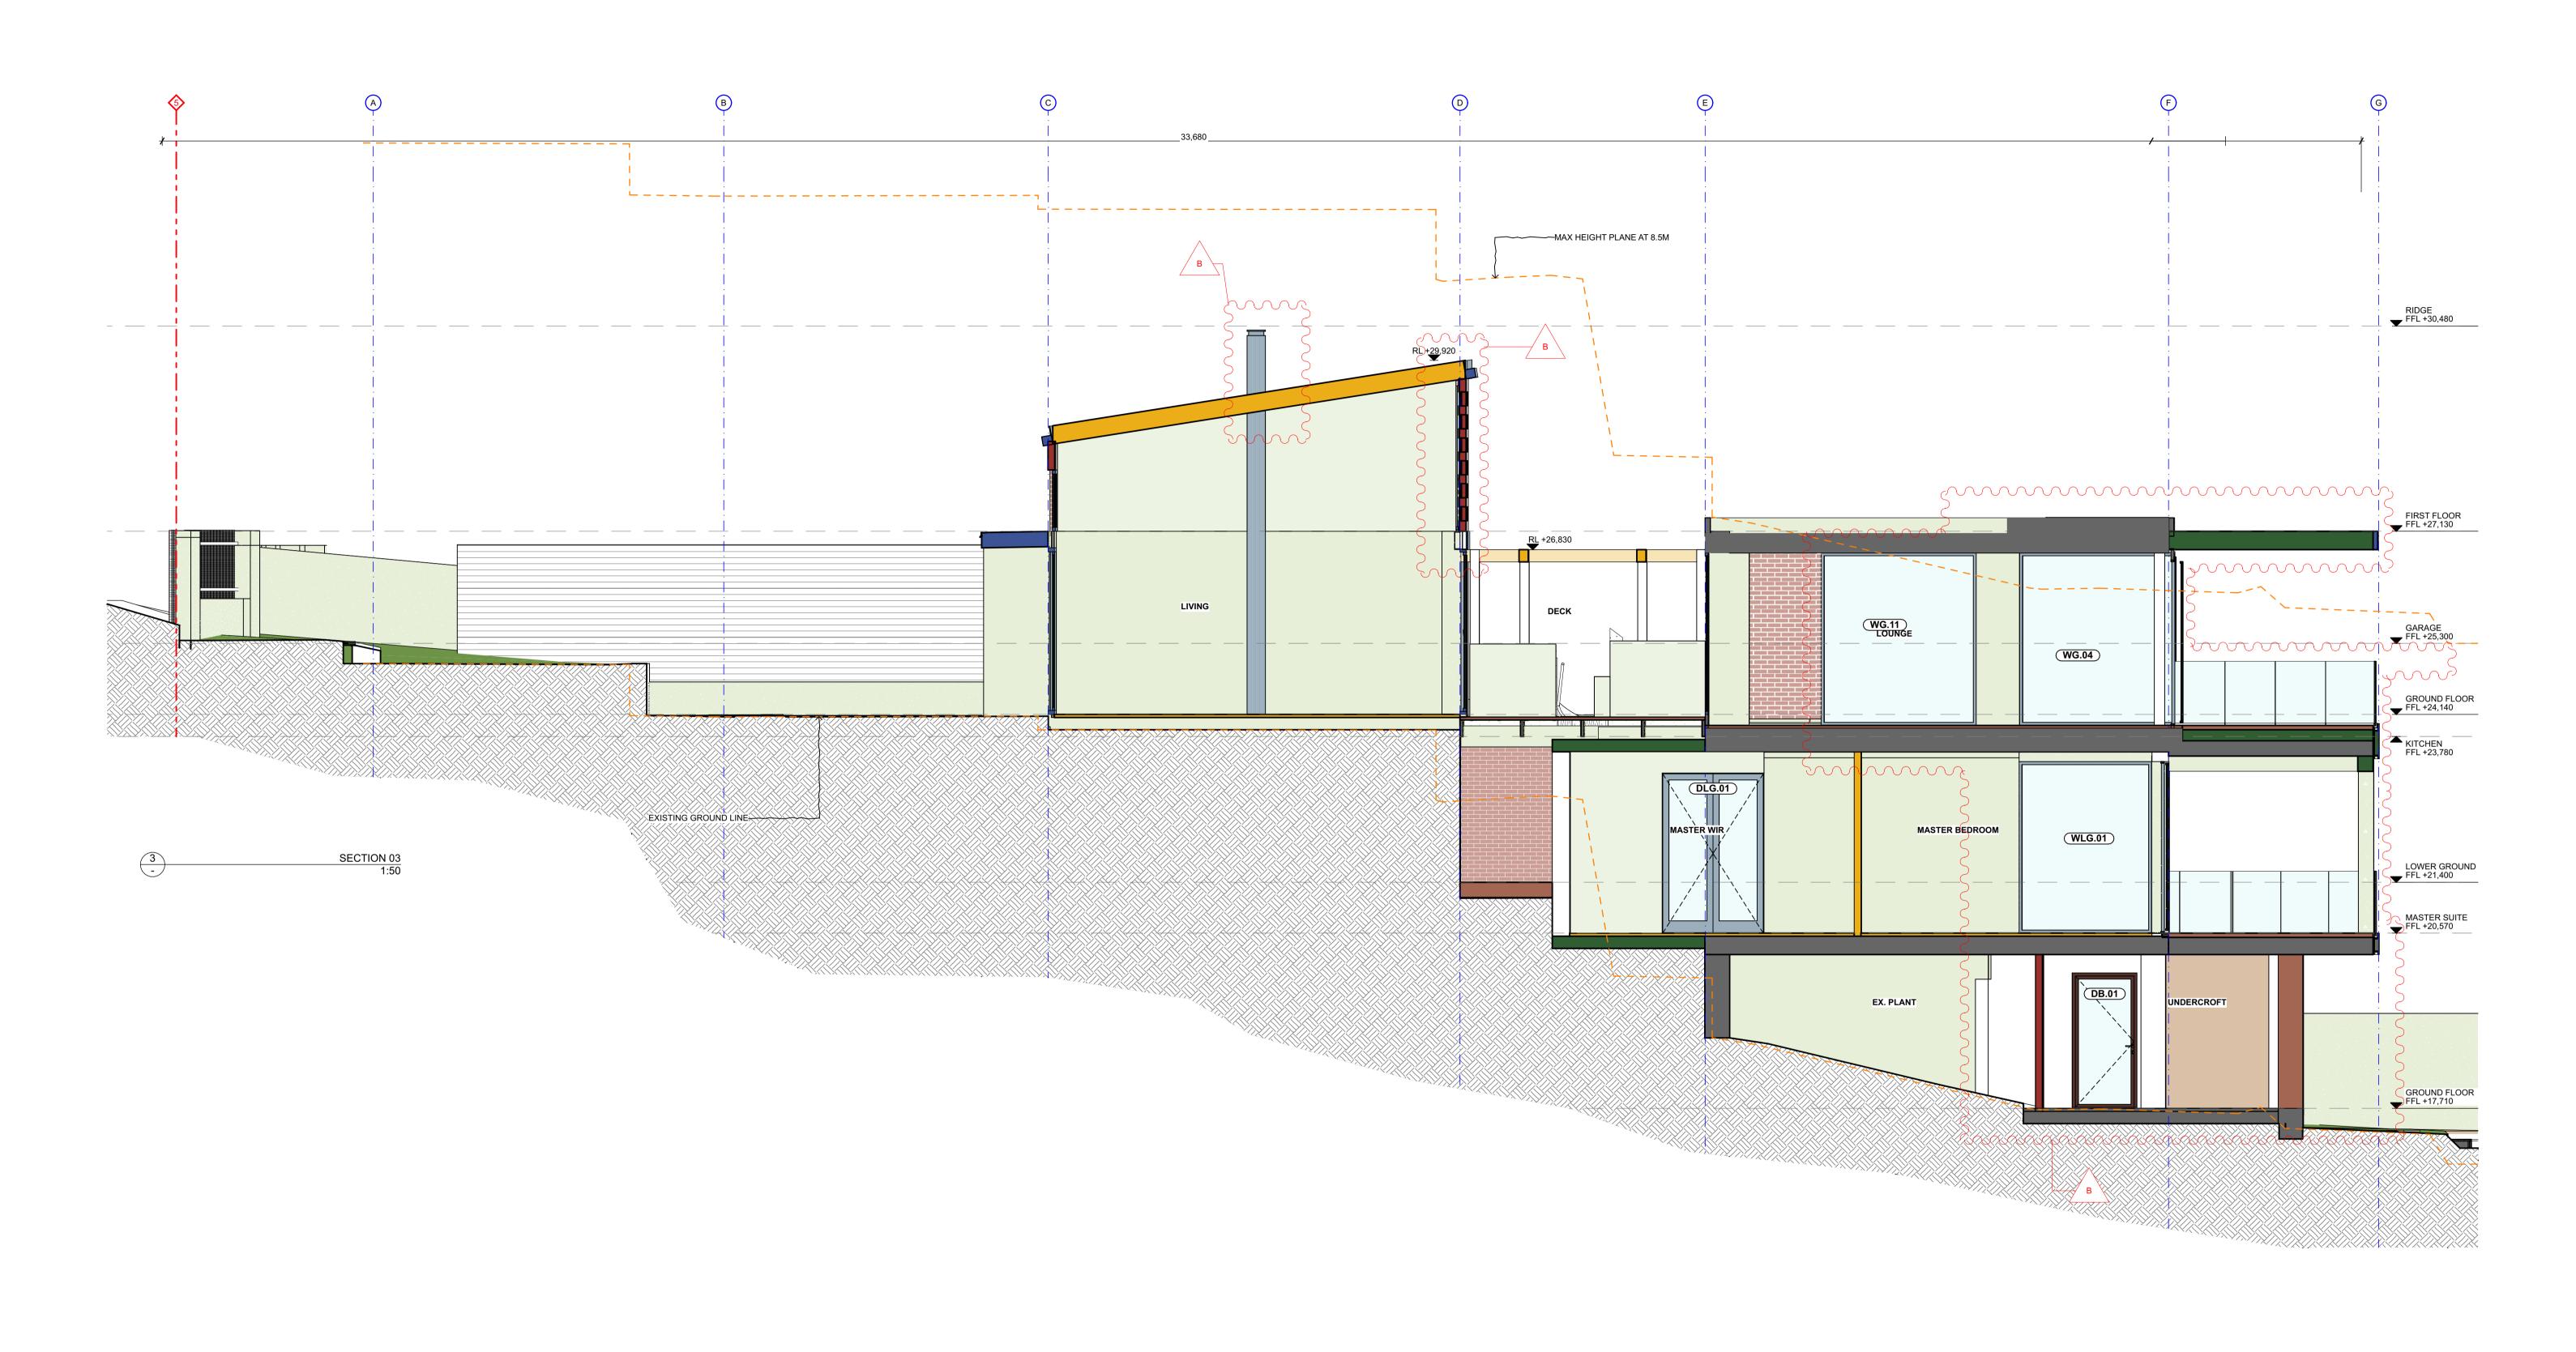


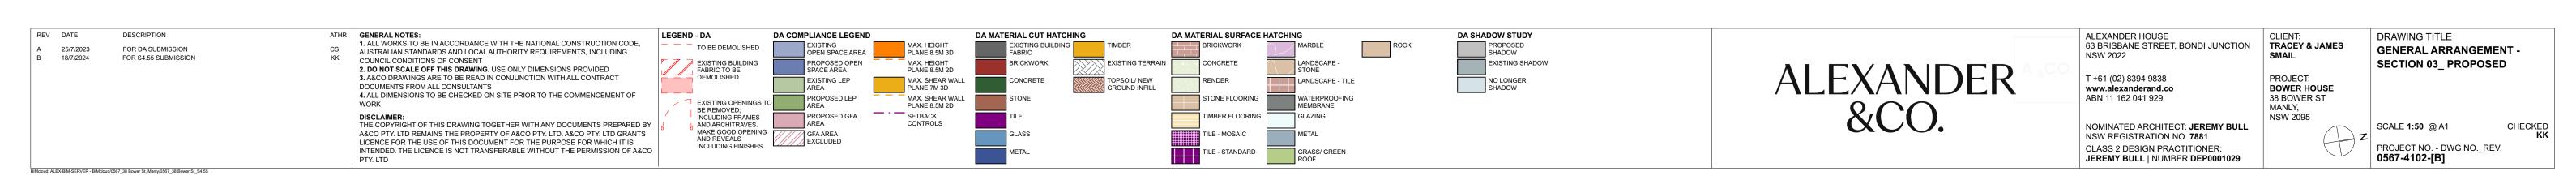

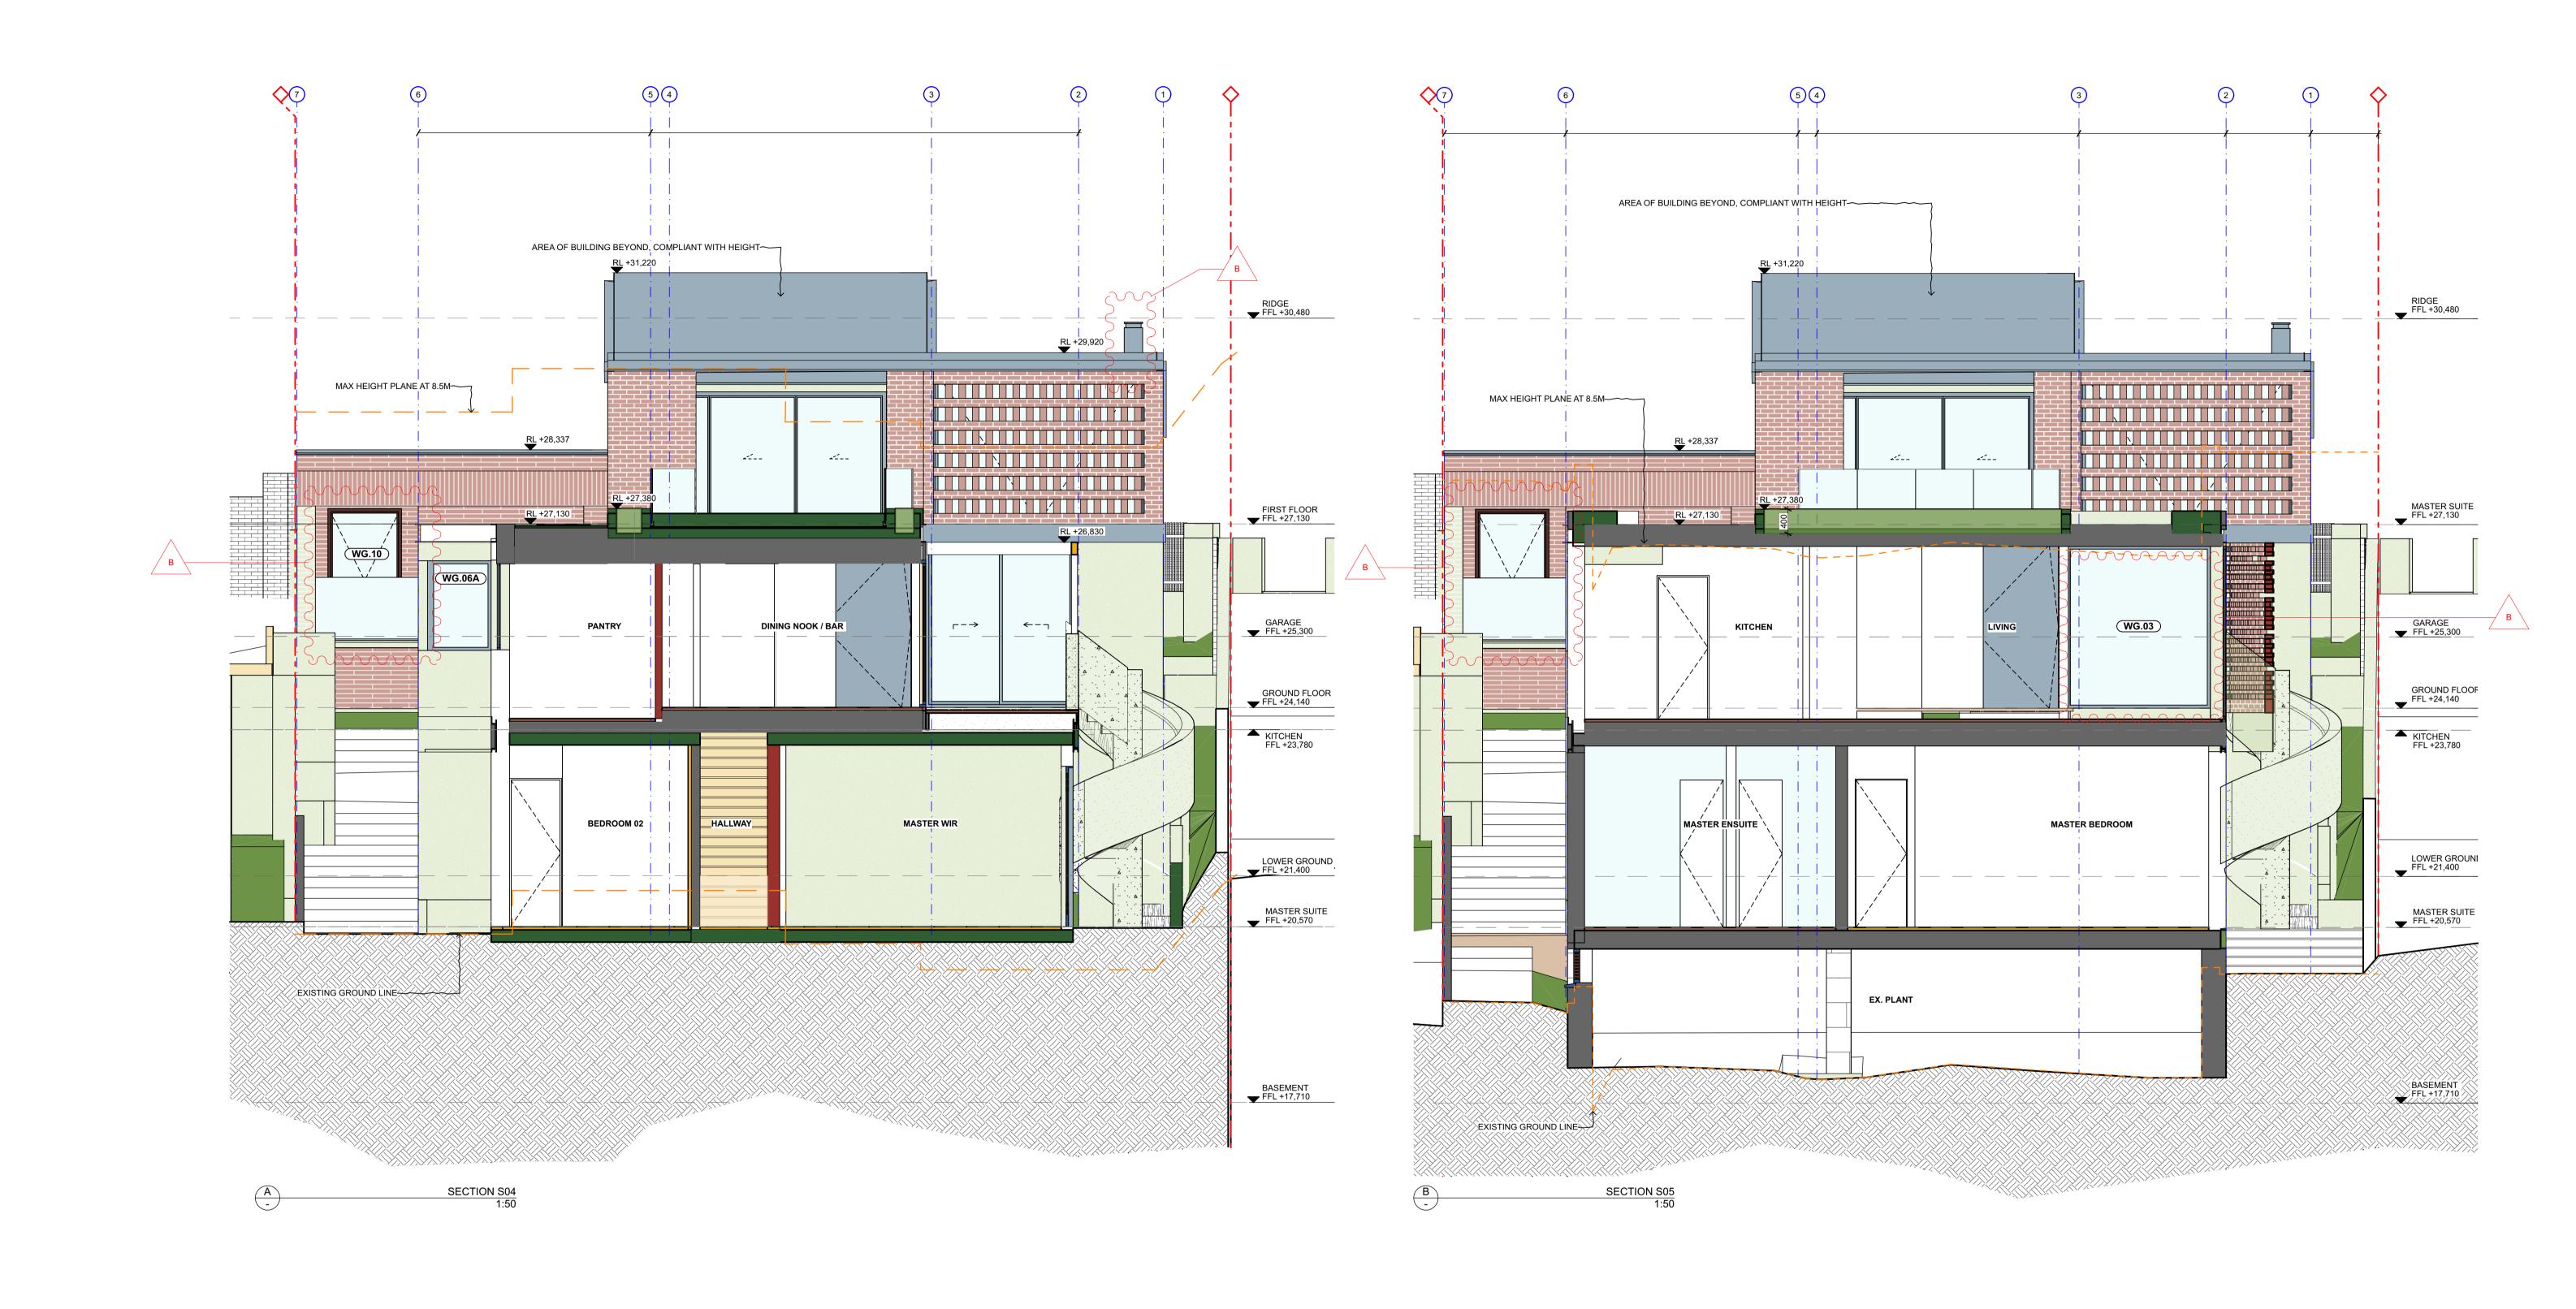


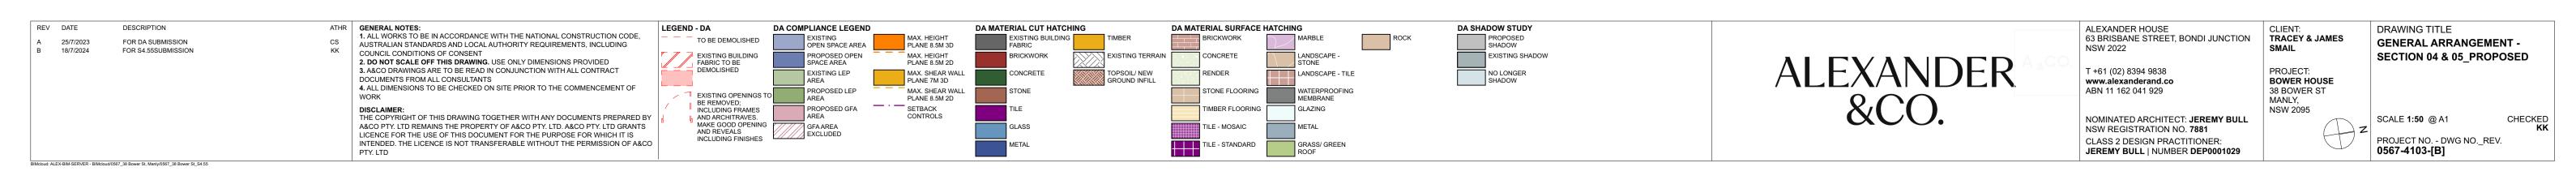


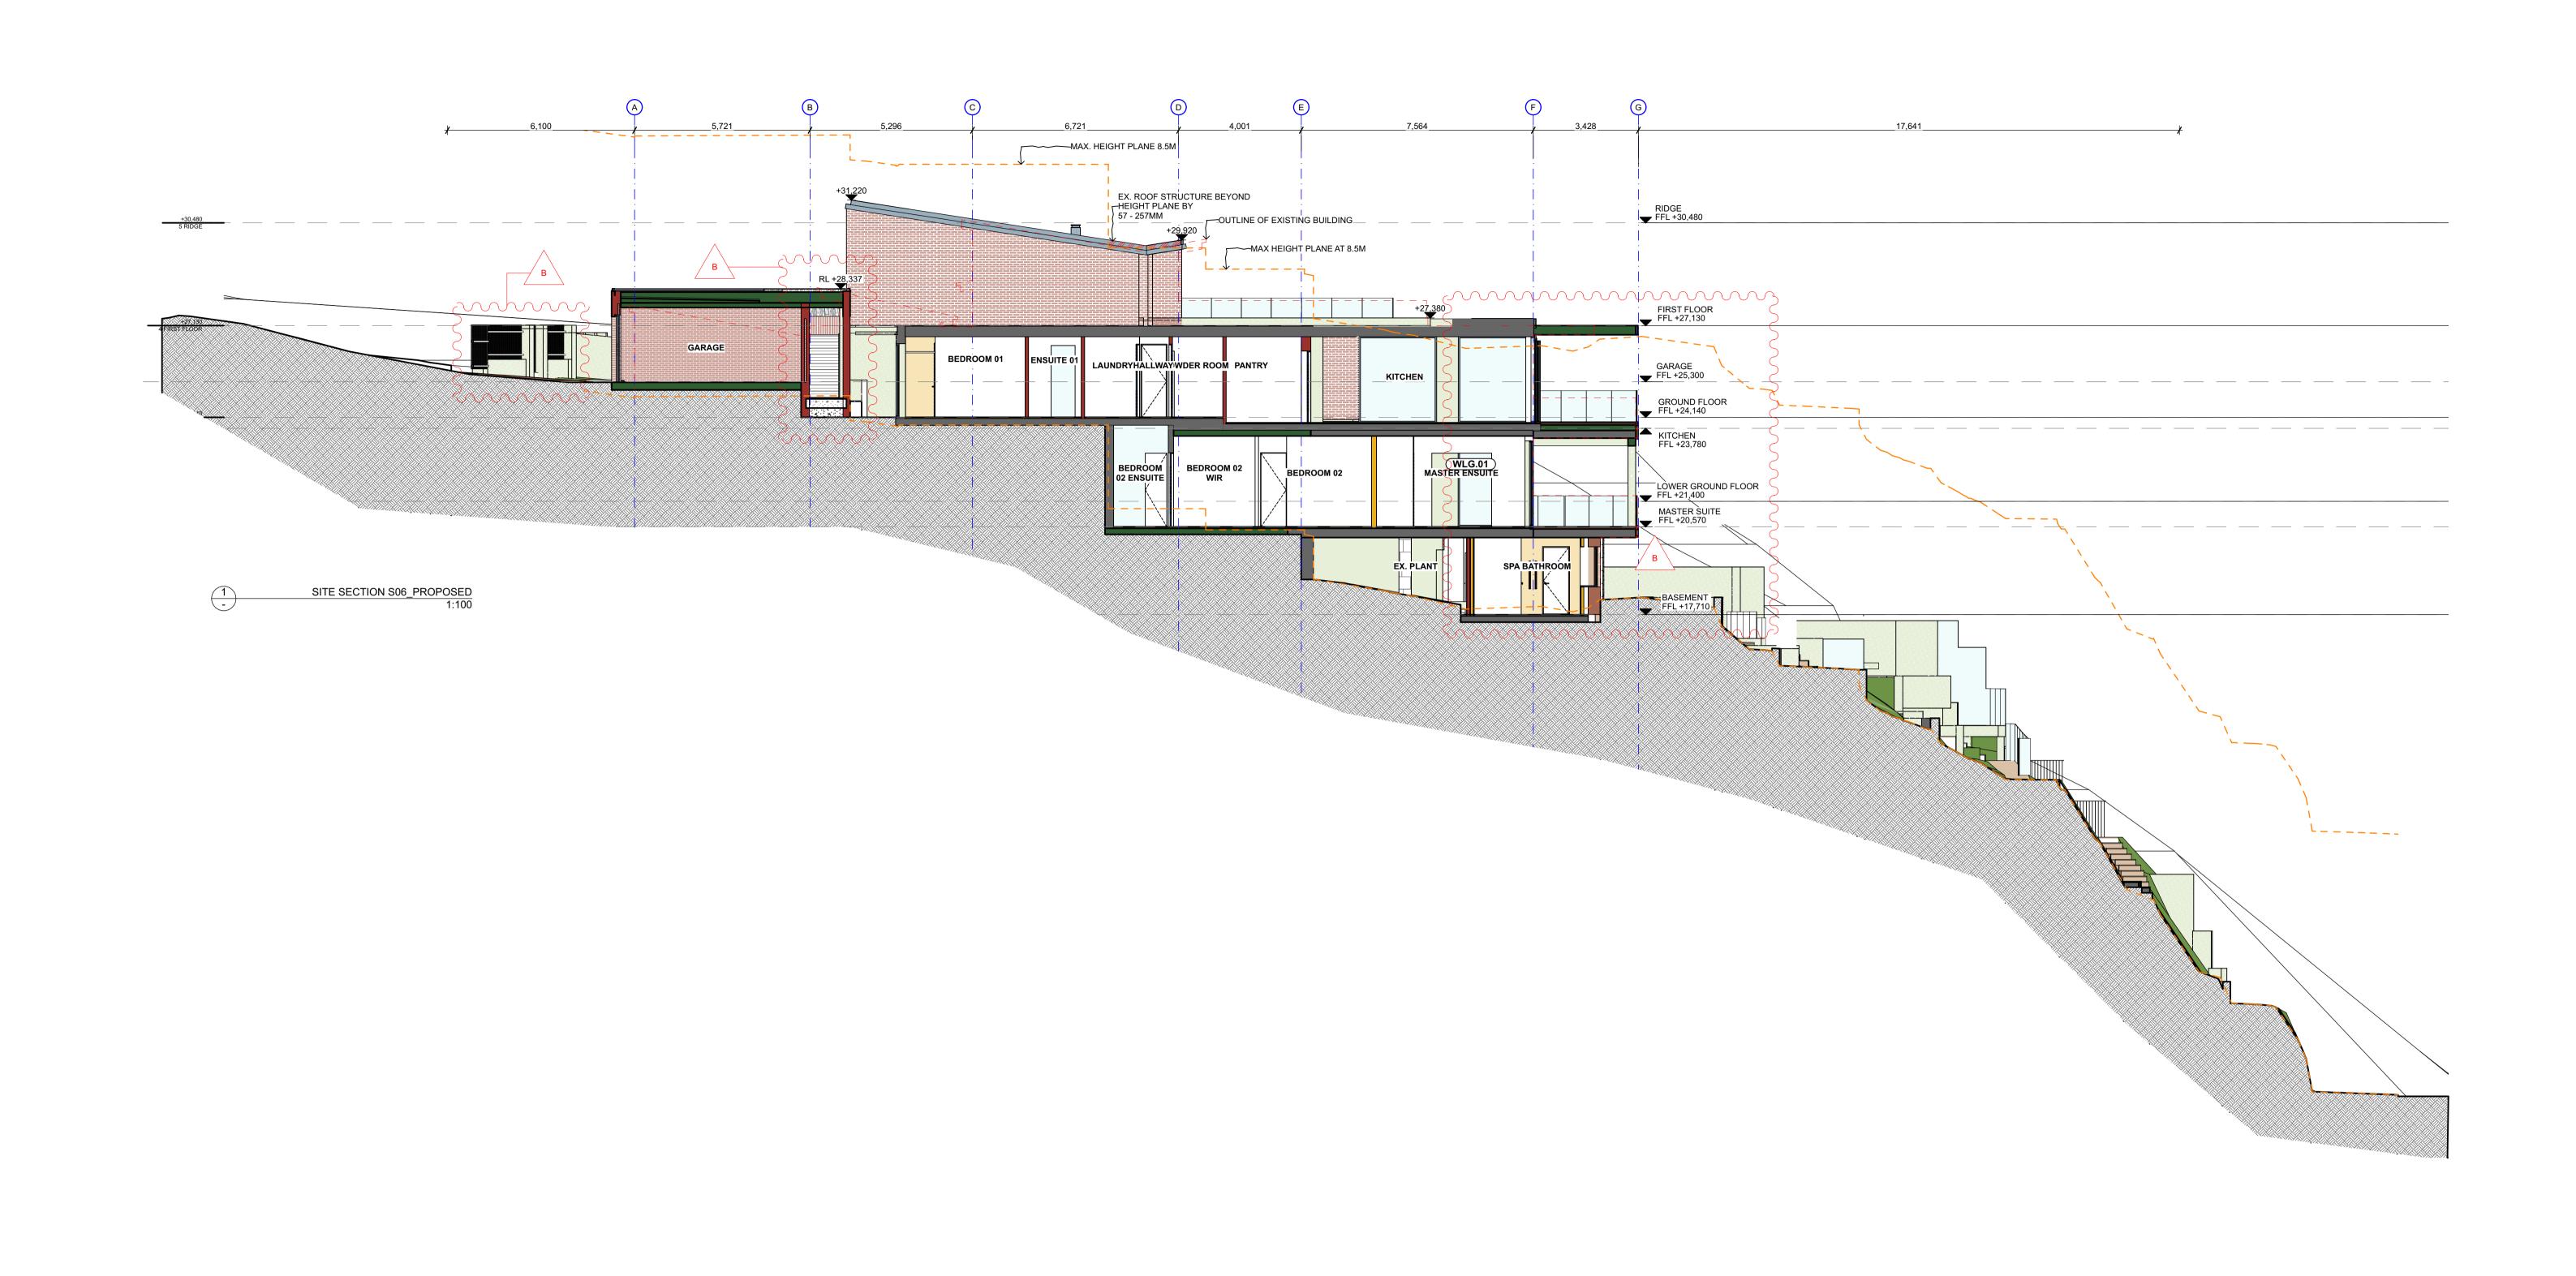

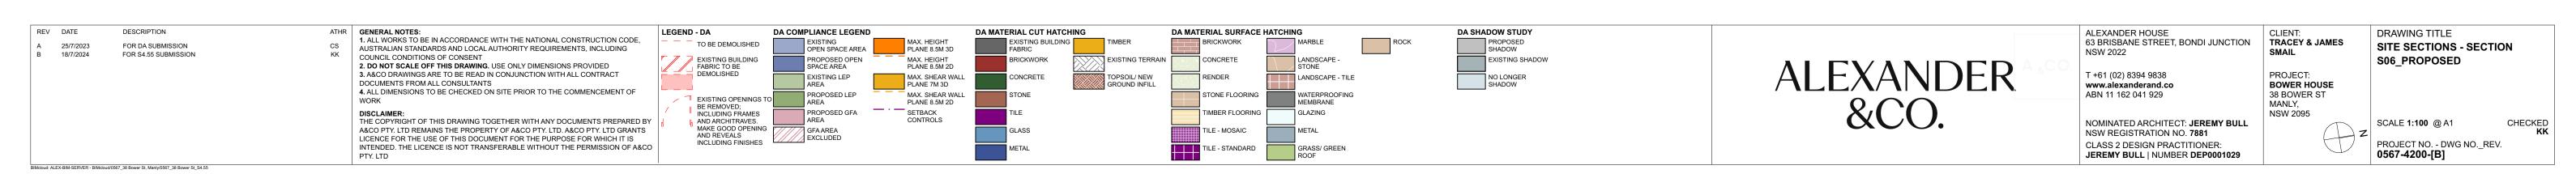



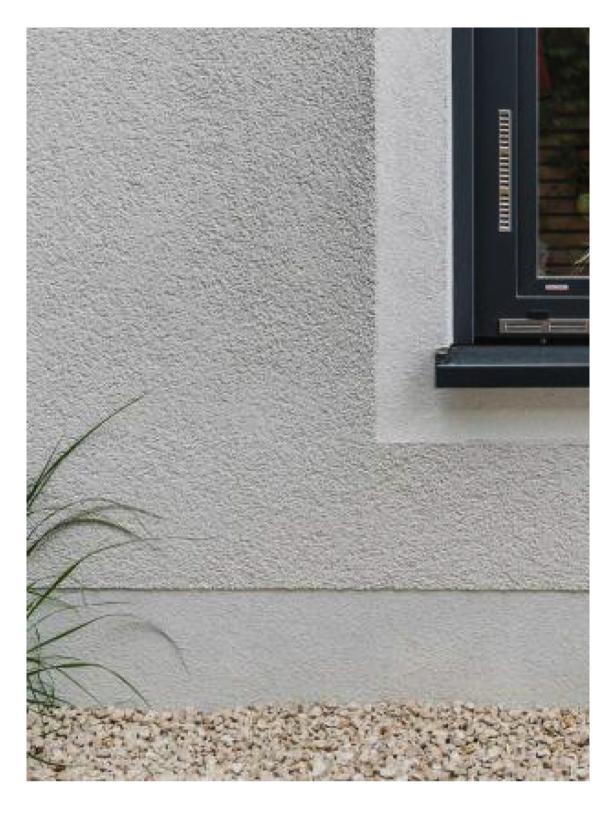

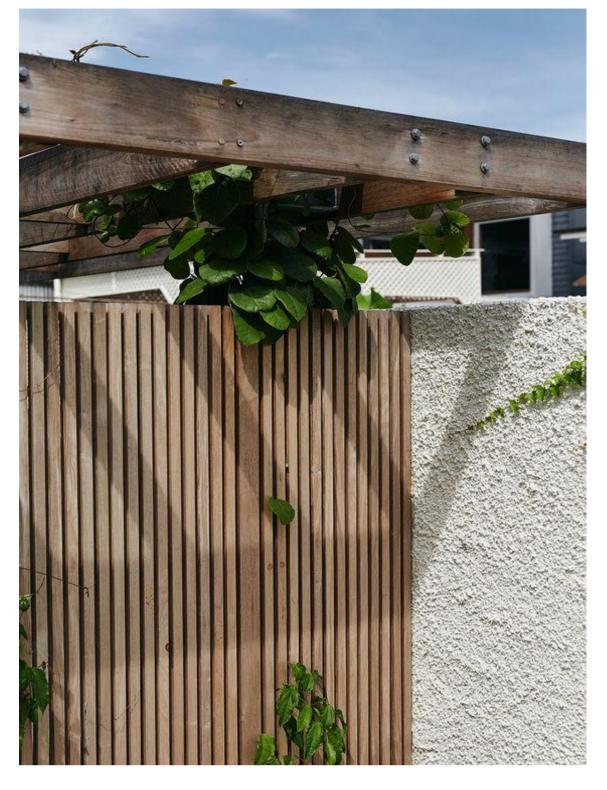




BRONZE FINISH STANDING SEEM ROOF


SAND CEMENT RENDER


VERTICAL TIMBER BATTENS



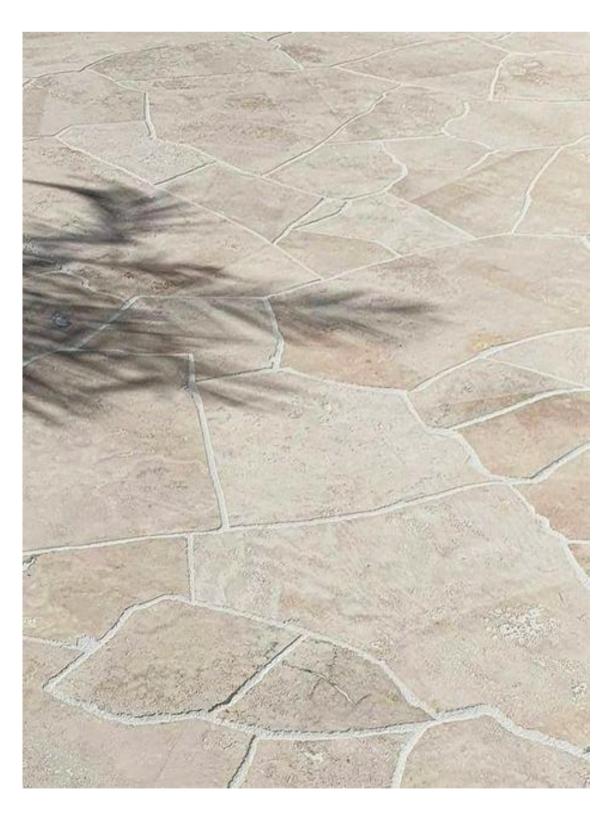



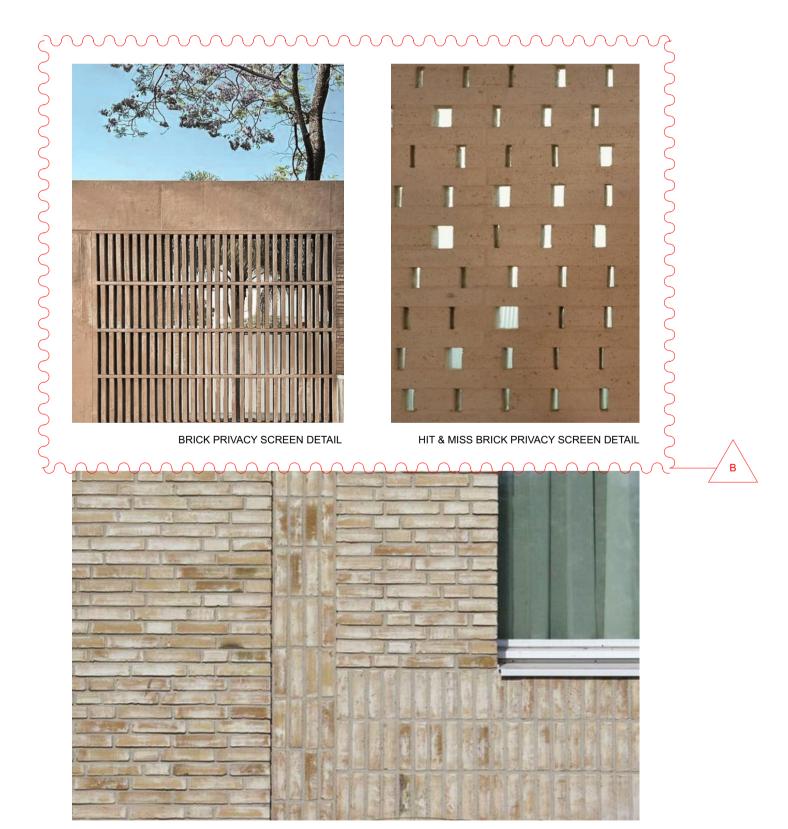

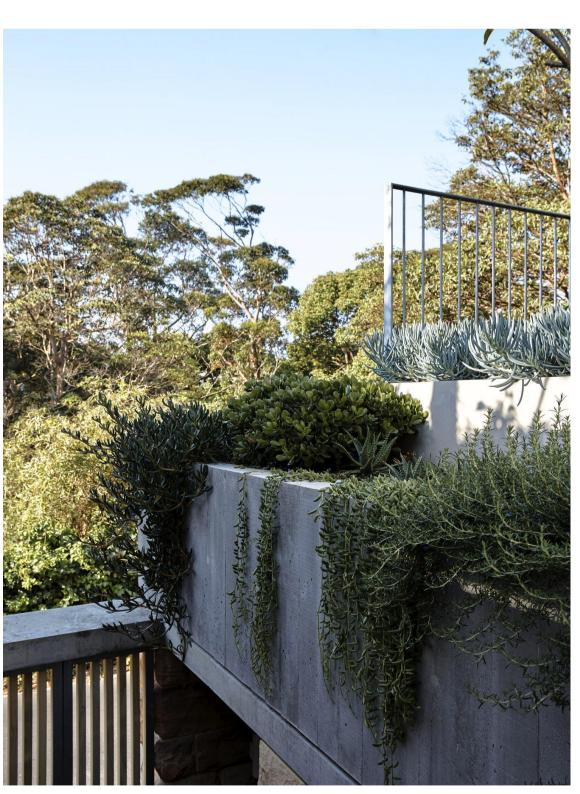

NATURAL STONE

BRONZE FINISH ALUMINIUM WINDOWS AND DOORS


BRICK DETAILS

HANGING PLANTS TO FLAT ROOF SECTIONS

DESCRIPTION FOR DA SUBMISSION B 18/7/2024 FOR S4.55 SUBMISSION ATHR
CS
KK

1. ALL WORKS TO BE IN ACCORDANCE WITH THE NATIONAL CONSTRUCTION CODE, AUSTRALIAN STANDARDS AND LOCAL AUTHORITY REQUIREMENTS, INCLUDING COUNCIL CONDITIONS OF CONSENT
2. DO NOT SCALE OFF THIS DRAWING. USE ONLY DIMENSIONS PROVIDED
3. A&CO DRAWINGS ARE TO BE READ IN CONJUNCTION WITH ALL CONTRACT DOCUMENTS FROM ALL CONSULTANTS
4. ALL DIMENSIONS TO BE CHECKED ON SITE PRIOR TO THE COMMENCEMENT OF WORK

DISCLAIMER:
THE COPYRIGHT OF THIS DRAWING TOGETHER WITH ANY DOCUMENTS PREPARED BY A&CO PTY. LTD REMAINS THE PROPERTY OF A&CO PTY. LTD. A&CO PTY. LTD GRANTS LICENCE FOR THE USE OF THIS DOCUMENT FOR THE PURPOSE FOR WHICH IT IS INTENDED. THE LICENCE IS NOT TRANSFERABLE WITHOUT THE PERMISSION OF A&CO PTY. LTD

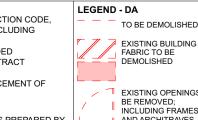

DA COMPLIANCE LEGEND OPEN SPACE AREA EXISTING LEP EXISTING OPENINGS TO BE REMOVED;
INCLUDING FRAMES AND ARCHITRAVES.
MAKE GOOD OPENING AND REVEALS INCLUDING FINISHES

MAX. HEIGHT PLANE 8.5M 3D MAX. HEIGHT PLANE 8.5M 2D MAX. SHEAR WALL PLANE 7M 3D MAX. SHEAR WALL PLANE 8.5M 2D SETBACK CONTROLS

DA MATERIAL CUT HATCHING

DA MATERIAL SURFACE HATCHING

DA SHADOW STUDY

ALEXANDER &CO.

ALEXANDER HOUSE 63 BRISBANE STREET, BONDI JUNCTION NSW 2022

CLASS 2 DESIGN PRACTITIONER: JEREMY BULL | NUMBER DEP0001029

CLIENT: TRACEY & JAMES T +61 (02) 8394 9838 www.alexanderand.co ABN 11 162 041 929

PROJECT: BOWER HOUSE 38 BOWER ST MANLY, NSW 2095 NOMINATED ARCHITECT: **JEREMY BULL** NSW REGISTRATION NO. **7881** 

SCALE @ A1 PROJECT NO. - DWG NO.\_REV.

0567-8000-[B]

MATERIAL PALETTE

DRAWING TITLE

