

191 WHALE BEACH ROAD, WHALE BEACH

LANDSCAPE DOCUMENTATION

SECTION 4.55 SUBMISSION

DRAWING REGISTER

Dwg No.	Drawing Title	Scale	Size
General			
L-DA-00	Cover Page & Drawing Schedule	N/A	A1
L-DA-01	Landscape Schedules & Notes	N/A	A1
L-DA-02	Landscape Statement & Diagrams	N/A	A1
Plans			
L-DA-03	Site Analysis Plan	1:100	A1
L-DA-04	Tree Removal Plan	1:100	A1
L-DA-05	Landscape Plan	1:100	A1
Sections			
L-DA-06	Landscape Sections & Elevations	1:50	A1
Palettes			
L-DA-07	Planting Palette	N/A	A1

SITE



LOCATION PLAN





Rev	Amendment	Date	Ву
Α	Draft DA	19.08.20	СВ
В	Draft DA	08.09.20	СВ
С	DA	14.09.20	СВ
D	Draft S4.55	21.09.21	BHC
Е	S4.55	22.11.21	внс

GENERAL NOTES

- * FOR DEVELOPMENT APPLICATION ONLY
- * All tree dimensions and RLs in metres. All other dimensions in mm unless stated otherwise.
- * Do not scale from drawings. Use figured dimensions only. Larger scale drawings and written dimensions take preference.
- * All work shall be carried out in accordance with current versions of Australian Standards, BCA and Local Government Regulations.
- * Structural Details are indicative only and are subject to Structural Engineer's Details and Specifications.
- * Drainage details are subject to Hydraulic / Civil Engineer's Detail and Specification.
- * Subbase details including compaction are to Civil and Structural Engineer's Specification.
- * Lighting Plans are subject to detailed design by a qualified Lighting Consultant or Electrical Contractor.
- * Water Feature Details are indicative only and are subject to detailed design by a specialist Water Feature designer.
- * Service location on plans are indicative only. 360 Degrees Landscape Architects Pty Ltd accepts no responsibility for the accuracy of service locations shown or for services not shown. It is the responsibility of the contractor to determine service locations prior to the commencement of work, including contacting Dial Before You Dig and performing on site service locations. Locate and protect all services on site and in adjacent public domain. Any damages to services and associated damages remains the responsibility of the contractor and shall be rectified at no cost to the client or any other party.
- *All adjoining property elements including but not limited to buildings, walls, trees and paving to be protected. Damaged elements remain the responsibility of the contractor and shall be rectified at no cost to the client or any other party.
- * Existing trees to be retained are to be protected to Council and Project Arborist's requirements. No vehicular traffic, stockpiling or storage of materials within Tree Protection Zones (TPZs).
- * No responsibility will be taken by 360 Degrees Landscape Architects Pty Ltd for any variations in design, construction method, materials specified and general specifications without permission from the Project Landscape Architect.
- * This Drawing is copyright to 360 Degrees Landscape Architects Pty Ltd.

IRRIGATION NOTES

PRELIMINARY

NOT FOR CONSTRUCTION

- * Irrigation by specialist D&C Irrigation Consultant in accordance with the Performance Specification in the Landscape Technical Specification. Refer to Irrigation Consultant documentation for details and requirements of landscape irrigation system.
- * Irrigation is to comply with Council Conditions of Consent and Water Authorities.
- * All turf and garden beds within the site boundary are to be irrigated unless stated otherwise.
- * Irrigation must be spaced at min. 200 centres and adjusted according to plant setout to provide adequate irrigation to all plants.
- * Drip irrigation is to be fully concealed by 75mm minimum of mulch.

Rev	Amendment	Date	Ву
Α	Draft DA	19.08.20	СВ
В	Draft DA	08.09.20	СВ
С	DA	14.09.20	СВ
D	Draft S4.55	21.09.21	внс
F	\$4.55	22 11 21	BHC


PLANT SCHEDULE

Botanical Name	Common Name	Mature Height	Size	Quantity	Native
Trees, Screen Planting & Palms					
Acmena smithii 'Sublime'	Sublime Lilly Pilly	4-5m	400mm	20	N
Backhousia citriodora	Lemon Myrtle	8m	100L	2	N
Bánksia integrifolia	Coast Banksia	5-10m	45L	2 2	, , , , , , , , , , , , , , , ,
Buckinghamia celsissima	lvory Curl	6-8m	45L	1	N ~
Chamaerops humilis	European Fan Palm	1-4m	100L		
Eŭcalyptus botryoides	Bangalay	10-20m	75Ľ	1	N
Howea forsteriana	Kentia Palm	5-10m	ex ground	3	
Livistona australis	Cabbage Palm	10-20m	ex ground	7	N
Pandanus tectorius	Screw Pine	5m	200L	1	-
Plumeria rubra	Frangipani	2-8m	ex ground	2	-
Strelitzia nicolai	Giant Bird of Paradise	6m	200L	1	-
Shrubs & Perennials					
Aloe plicatilis	Fan Aloe	2-4m	400mm	7	-
Correa baeuerlenii	Chef's Cap Correa	2.5m	200mm	48	N
Gardenia augusta 'Florida'	Gardenia	1m	200mm	15	-
Leptospermum laevigatum 'Fore Shore'	Fore Shore Dwarf Tea Tree	0.3-0.5m	200mm	75	N
Ozothamnus diosmifolius	Rice Flower	2m	200mm	25	N
Rosmarinus officinalis	Rosemary	0.6-1.5m	200mm	23	-
Salvia leucantha 'White Velour'	White Velour Mexican Sage	0.6-0.9m	200mm	5	_
Salvia leucantha 'Santa Barbara'	Santa Barbara Salvia	1.2m	200mm	3	_
Telopea 'Wirrimbirra White'	White Waratah	2.5-3m	200mm	17	N
Westringia fruticosa 'Mundi'	Coastal Rosemary	0.5m	200mm	42	N
Grasses & Ferns					
Dianella caerulea	Blue Flax Lily	0.75m	150mm	126	N
Lomandra hystrix	Hystrix Lomandra	0.7-1.5m	150mm	150	N
Lomandra tanika	Tanika Lomandra	0.5m	150mm	32	N
Groundcovers & Climbers					
Actinotus helianthi	Flannel Flower	0.5m	150mm	30	N
Banksia integrifolia 'Roller Coaster'	Roller Coaster Banksia	0.5m	150mm	25	N
Baeckea virgata 'Nana'	Miniature Baeckea	0.5m	150mm	52	N
Casuarina glauca 'Cousin It'	Cousin It Sheoak	0.1-0.2m	150mm	15	N
Chrysocephalum apiculatum	Yellow Buttons	0.2-0.6m	150mm	130	N
Dichondra repens	Kidney Weed	0.1-0.3m	150mm	500	N
Helichrysum italicum	Curry Plant	0.3-0.6m	150mm	32	_
Lampranthus 'Pink Explosion'	Pink Explosion	0.4m	150mm	45	_
Rosmarinus 'Blue Lagoon'	Rosemary Blue Lagoon	0.5-1m	150mm	30	_
Rosmarinus 'Irene'	Rosemary Irene	0.4m	150mm	20	_
Senecio serpens	Blue Chalksticks	0.1-0.3m	150mm	30	_
Viola hederacea	Native Violet	0.1-0.2m	150mm	50	N







Landscape Schedules & Notes

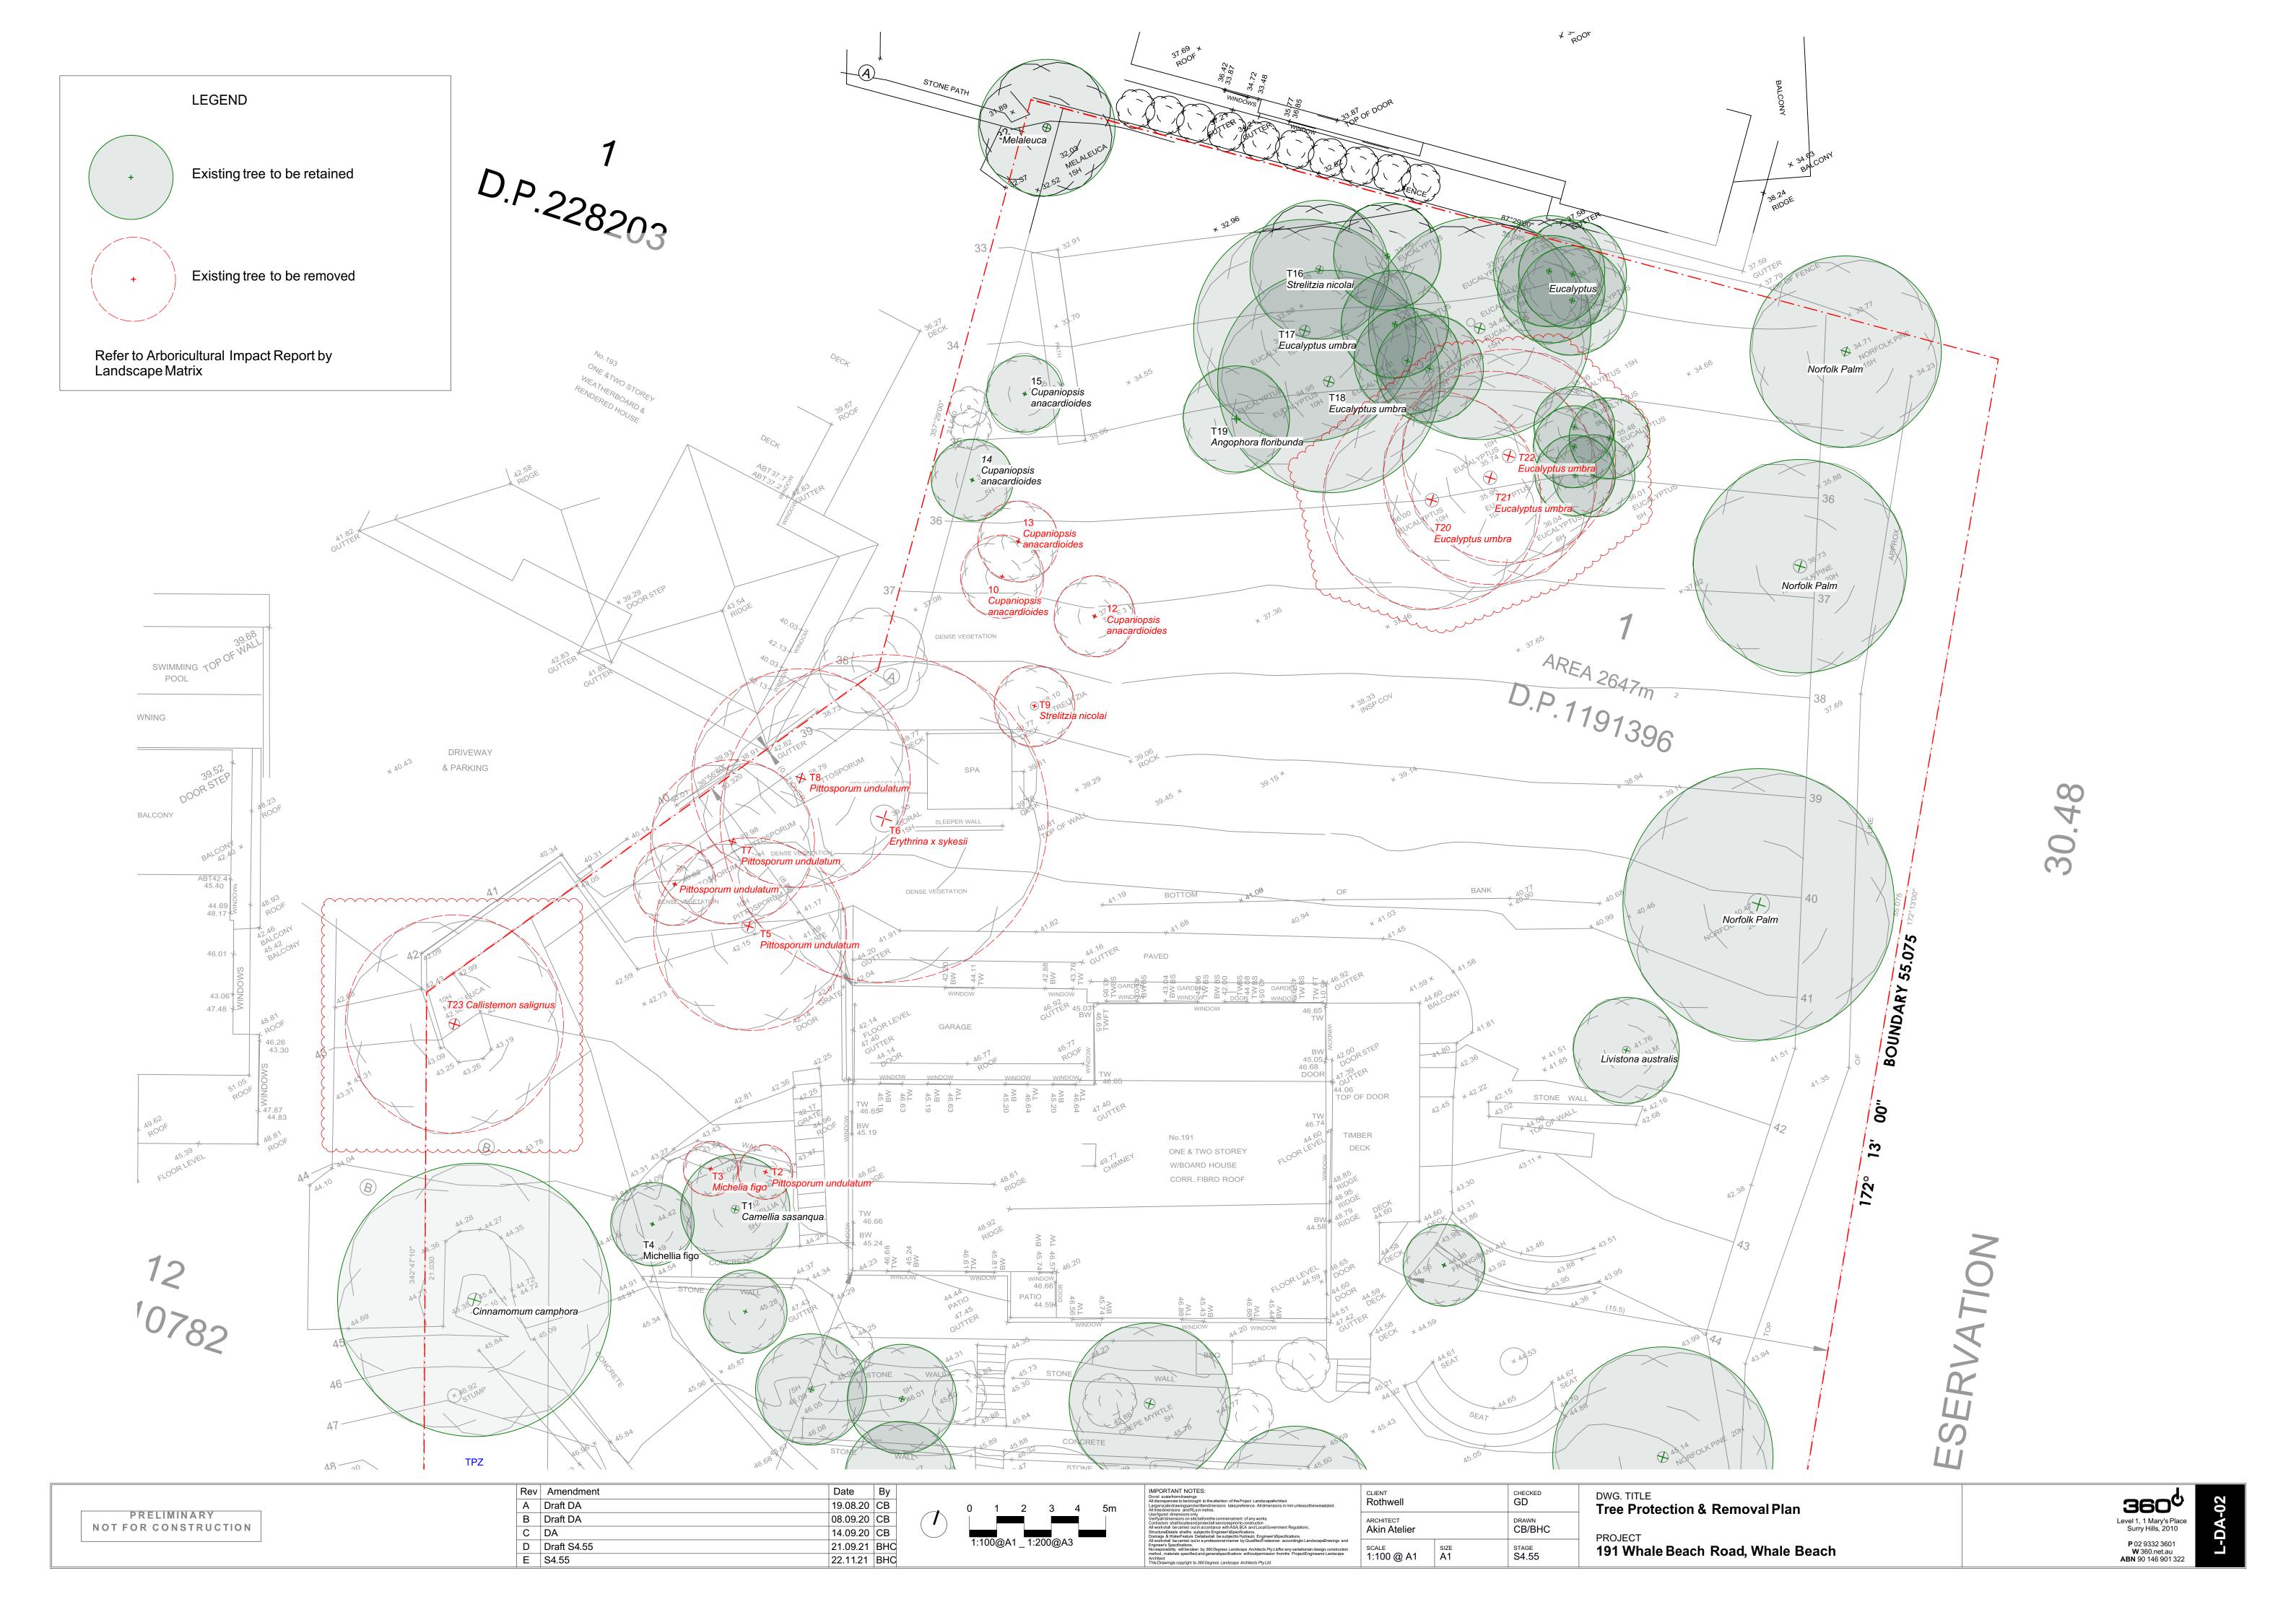



	Rev	Amendment
	Α	Draft DA
PRELIMINARY	В	Draft DA
NOT FOR CONSTRUCTION	С	DA
	D	Draft S4.55
	Е	S4.55

 

 


IMPORTANT NOTES: Donot scale from drawings All discrepancies to be brought to the attention of the Project Landscape/vchitect Largerscale drawings and writtendimensions take preference. All dimensions in mm unless otherwise stated. All tree dimensions and RLs in metres.	CLIENT Rothwell
Use figured dimensions only Verifyall dimensions on site beforethe commencement of any works Contractors shall locateand protectall servicesprior to construction All workshall be carried out in accordance with ASA BCA and Local Covernment Regulations. StructuraDetails shallbe subjectto Engineer'sSpecifications. Drainage & Waterfeature Detailshall be subjectto Hydraulic Engineer'sSpecifications.	ARCHITECT Akin Atelier
All workshall be carried out in a professional miamer by Qualified fradesman accordingto LandscapeDrawings and Engineer's Specifications. No responsibility will betaken by 360 Degrees Landscape Architects PtyLtdfor any variations in design construction method, materials specified and generalspecifications withoutpermission from the Project Engineeror Landscape Architect This Drawingis copyright to 360 Degrees Landscape Architects PtyLtd.	scale 1:100 @ A1

rell		CHECKED GD	DWG. TITLE Landscape F
ct telier		DRAWN CB/BHC	PROJECT
@ A1	SIZE A1	STAGE S4.55	191 Whale B



Rev	Amendment	Date	Ву	
Α	Draft DA	19.08.20	СВ	
В	Draft DA	08.09.20	СВ	
С	DA	14.09.20	СВ	
D	Draft S4.55	21.09.21	BHC	
Е	S4.55	22.11.21	BHC	
	A B C D	A Draft DA B Draft DA C DA D Draft S4.55	A Draft DA 19.08.20 B Draft DA 08.09.20 C DA 14.09.20 D Draft S4.55 21.09.21	A Draft DA 19.08.20 CB B Draft DA 08.09.20 CB C DA 14.09.20 CB D Draft S4.55 21.09.21 BHC

 


NT NOTES: mdrawings s to be brought to the attention of the Project LandscapeArchitect awingsand-writtendimensions take preference. All dimensions in mm unlessotherwisestated. ns and RLs in metres.	CLIENT Rothwell	CHECKED GD	
ensions only sions on site beforethe commencement of any works. Illiocate and protectall servicesprior to construction. carried out in accordance with AAS BCA and Local Covernment Regulations. s shallbe subjectto Engineer'sSpecifications. terferature Detailshall be subjectto Hydraulic Engineer'sSpecifications.	ARCHITECT Akin Atelier	DRAWN CB/BHC	
earnied out in a professional manner by Qualified Tradesman accordingto LandscapeDrawings and iffications. will be taken by 360 Degrees Landscape Architects PtyLtoffor any variations in design, construction is specified and generalspecifications withoutpermission from the ProjectEngineeror Landscape copyright to 360 Degrees Landscape Architects PtyLtd.	scale 1:100 @ A1	SIZE A1	STAGE S4.55

DWG. TITLE Landscape Plan - Ground Floor Plan PROJECT 191 Whale Beach Road, Whale Beach





		Rev	Amendment	Date
		Α	Draft DA	19.08.
	PRELIMINARY	В	Draft DA	08.09
	NOT FOR CONSTRUCTION	С	DA	14.09
		D	Draft S4.55	21.09
		E	S4.55	22.11.

 

PORTANT NOTES: not scaled from drawings its repanses to be brought to the attention of the Project LandscapeArchitect perscaled rawingsand written dimensions take preference. All dimensions in mm unless otherwisestated. readimensions and RLs in metres.	Rothwell		
Injured dimensions only figal dimensions on site beforethe commencement of any works tractors shall locate and protectal services prior to construction . workshall be carried out in accordance with ASA BCA and Local Government Regulations . clura Details shallbe subjectot Engineer's Specifications . ange & Water Feature Detailsshall be subjector Hydraulic Engineer's Specifications.	ARCHITECT Akin Atelier		DRAWN
vorkshall becarried out in a professional manner by Qualifiedfradesman accordingto LandscapeDrawings and ineer's Specifications. seponsibility will betaken by 360 Degrees Landscape Architects PtyLtdfor any variationsin design, construction nod, materials specified and generalspecifications withoutpermission fromthe ProjectEngineeror Landscape nitect. Drawingis copyright to 360 Degrees Landscape Architects PtyLtd.	scale 1:100 @ A1	SIZE A1	STAGE S4.5


DWG. TITLE Landscape Plan - Pool and Lower Ground Level
PROJECT 191 Whale Beach Road, Whale Beach



INDICATIVE SECTIONAL ELEVATION 1




Rev	Amendment	Date	Ву	
Α	Draft DA	19.08.20	СВ	
В	Draft DA	08.09.20	СВ	
С	DA	14.09.20	СВ	
D	Draft S4.55	21.09.21	внс	
Е	S4.55	22.11.21	BHC	

 

IMPORTANT NOTES: Donot scale from drawings All discrepancies to be brought to the attention of the Project Landscape/vchitect Largerscale drawings and writtendimensions take preference. All dimensions in mm unless otherwisestated. All tree dimensions and RLs in metres.	cL R
Use figured dimensions only Verifyall dimensions on site beforethe commencement of any works, Contractors shall locateand protectall servicesprior to construction. All workshall be carried out in accordance with ASA BCA and Local Government Regulations. StructuraDetails shallbe subjectto Engineer'sSpecifications. Drainage & WaterFeature Detailsshall be subjectto Hydraulic Engineer'sSpecifications.	AR A l
All workshall be carried out in a professional manner by Qualified fradesman accordingto LandscapeDrawings and Engineer's Specifications. Noresponsibility will be taken by 360 Degrees Landscape Architects PtyLtfor any variations in design, construction method, materials specified and generalspecifications without permission from the Project Engineeror Landscape Architect This Drawing is copyright to 360 Degrees Landscape Architects PtyLtd.	sc 1:

	CLIENT Rothwell	CHECKED GD	
	ARCHITECT Akin Atelier	DRAWN CB/BHC	
and ction be	scale 1:100 @ A1	SIZE A1	STAGE S4.55

DWG. TITLE Landscape Sectional Elevation
PROJECT 191 Whale Beach Road, Whale Beach

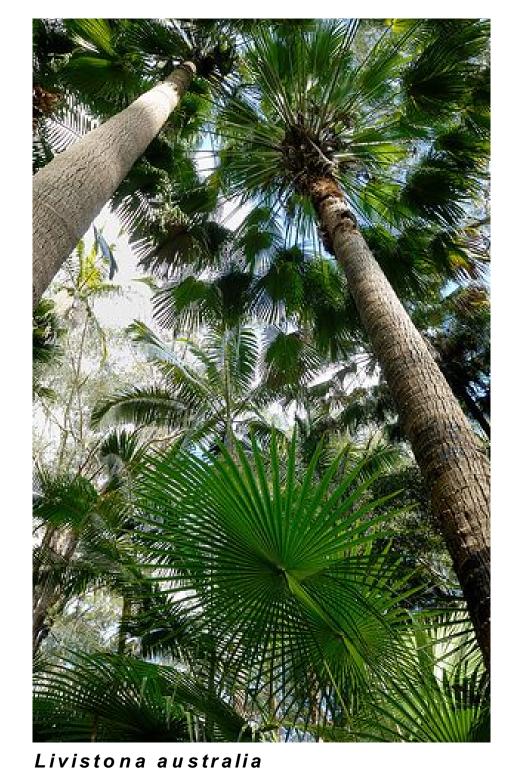




Howea forsteriana





Plumeria rubra Pandanus tectorius

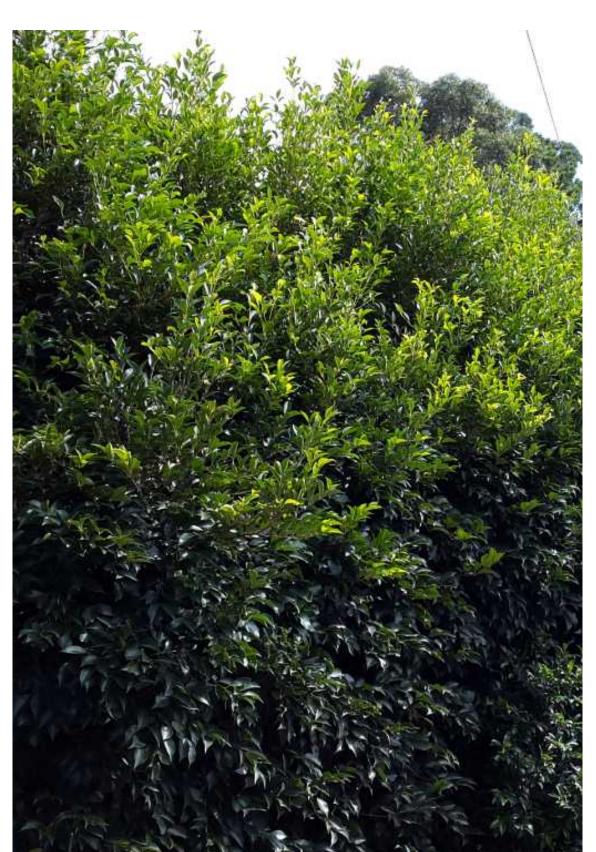







Backhousia citriodora Chamaerops humilis Strelitzia nicolai

CLIENT CHECKED GD

ARCHITECT Akin Atelier

SCALE N/A @ A1

CHECKED GD

DRAWN
CB/BHC

STAGE
STAGE
S4.55

DWG. TITLE
Planting Palette
PROJECT
191 Whale Beach Road, Whale Beach

Acmena 'Sublime











Westringia fruticosa 'Mundi'

Baeckea virgata nana

Salvia leucantha 'Santa barbara'

Salvia leuchantha 'White Velour'

Rosmarinus officinalis















Ozothamnus diosmifolius

Telopea 'Wirrimbia White'


Leptospermum laevigatum 'Fore Shore'


Aloe plicatilis

Rosmarinus officinalis 'Irene' Rosmarinus officinalis 'Blue Lagoon'

Banksia integrifolia 'Roller Coaster'

Casuarina 'Cousin It'

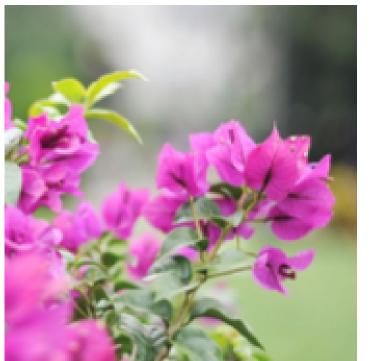

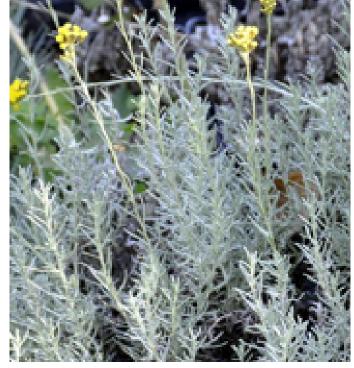













Bougainvillea

Helichrysum italicum

Dianella caerulea 'Little Jess'

Senecio serpens

Lampranthus 'Pink Explosion'

Architect
This Drawingis copyright to 360 Degrees Landscape Architects PtyLtd.

Chrysocephalum apiculatum Dichondra repens

Viola hederacea

Rev	Amendment	Date	Ву	
Α	Draft DA	19.08.20	СВ	
В	Draft DA	08.09.20	СВ	
С	DA	14.09.20	СВ	
D	Draft S4.55	21.09.21	BHC	
Е	S4.55	22.11.21	BHC	
_				=

	CLIENT Rothwell	CHECKED GD		
	ARCHITECT Akin Atelier	DRAWN CB/BHC		
and tion e	scale N/A @ A1	SIZE A1	STAGE S4.55	