

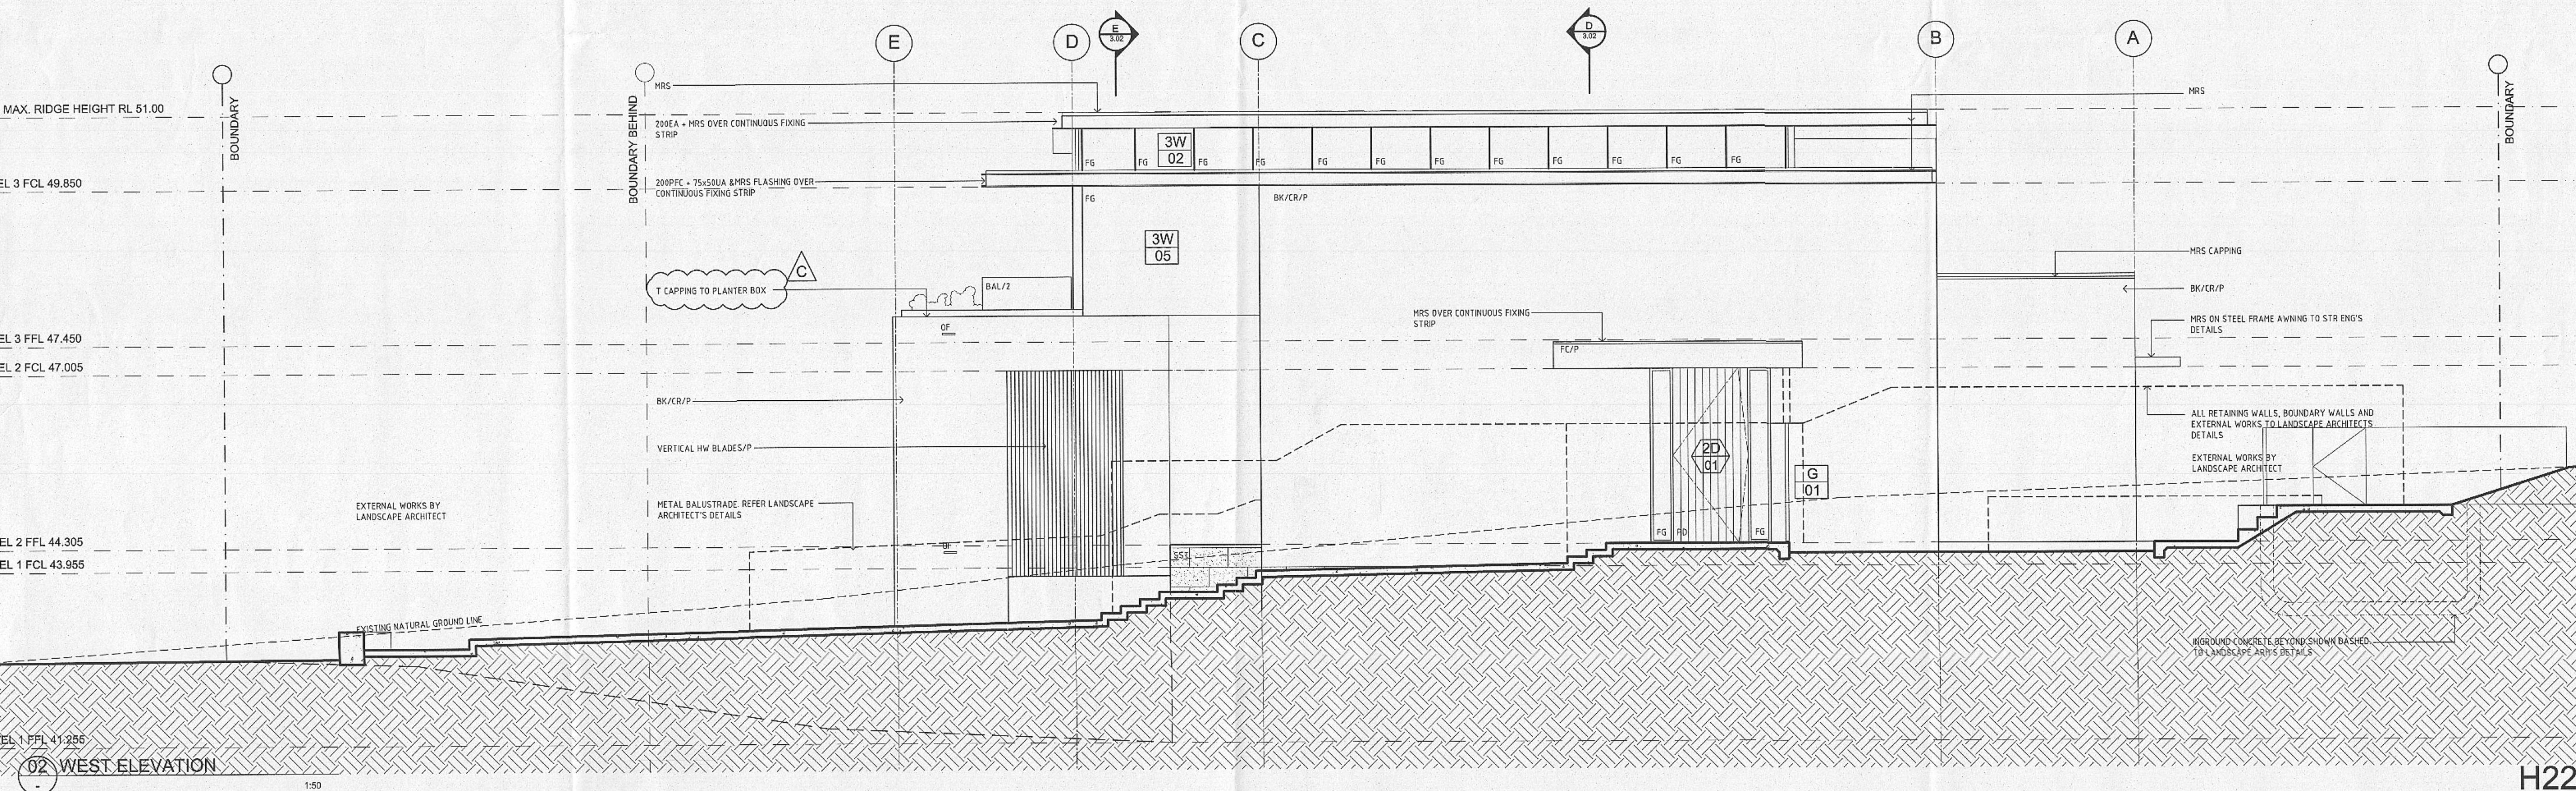


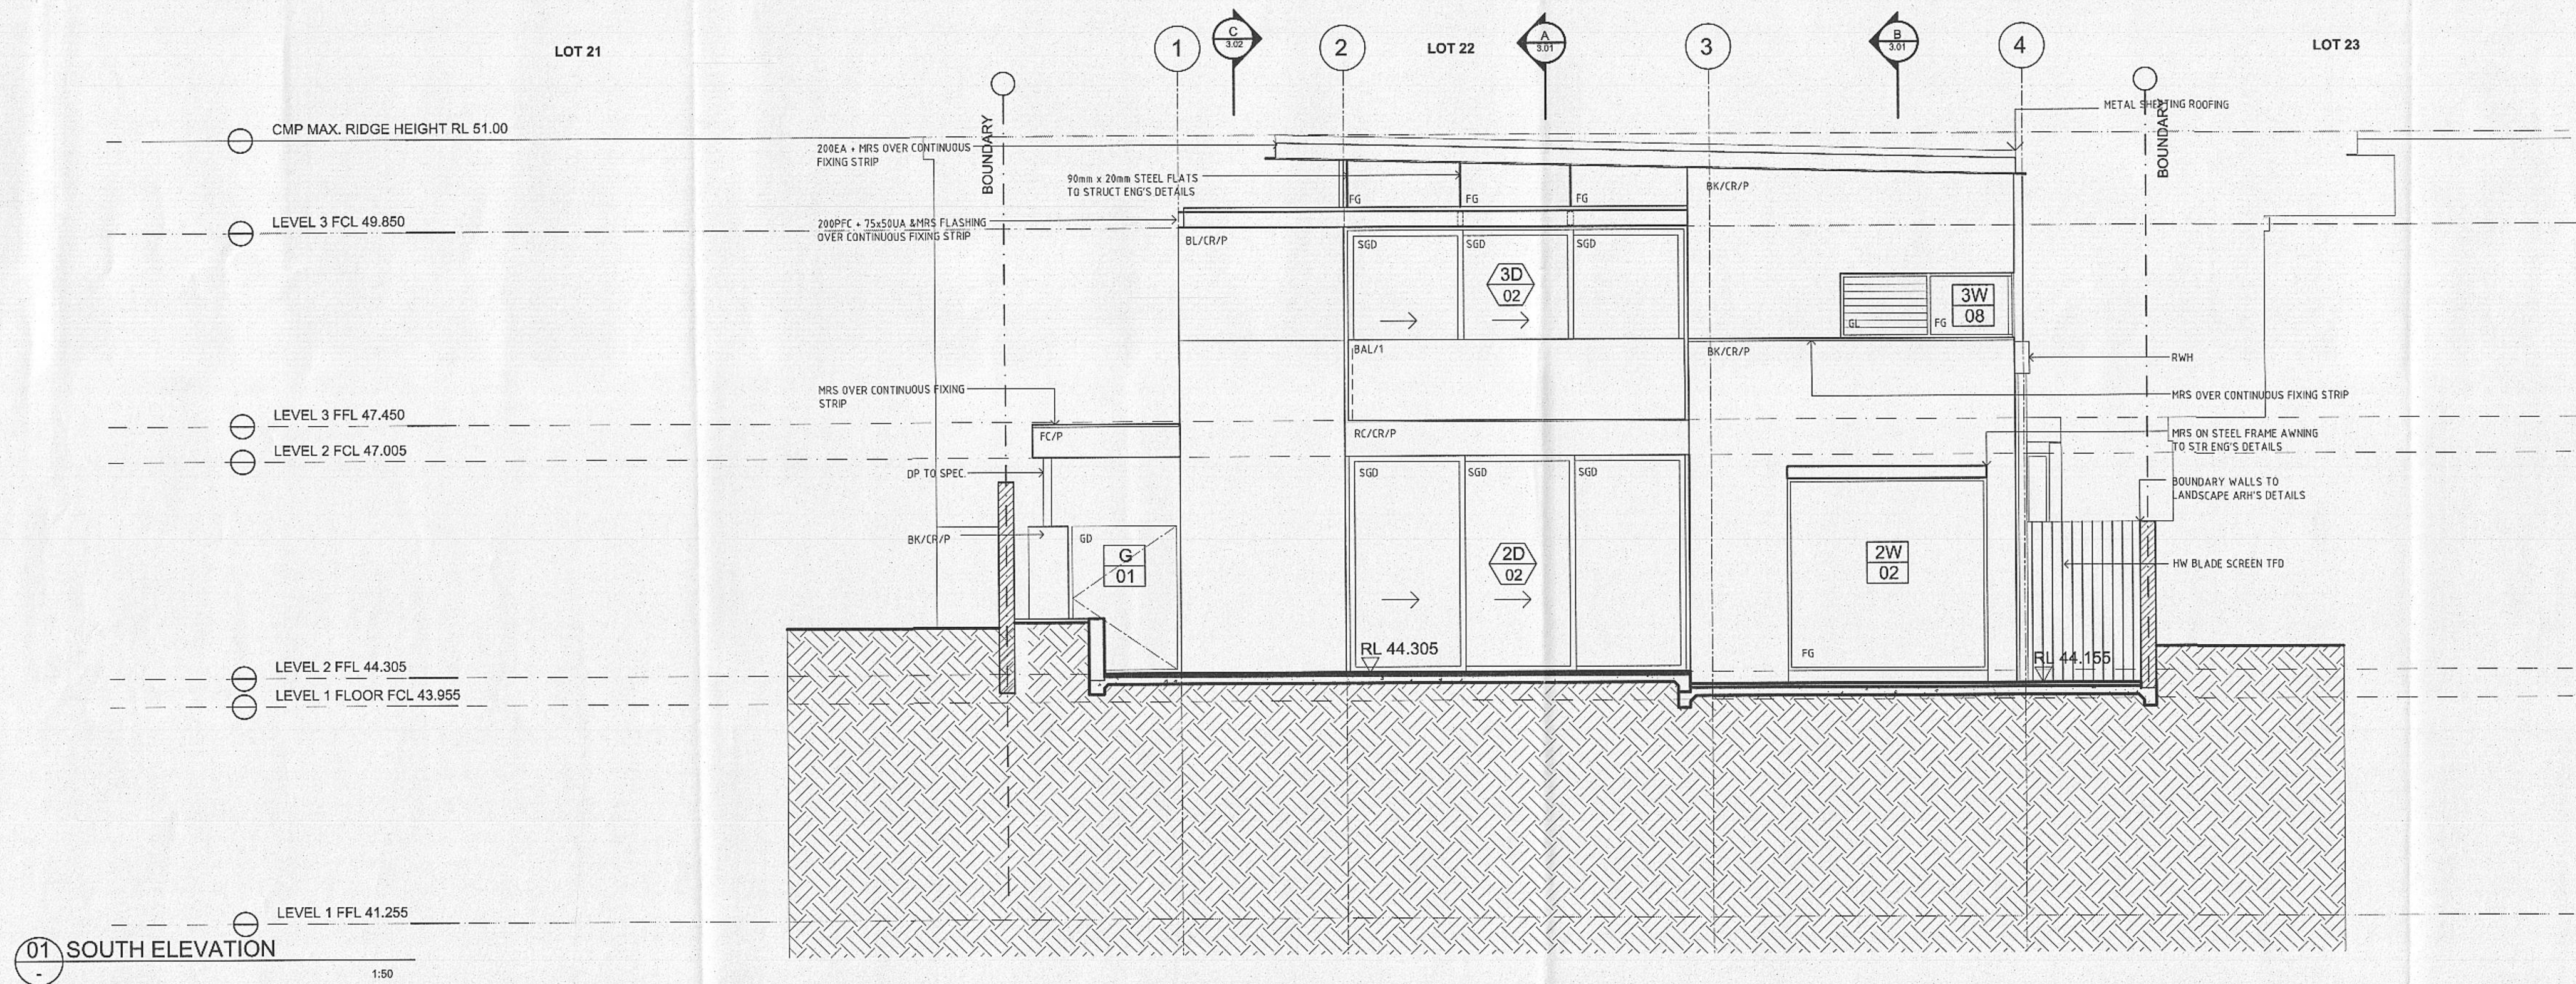

H22


REV:	DATE:	DOCUMENT STATUS/ AMENDMENTS	ABBREVIATIONS:	CONSULTANTS	PROJECT	Drawn JS	Date MARCH 2011
A	10.05.10	ISSUE FOR TENDER	AL ALUMINIUM	CIVIL/ STRUCTURAL/ HYDRAULIC ENGINEER	St. Patricks Estate Manly	Architect Authorised DS	Scale 1:20
B	09.06.10	ISSUE FOR TENDER ADDENDUM	AW ALUMINIUM WINDOW	LANDSCAPE ARCHITECTS	PRECINCT 1 STAGE 4	Client LEND LEASE	Status CONSTRUCTION
C	23.03.11	ISSUE FOR CONSTRUCTION	BAL BALUSTRADE	Mechanical Engineer	for LEND LEASE	Job Number 07 0581	Drawing No. AMP22-2.02/C
			BHD BRICK	Electrical Engineer		Issue HOUSE NO. 22	
			FC FIBRE CEMENT				
			BL BLOCK				
			CJ CONSTRUCTION JOINT				
			CL CENTRE LINE				
			CO CLEAR OUT				
			CR CEMENT RENDER				
			CTF FLOOR TILE				
			CTW WALL TILE				
			DET DETAIL				
			DP DOWN PIPE				
			EA EQUAL ANGLE				
			FC FIBRE CEMENT				
			FG FIXED GLASS				
			FW FLOOR WASTE				
			GD GLAZED DOOR				
			GL GLASS LOUVRES				
			HW HARDWOOD				
			HYD HYDRAULIC				
			INS INSULATION				
			JN JOINERY NUMBER				
			MDF MEDIUM DENSITY FIBREBOARD				
			MRS METAL ROOF SHEETING				
			OF OVERFLOW				
			JP PAINT				
			PBD PLASTERBOARD				
			POP PRE-CAST CONCRETE PAVES				
			PFC PARALLEL FLANGE CHANNEL				
			RC REINFORCED CONCRETE				
			RHS RECTANGULAR HOLLOW SECTION				
			RST RECESSED SHADOW TRIM				
			RWO RAINWATER OUTLET				
			SC STEEL COLUMN				
			SGD SLIDING GLASS DOOR				
			SHS SQUARE HOLLOW SECTION				
			SK SKIRTING				
			SSJ STRUCTURAL SILICONE JOINT				
			SST SANDSTONE				
			SWP STORMWATER PIT				
			TJ TIMBER				
			TD TIMBER DECKING				
			TB TIMBER BATTENS				
			UA UNEQUAL ANGLE				
			UC UNIVERSAL CHANNEL				
			VOS VERIFY ON SITE				
			WPM WATERPROOF MEMBRANE				

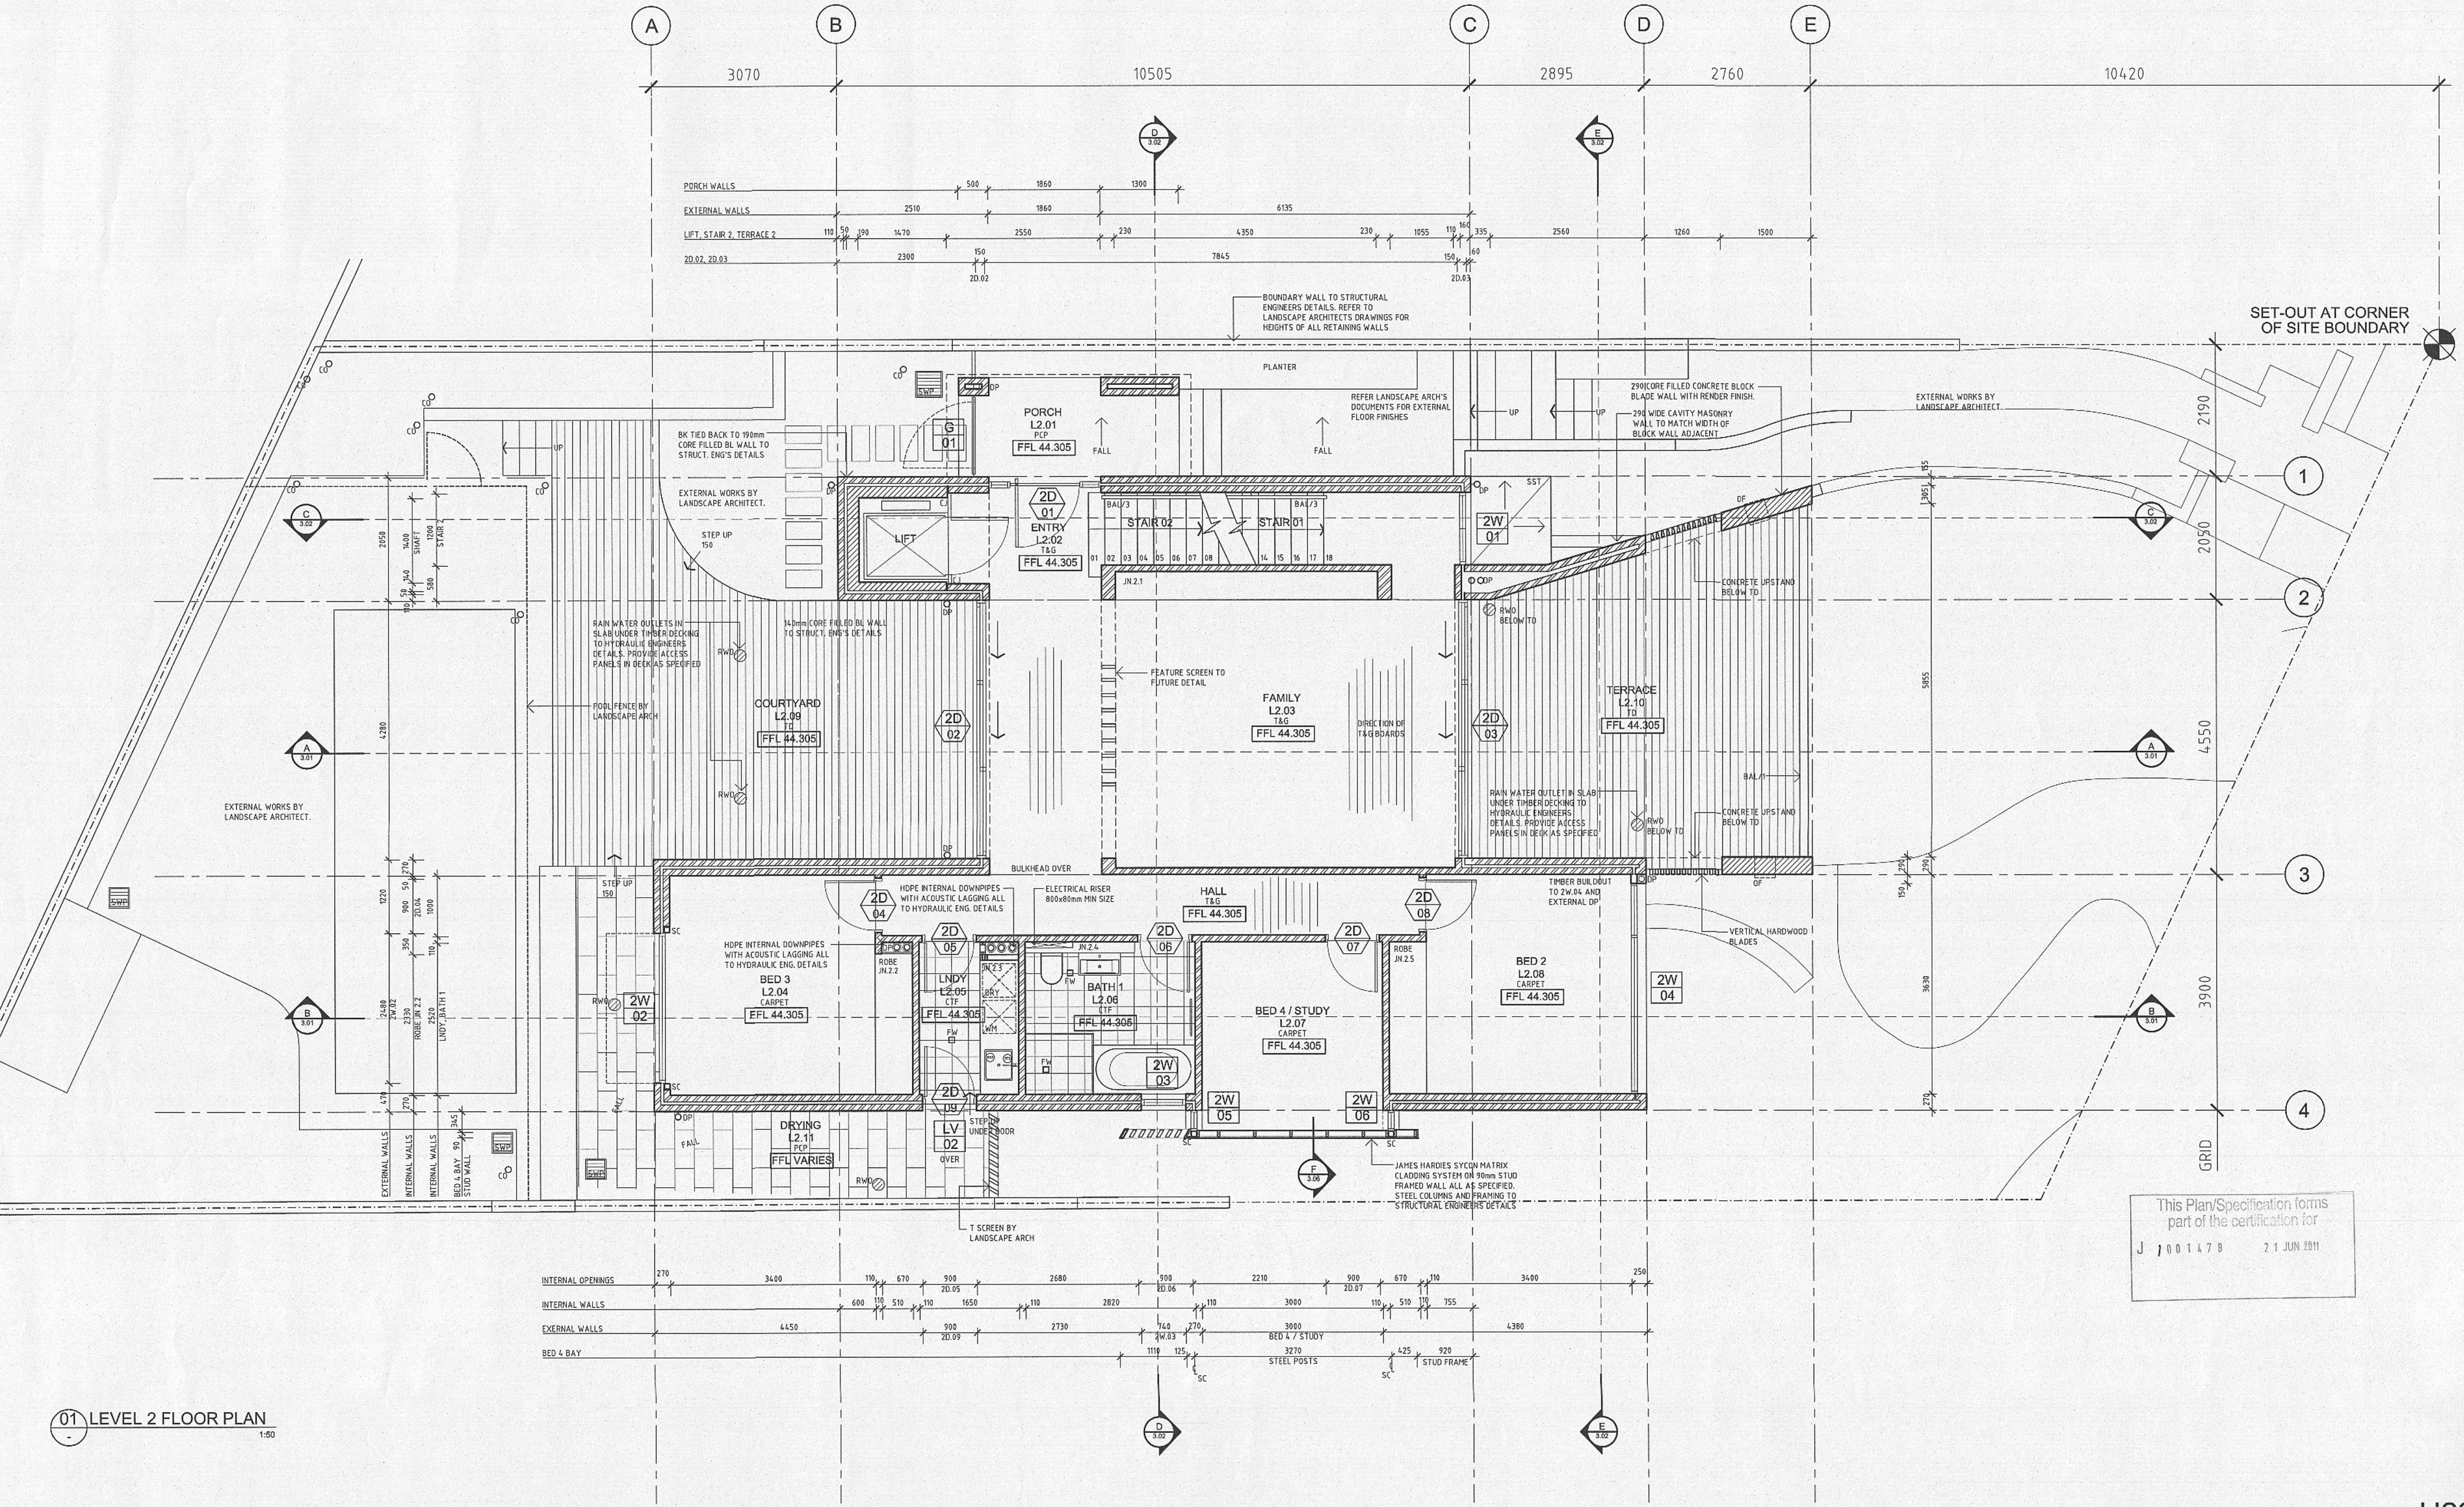

This Plan/Specification forms part of the certification for
J 100147B 21 JUN 2011

REV.	DATE	DOCUMENT STATUS/ AMENDMENTS	ABBREVIATIONS:	CONSULTANTS	PROJECT	Drawn	Date
P1	03.05.10	ISSUE FOR INFORMATION	AL ALUMINIUM	CIVIL/STRUCTURAL/	St. Patricks Estate Manly	JS	MARCH 2011
A	10.05.10	ISSUE FOR TENDER	AW ALUMINIUM WINDOW	HYDRAULIC ENGINEER	Precinct 1 Stage 4	DS	Scale 1:50
B	09.06.10	ISSUE FOR TENDER ADDENDUM	BAL BALUSTRADE	Hughes Trearman	Client	LEND LEASE	Status CONSTRUCTION
C	23.03.11	ISSUE FOR CONSTRUCTION	BHD BULKHEAD	Landscaping Architects	File		Drawn CD Certified Draftsman 22
			BK BRICK	MECHANICAL ENGINEER	Drawn CD Certified Draftsman 22		Drawn CD Certified Draftsman 22
			BL BLOCK	Electrical	Drawn CD Certified Draftsman 22		Drawn CD Certified Draftsman 22
			CJ CONSTRUCTION JOINT	Electrical	Drawn CD Certified Draftsman 22		Drawn CD Certified Draftsman 22
			CL CENTRE LINE	Electrical	Drawn CD Certified Draftsman 22		Drawn CD Certified Draftsman 22
			CO CLEAR OUT	Electrical	Drawn CD Certified Draftsman 22		Drawn CD Certified Draftsman 22
			CR CEMENT RENDER	Electrical	Drawn CD Certified Draftsman 22		Drawn CD Certified Draftsman 22
			CTF FLOOR TILE	Electrical	Drawn CD Certified Draftsman 22		Drawn CD Certified Draftsman 22
			CTW WALL TILE	Electrical	Drawn CD Certified Draftsman 22		Drawn CD Certified Draftsman 22
			DET DETAIL	Electrical	Drawn CD Certified Draftsman 22		Drawn CD Certified Draftsman 22
			DP DOWN PIPE	Electrical	Drawn CD Certified Draftsman 22		Drawn CD Certified Draftsman 22
			EA EQUAL ANGLE	Electrical	Drawn CD Certified Draftsman 22		Drawn CD Certified Draftsman 22
			FC FIBRE CEMENT	Electrical	Drawn CD Certified Draftsman 22		Drawn CD Certified Draftsman 22
			FG FIXED GLASS	Electrical	Drawn CD Certified Draftsman 22		Drawn CD Certified Draftsman 22
			FW FLOOR WASTE	Electrical	Drawn CD Certified Draftsman 22		Drawn CD Certified Draftsman 22
			GL GLAZED DOOR	Electrical	Drawn CD Certified Draftsman 22		Drawn CD Certified Draftsman 22
			GL GLASS LOUVRES	Electrical	Drawn CD Certified Draftsman 22		Drawn CD Certified Draftsman 22
			HW HARDWOOD	Electrical	Drawn CD Certified Draftsman 22		Drawn CD Certified Draftsman 22
			HYD HYDRAULIC	Electrical	Drawn CD Certified Draftsman 22		Drawn CD Certified Draftsman 22
			INS INSULATION	Electrical	Drawn CD Certified Draftsman 22		Drawn CD Certified Draftsman 22
			JN JOINT NUMBER	Electrical	Drawn CD Certified Draftsman 22		Drawn CD Certified Draftsman 22
			MDF MEDIUM DENSITY FIBREBOARD	Electrical	Drawn CD Certified Draftsman 22		Drawn CD Certified Draftsman 22
			MRS METAL ROOF SHEETING	Electrical	Drawn CD Certified Draftsman 22		Drawn CD Certified Draftsman 22
			OF OVERFLOW	Electrical	Drawn CD Certified Draftsman 22		Drawn CD Certified Draftsman 22
			P PAINT	Electrical	Drawn CD Certified Draftsman 22		Drawn CD Certified Draftsman 22
			PBD PLASTERBOARD	Electrical	Drawn CD Certified Draftsman 22		Drawn CD Certified Draftsman 22
			PCP PRE-CAST CONCRETE PAVEMENT	Electrical	Drawn CD Certified Draftsman 22		Drawn CD Certified Draftsman 22
			PCP PARALLEL FLANGE CHANNEL	Electrical	Drawn CD Certified Draftsman 22		Drawn CD Certified Draftsman 22
			RC REINFORCED CONCRETE	Electrical	Drawn CD Certified Draftsman 22		Drawn CD Certified Draftsman 22
			RHS RECTANGULAR HOLLOW SECTION	Electrical	Drawn CD Certified Draftsman 22		Drawn CD Certified Draftsman 22
			RST RECESSED SHADOW TRIM	Electrical	Drawn CD Certified Draftsman 22		Drawn CD Certified Draftsman 22
			RWO RAINWATER OUTLET	Electrical	Drawn CD Certified Draftsman 22		Drawn CD Certified Draftsman 22
			SC STEEL COLUMN	Electrical	Drawn CD Certified Draftsman 22		Drawn CD Certified Draftsman 22
			SGD SLIDING GLASS DOOR	Electrical	Drawn CD Certified Draftsman 22		Drawn CD Certified Draftsman 22
			SHS SQUARE HOLLOW SECTION	Electrical	Drawn CD Certified Draftsman 22		Drawn CD Certified Draftsman 22
			SK SKIRTING	Electrical	Drawn CD Certified Draftsman 22		Drawn CD Certified Draftsman 22
			SSJ STRUCTURAL SILICONE JOINT	Electrical	Drawn CD Certified Draftsman 22		Drawn CD Certified Draftsman 22
			SST SANDSTONE	Electrical	Drawn CD Certified Draftsman 22		Drawn CD Certified Draftsman 22
			SWP STORMWATER PIT	Electrical	Drawn CD Certified Draftsman 22		Drawn CD Certified Draftsman 22
			IT TIMBER	Electrical	Drawn CD Certified Draftsman 22		Drawn CD Certified Draftsman 22
			TD TIMBER DECKING	Electrical	Drawn CD Certified Draftsman 22		Drawn CD Certified Draftsman 22
			TB TIMBER BATTENS	Electrical	Drawn CD Certified Draftsman 22		Drawn CD Certified Draftsman 22
			UA UNEQUAL ANGLE	Electrical	Drawn CD Certified Draftsman 22		Drawn CD Certified Draftsman 22
			UC UNIVERSAL CHANNEL	Electrical	Drawn CD Certified Draftsman 22		Drawn CD Certified Draftsman 22
			VOS VERIFY ON SITE	Electrical	Drawn CD Certified Draftsman 22		Drawn CD Certified Draftsman 22
			WPM WATERPROOF MEMBRANE	Electrical	Drawn CD Certified Draftsman 22		Drawn CD Certified Draftsman 22

H22

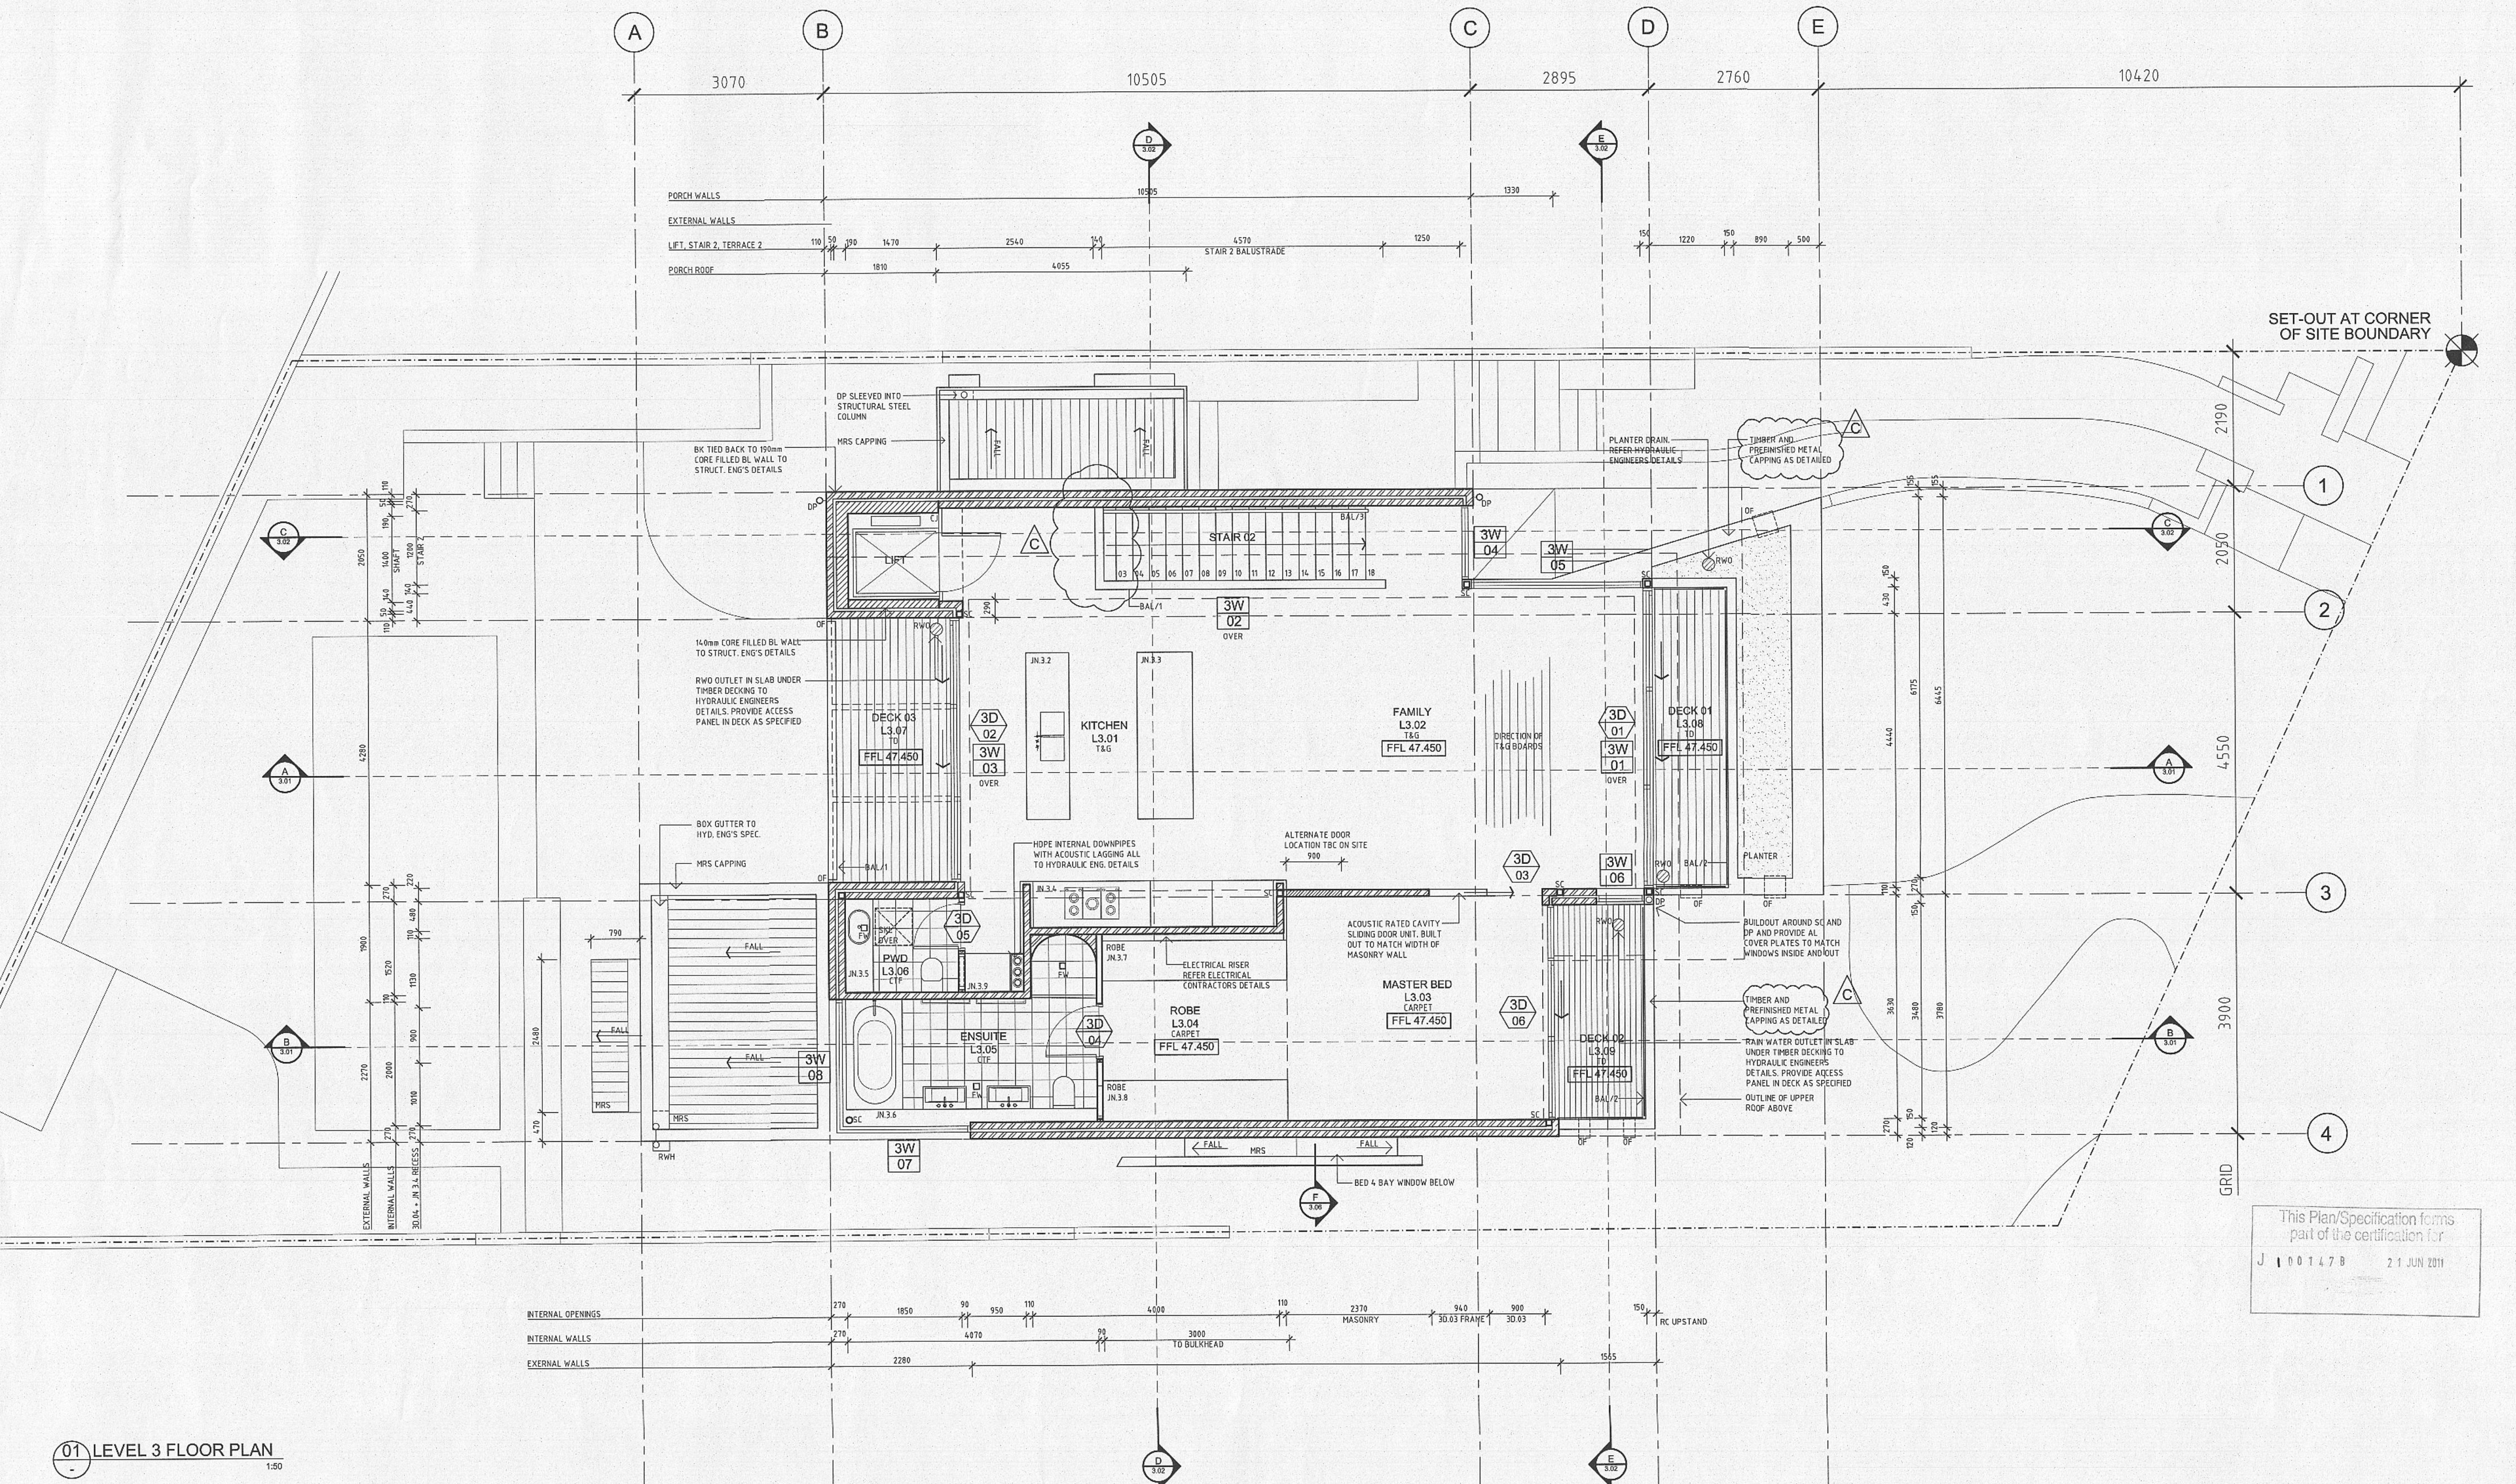

01 LEVEL 3 FLOOR PLAN
1:50



H22

REV:	DATE:	DOCUMENT STATUS/AMENDMENTS	ABBREVIATIONS:	CONSULTANTS	PROJECT	Drawn JS	Date MARCH 2011
P1	03.05.10	ISSUE FOR INFORMATION	AL ALUMINIUM WINDOW	CIVIL/STRUCTURAL/HYDRAULIC ENGINEER	St. Patricks Estate Manly	Architect Authorised DS	Scale 1:50
A	10.05.10	ISSUE FOR TENDER	BAL BALUSTRADE	LANDSCAPE ARCHITECTS	PRECINCT 1 STAGE 4	Client LEND LEASE	Status CONSTRUCTION
B	09.08.10	ISSUE FOR TENDER ADDENDUM	BHD BULKHEAD	MECHANICAL ENGINEER	for LEND LEASE	File	21 JUN 2011
C	23.03.11	ISSUE FOR CONSTRUCTION	BK BRICK	ELECTRICAL ENGINEER			
			BJ BLOCK				
			CL CONSTRUCTION JOINT				
			CO CENTRE LINE				
			CR CLEAR OUT				
			CR CEMENT RENDER				
			CTF FLOOR TILE				
			CTW WALL TILE				
			DET DETAIL				
			DP DOWN PIPE				
			EA EQUAL ANGLE				
			FC FIBRE CEMENT				
			FG FIXED GLASS				
			FW FLOOR WASTE				
			GL GLAZED DOOR				
			QL GLASS LOUVRES				
			HW HARDWOOD				
			HYD HYDRAULIC				
			INS INSULATION				
			JN JOINERY NUMBER				
			MDF MEDIUM DENSITY FIBREBOARD				
			MRS METAL ROOF SHEETING				
			CF OVERFLOW				
			JP PAINT				
			PBD PLASTERBOARD				
			PCP PRE-CAST CONCRETE PAVES				
			GL GLASS LOUVRES				
			RC REINFORCED CONCRETE				
			RHS RECTANGULAR HOLLOW SECTION				
			RST RECESSED SHADOW TRIM				
			RWO RAINWATER OUTLET				
			SC STEEL COLUMN				
			SGD SLIDING GLASS DOOR				
			SHS SQUARE HOLLOW SECTION				
			SK SKIRTING				
			SSJ STRUCTURAL SILICONE JOINT				
			SST SANDSTONE				
			SWP STORMWATER PIT				
			IT TIMBER				
			TD TIMBER DECKING				
			TB TIMBER BATTENS				
			UA UNEQUAL ANGLE				
			UC UNIVERSAL CHANNEL				
			VOS VERIFY ON SITE				
			WPM WATERPROOF MEMBRANE				


This Plan/Specification forms
part of the certification for
J 100147B 21 JUN 2011

1:50


[illegible]

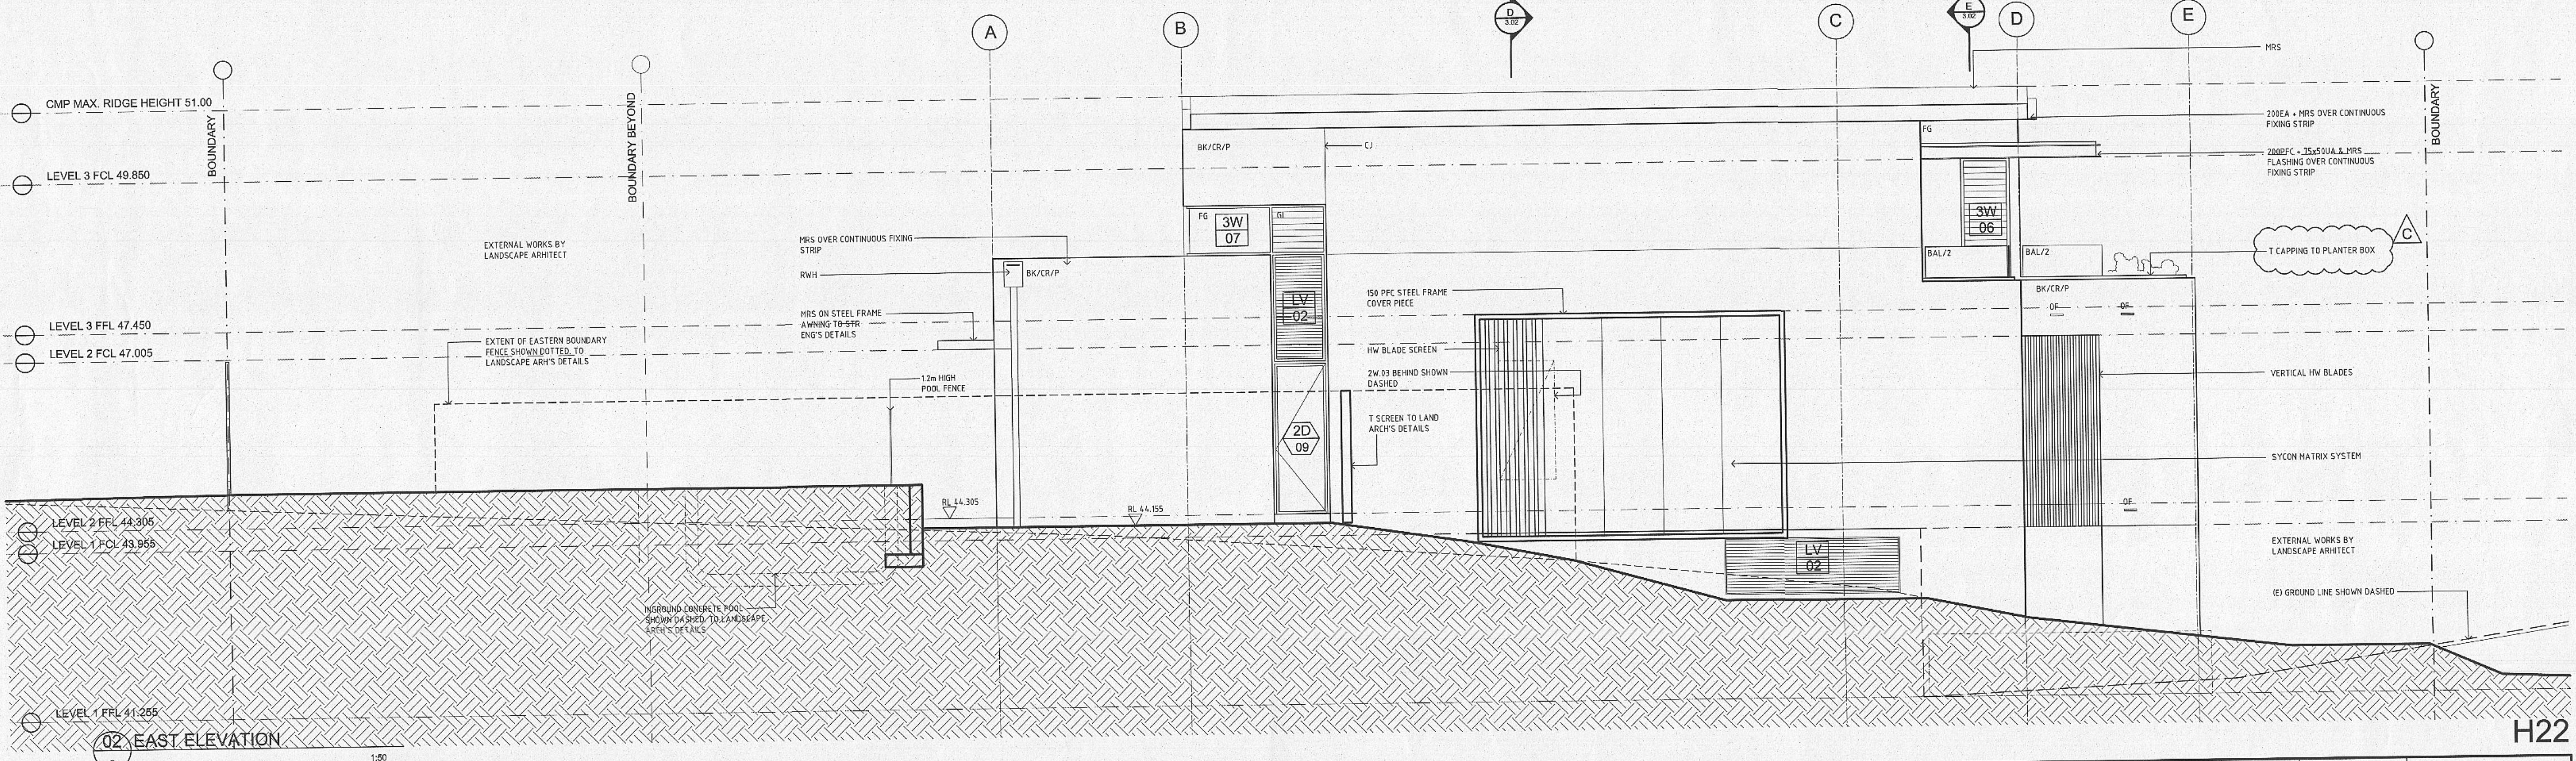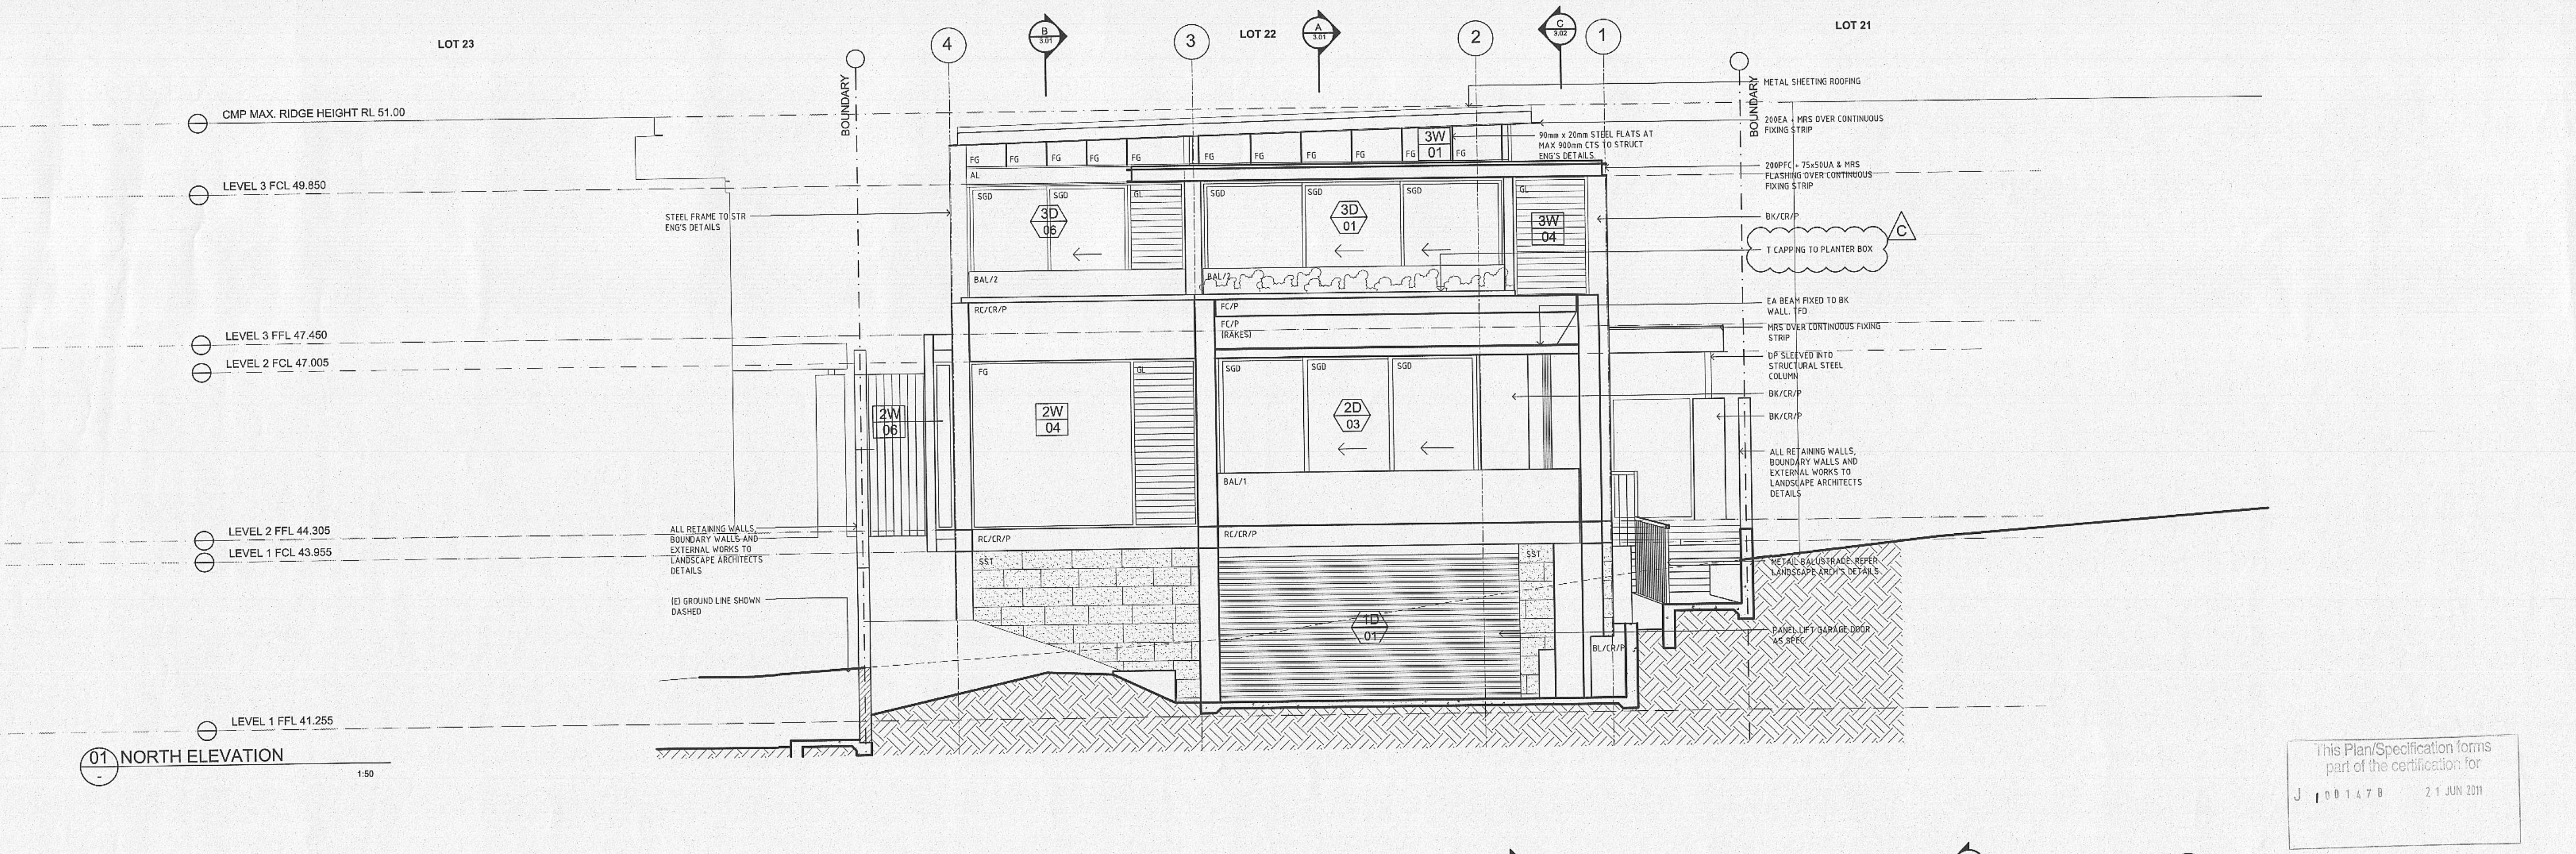

REV: DATE: DOCUMENT STATUS/ AMENDMENTS			ABBREVIATIONS:		CONSULTANTS										PROJECT	Drawn JS	Date
A	10.05.10	ISSUE FOR TENDER	AL ALUMINIUM	CTW WALL TILE	INS INSULATION	RST RECESSED SHADOW TRIM	10 20 30 40 50				CIVIL/ STRUCTURAL/ HYDRAULIC ENGINEER	BUSHFIRE CONSULTANT	PO Box 660	52 Albion Street	T +61 2 9281 4399	St. Patricks Estate Manly	MARCH 2011
B	02.06.10	ISSUE FOR TENDER ADDENDUM	AW ALUMINIUM WINDOW	DP DETAIL	JN JOINERY NUMBER	RWO RAINWATER OUTLET					RUGHEE TITSMAN	Building Code & Bushfire	Darlinghurst	Surry Hills	F +61 2 9281 4397	PRECINCT 1 STAGE 4	
C	23.03.11	ISSUE FOR CONSTRUCTION	BAL BALUSTRADE	DM DOWN PIPE	MOD MEDIUM DENSITY FIBREBOARD	SC STEEL COLUMN					HERITAGE CONSULTANT	Tanner Architects	NSW 1500	NSW 2010	info@tannerarchitects.com.au	LEND LEASE	Scale 1:20
			BHD BULKHEAD	EA EQUAL ANGLE	MRS METAL ROOF SHEETING	SGD SLIDING GLASS DOOR					LANDSCAPE ARCHITECTS	Tanner Architects	Australia	Australia	www.tannerarchitects.com.au	Client LEND LEASE	Status CONSTRUCTION
			BK BRICK	FC FIBRE CEMENT	OF OVERFLOW	SHS SQUARE HOLLOW SECTION					JP PAINT	Terry Thompson PBE				JOB NUMBER 07 0581	DRAWING NO. / ISSUE AMP22-2.01/C
			BL BLOCK	FG FIXED GLASS	OR PRE-CAST CONCRETE PAVER	SK SKIRTING					SSJ STRUCTURAL SILICONE JOINT	Efficient Living				HOUSE NO. HOUSE 22	
			CJ CONSTRUCTION JOINT	GD GLAZED DOOR	PBD PLASTERBOARD	SST SANDSTONE					UA UNEQUAL ANGLE	UNIVERSAL CHANNEL				DRAWING TITLE ELEVATIONS SHEET 1	
			CL CENTRE LINE	GL GLASS LOUVRES	PFC PARALLEL FLANGE CHANNEL	SWP STORMWATER PIT					UC UNIVERSAL CHANNEL	SURVEYOR					
			CO CLEAR OUT	HW HARDWOOD	RC REINFORCED CONCRETE	T/T TIMBER					VOS VERIFY ON SITE	Whitmore					
			CR CEMENT RENDER	HYD HYDRAULIC	RHS RECTANGULAR HOLLOW SECTION	TD TIMBER DECKING					WPM WATERPROOF MEMBRANE						
			CTF FLOOR TILE														

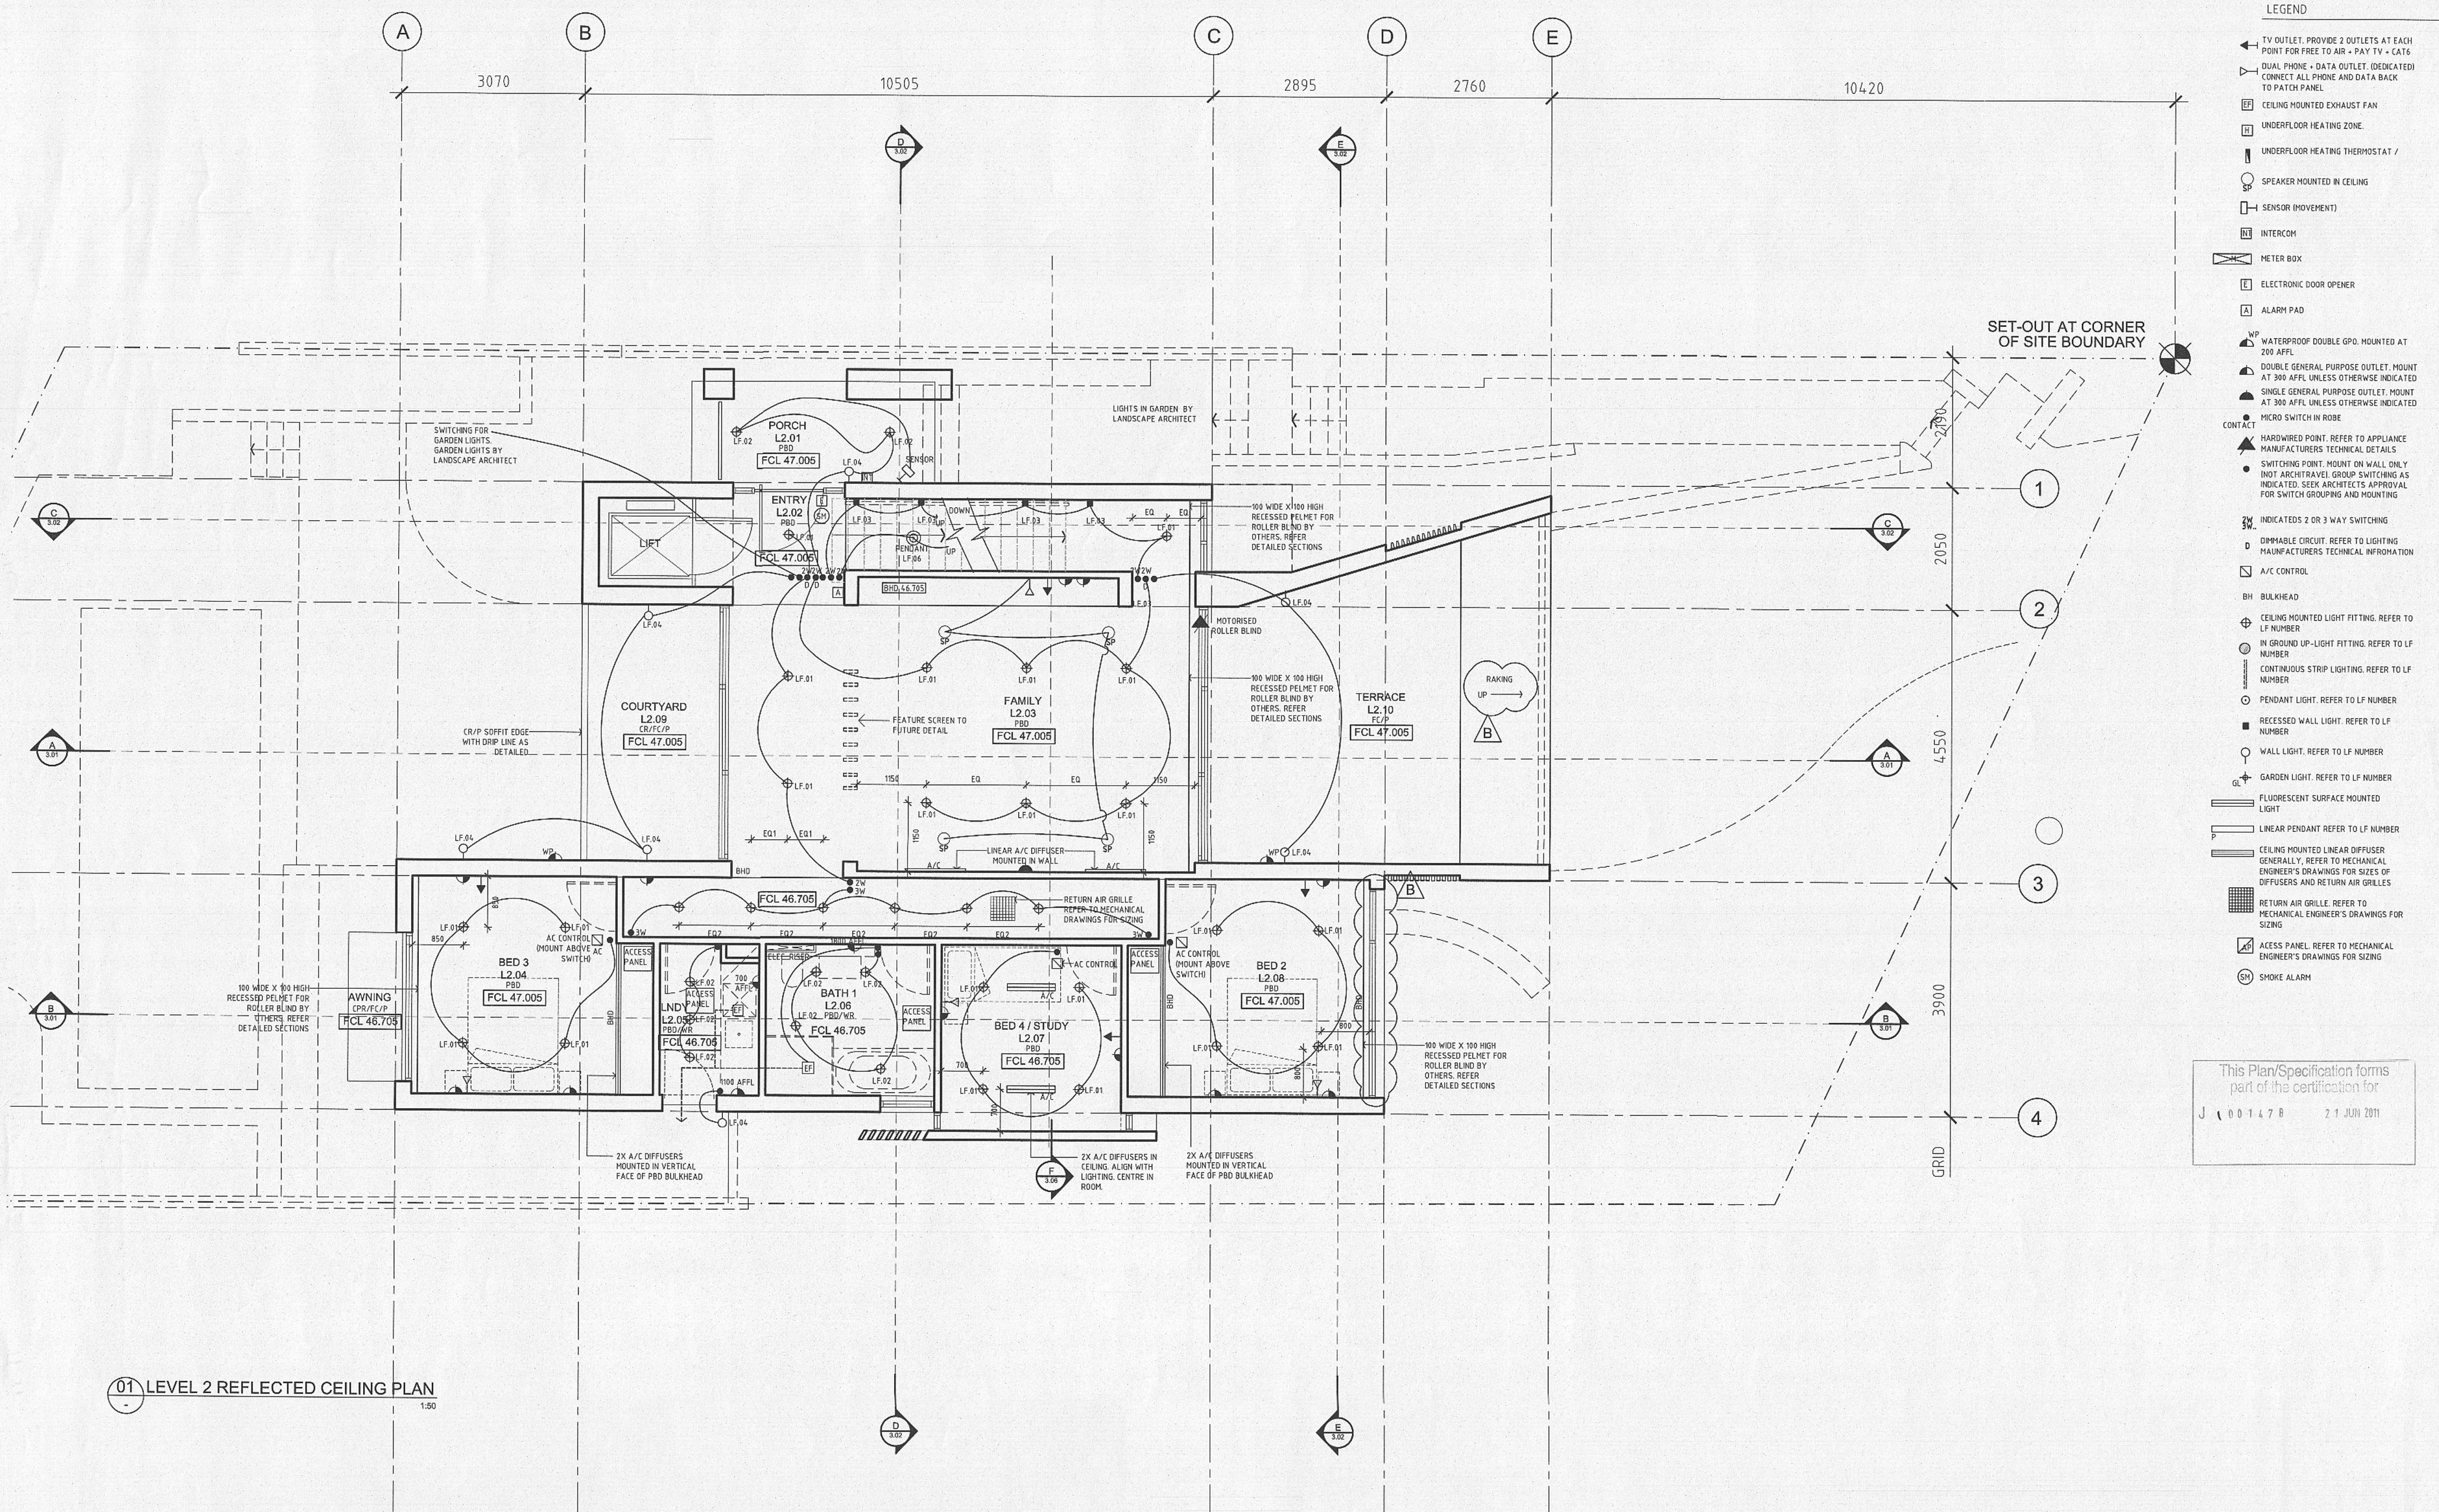

REV:	DATE:	DOCUMENT STATUS/ AMENDMENTS	ABBREVIATIONS:												CONSULTANTS										PROJECT										Drawn	Date												
A	16.05.10	ISSUE FOR INFORMATION	AL ALUMINIUM	CTW WALL TILE	INS INSULATION	RST RECESSED SHADOW TRIM											CIVIL/ STRUCTURAL/ HYDRAULIC ENGINEER										BUSHFIRE CONSULTANT										PROJECT										SN	MARCH 2011
P1	16.05.10	ISSUE FOR TENDER	AW ALUMINIUM WINDOW	DET DETAIL	JN JOINERY NUMBER	RWO RAINWATER OUTLET											SC STEEL, CADILLAC										Building Code & Building										SN										Scale	
A	16.05.10	ISSUE FOR TENDER	BAL BALUSTRADE	MDF DOWN PIPE	MF MEDIUM DENSITY FIBREBOARD	SGD SLIDING GLASS DOOR											LANDSCAPE ARCHITECTS										HERITAGE CONSULTANT										ST PATRICKS ESTATE MANLY										DS	1:50
B	09.06.10	ISSUE FOR TENDER ADDENDUM	BHD BULKHEAD	EA EQUAL ANGLE	MRS METAL ROOF SHEETING	SQS SQUARE HOLLOW SECTION											TANNER ARCHITECTS										TANNER ARCHITECTS										PRECINCT 1 STAGE 4										Client	Status
C	23.03.11	ISSUE FOR CONSTRUCTION	BK BRICK	FC FIBRE CEMENT	OF OVERFLOW	SSJ SLIDING GLASS DOOR											MECHANICAL ENGINEER										BARIK CONSULTANT										LEND LEASE										LEND LEASE	CONSTRUCTION
			BL BLOCK	FG FIXED GLASS	PA PLASTERBOARD	SST SANDSTONE											TANNER ARCHITECTS										TANNER ARCHITECTS										LEND LEASE										Client	Status
			CJ CONSTRUCTION JOINT	FW FLOOR WASTE	PBD PLASTERBOARD	SWP STORMWATER PIT											TANNER ARCHITECTS										TANNER ARCHITECTS										LEND LEASE										Client	Status
			CL CENTRE LINE	GD GLAZED DOOR	PC PRE-CAST CONCRETE PAVEMENT	TD TIMBER DECKING											TANNER ARCHITECTS										TANNER ARCHITECTS										LEND LEASE										Client	Status
			CO CLEAR OUT	PC PARALLEL GLASS LOUVRES	RC REINFORCED CONCRETE	TD TIMBER DECKING											TANNER ARCHITECTS										TANNER ARCHITECTS										LEND LEASE										Client	Status
			CR FLOEM RENDER	HW HARDWOOD	RHS RECTANGULAR HOLLOW SECTION	TD TIMBER DECKING											TANNER ARCHITECTS										TANNER ARCHITECTS										LEND LEASE										Client	Status
			CTF CEILING TILE	HYD HYDRAULIC	RHS RECTANGULAR HOLLOW SECTION	TD TIMBER DECKING											TANNER ARCHITECTS										TANNER ARCHITECTS										LEND LEASE										Client	Status


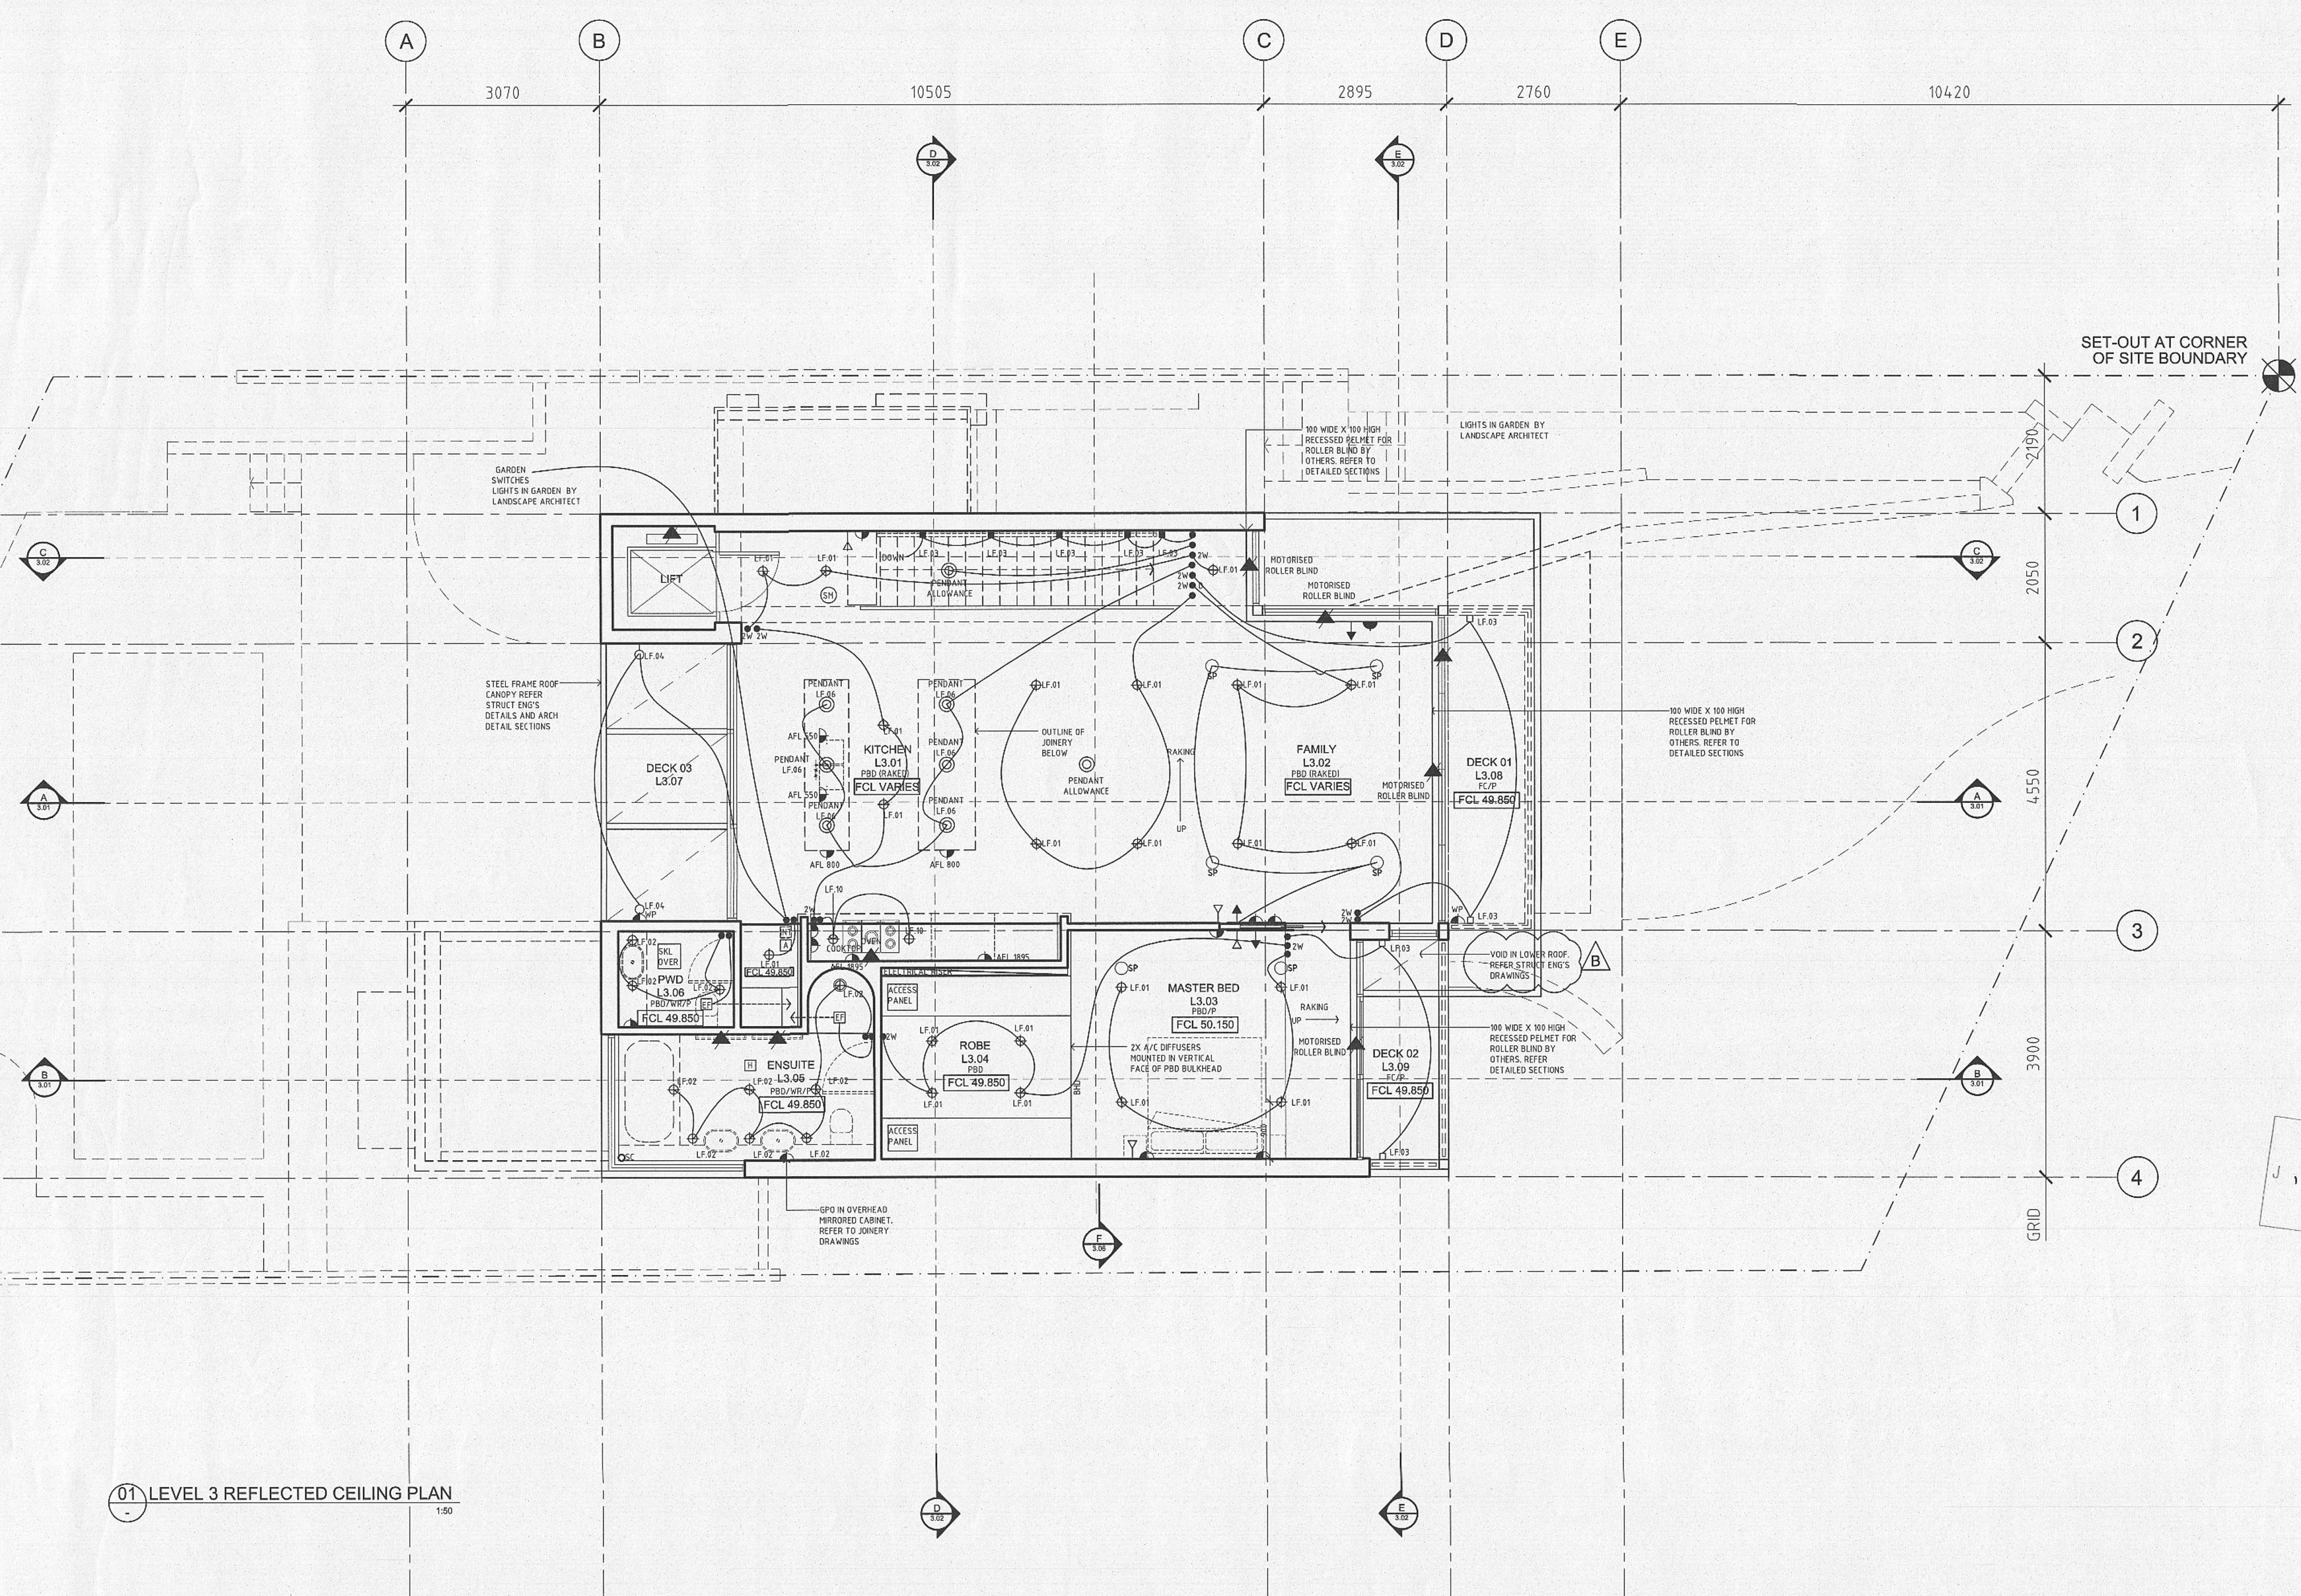


- LEGEND
- TV OUTLET. PROVIDE 2 OUTLETS AT EACH POINT FOR FREE TO AIR + PAY TV + CAT6
 - DUAL PHONE + DATA OUTLET. (DEDICATED) CONNECT ALL PHONE AND DATA BACK TO PATCH PANEL
 - CEILING MOUNTED EXHAUST FAN
 - UNDERFLOOR HEATING ZONE
 - UNDERFLOOR HEATING THERMOSTAT /
 - SPEAKER MOUNTED IN CEILING
 - SENSOR (MOVEMENT)
 - INTERCOM
 - METER BOX
 - ELECTRONIC DOOR OPENER
 - ALARM PAD
 - WATERPROOF DOUBLE GPO. MOUNTED AT 200 AFFL
 - DOUBLE GENERAL PURPOSE OUTLET. MOUNT AT 300 AFFL UNLESS OTHERWISE INDICATED
 - SINGLE GENERAL PURPOSE OUTLET. MOUNT AT 300 AFFL UNLESS OTHERWISE INDICATED
 - MICRO SWITCH IN ROBE
 - CONTACT
 - HARDWIRED POINT. REFER TO APPLIANCE MANUFACTURERS TECHNICAL DETAILS
 - SWITCHING POINT. MOUNT ON WALL ONLY (NOT ARCHITRAVED). GROUP SWITCHING AS INDICATED. SEEK ARCHITECTS APPROVAL FOR SWITCH GROUPING AND MOUNTING
 - INDICATED 2 OR 3 WAY SWITCHING
 - DIMMABLE CIRCUIT. REFER TO LIGHTING MANUFACTURERS TECHNICAL INFORMATION
 - A/C CONTROL
 - BH BULKHEAD
 - CEILING MOUNTED LIGHT FITTING. REFER TO LF NUMBER
 - IN GROUND UP-LIGHT FITTING. REFER TO LF NUMBER
 - CONTINUOUS STRIP LIGHTING. REFER TO LF NUMBER
 - PENDANT LIGHT. REFER TO LF NUMBER
 - RECESSED WALL LIGHT. REFER TO LF NUMBER
 - WALL LIGHT. REFER TO LF NUMBER
 - GARDEN LIGHT. REFER TO LF NUMBER
 - FLUORESCENT SURFACE MOUNTED LIGHT
 - LINEAR PENDANT REFER TO LF NUMBER
 - CEILING MOUNTED LINEAR DIFFUSER. GENERALLY, REFER TO MECHANICAL ENGINEER'S DRAWINGS FOR SIZES OF DIFFUSERS AND RETURN AIR GRILLES
 - RETURN AIR GRILLE. REFER TO MECHANICAL ENGINEER'S DRAWINGS FOR SIZING
 - ACCESS PANEL. REFER TO MECHANICAL ENGINEER'S DRAWINGS FOR SIZING
 - SMOKE ALARM

This Plan/Specification forms part of the certification for
J 1 0 0 1 4 7 B 2 1 JUN 2011


01 LEVEL 3 REFLECTED CEILING PLAN
1:50

REV.	DATE	DOCUMENT STATUS/ AMENDMENTS	ABBREVIATIONS:	CONSULTANTS	PROJECT	Drawn SN	Date
P1	16.05.10	ISSUE FOR INFORMATION	AL ALUMINIUM	CIVIL/STRUCTURAL/HYDRAULIC ENGINEER	St. Patricks Estate Manly	DS	MARCH 2011
A	10.05.10	ISSUE FOR TENDER	AW ALUMINIUM WINDOW	BUSHFIRE CONSULTANT	PRECINCT 1 STAGE 4	Architect Authorised	Scale 1:50
B	09.06.10	ISSUE FOR TENDER	BAL BALUSTRADE	LANDSCAPE ARCHITECTS	Client LEND LEASE	Client LEND LEASE	Status CONSTRUCTION
C	23.03.11	ISSUE FOR CONSTRUCTION	BK BRICK	MECHANICAL ENGINEER	Job Number 07 0581	Drawing No. / Issue AMP22-1.07/C	House No. HOUSE 22
			BL BLOCK	ELECTRICAL ENGINEER			
			CJ CONSTRUCTION JOINT				
			CL CENTRE LINE				
			CO CLEAR OUT				
			CR CEMENT RENDER				
			CTF FLOOR TILE				
			CTW WALL TILE				
			DET DETAIL				
			DP DOWN PIPE				
			EA EQUAL ANGLE				
			FC FIBRE CEMENT				
			FG FIXED GLASS				
			FW FLOOR WASTE				
			GD GLAZED DOOR				
			GL GLASS LOUVRES				
			HW HARDWOOD				
			HYD HYDRAULIC				
			INS INSULATION				
			JN JOINERY NUMBER				
			MDF MEDIUM DENSITY FIBREBOARD				
			MRS METAL ROOF SHEETING				
			OF OVERFLOW				
			PAINT				
			PBD PLASTERBOARD				
			PCP PRE-CAST CONCRETE PAVES				
			PF PARALLEL FLANGE CHANNEL				
			RC REINFORCED CONCRETE				
			RHS RECTANGULAR HOLLOW SECTION				
			RST RECESSED SHADOW TRIM				
			RWO RAINWATER OUTLET				
			SC STEEL COLUMN				
			SHS SLIDING GLASS DOOR				
			SK SQUARE HOLLOW SECTION				
			SK SKIRTING				
			SST STRUCTURAL SILICONE JOINT				
			SWP SANDSTONE				
			SWP STORMWATER PIT				
			IT TIMBER				
			TD TIMBER DECKING				
			TB TIMBER BATTENS				
			UA UNEQUAL ANGLE				
			UC UNIVERSAL CHANNEL				
			VOS VERIFY ON SITE				
			WPM WATERPROOF MEMBRANE				

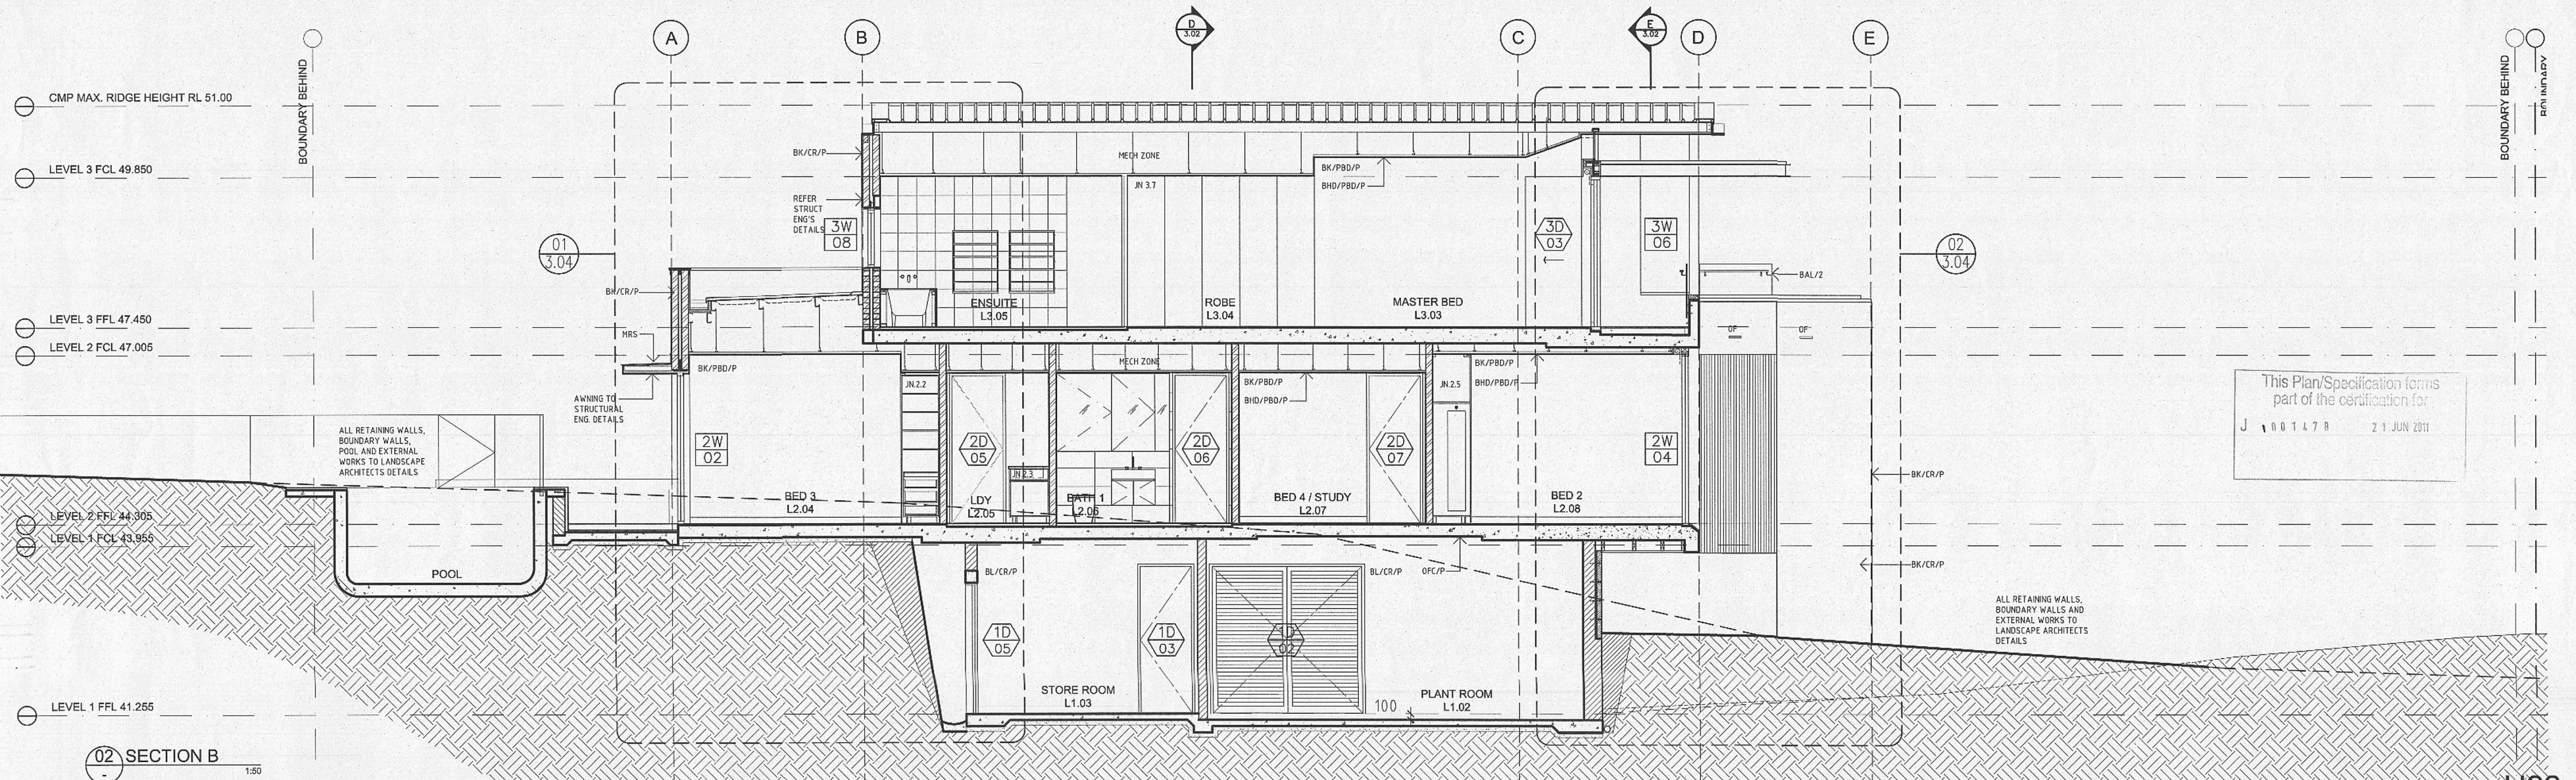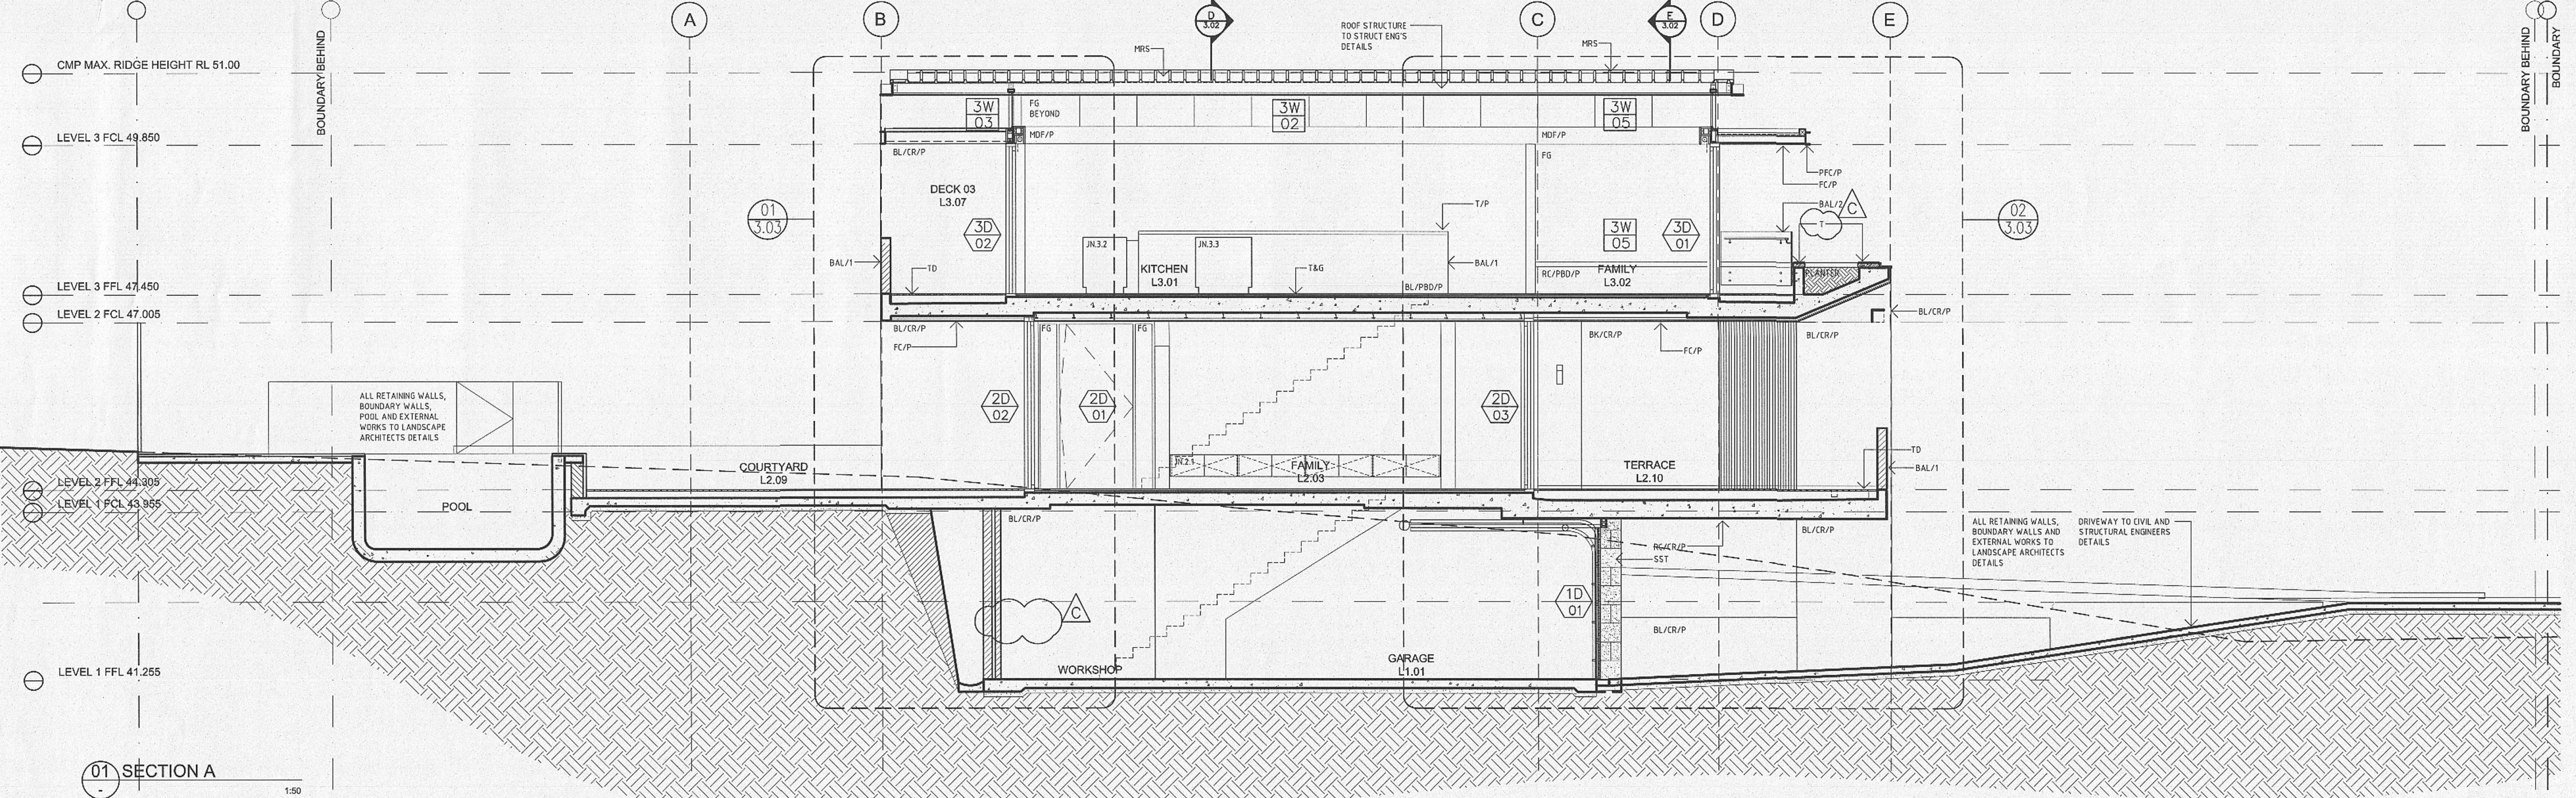

REV	DATE	DOCUMENT STATUS/ AMENDMENTS	ABBREVIATIONS:	CONSULTANTS	PROJECT	Drawn	Date
A	10.05.10	ISSUE FOR TENDER	AL ALUMINIUM	CIVIL/ STRUCTURAL/	St. Patricks Estate Manly	JS	MARCH 2011
B	09.06.10	ISSUE FOR TENDER ADDENDUM	AW ALUMINIUM WINDOW	HYDRAULIC ENGINEER	PRECINCT 1 STAGE 4	DS	Scale 1:50
C	23.03.11	ISSUE FOR CONSTRUCTION	BAL BALUSTRADE	HERITAGE CONSULTANT	for LEND LEASE	Client	Status CONSTRUCTION
			BHD BULKHEAD	LANDSCAPE ARCHITECTS		LEND LEASE	File
			BK BRICK	MANLY			
			BL BLOCK	MECHANICAL ENGINEER			
			CJ CONSTRUCTION JOINT	Efficient Living			
			CL CENTRE LINE	ATP Electrical			
			CO CLEAR OUT	Surveyor			
			CR CEMENT RENDER	Planner			
			CTF FLOOR TILE				
			CTW WALL TILE				
			DET DETAIL				
			DP DOWN PIPE				
			EA EQUAL ANGLE				
			FC FIBRE CEMENT				
			FG FIXED GLASS				
			FW FLOOR WASTE				
			GL GLAZED DOOR				
			GW GLASS LOUVRES				
			HW HARDWOOD				
			HYD HYDRAULIC				
			INS INSULATION				
			JN JOINERY NUMBER				
			MDF MEDIUM DENSITY FIBREBOARD				
			MRS METAL ROOF SHEETING				
			OF OVERFLOW				
			PAINT				
			PB PLASTERBOARD				
			PCP PRE-CAST CONCRETE PAVER				
			PB PLASTERBOARD				
			RC REINFORCED CONCRETE				
			RHS RECTANGULAR HOLLOW SECTION				
			RST RECESSED SHADOW TRIM				
			RWO RAINWATER OUTLET				
			SC STEEL COLUMN				
			SGD SLIDING GLASS DOOR				
			SHS SQUARE HOLLOW SECTION				
			SK SKIRTING				
			SSJ STRUCTURAL SILICONE JOINT				
			SST SANDSTONE				
			SWP STORMWATER PIT				
			TD TIMBER				
			TD TIMBER DECKING				
			TB TIMBER BATTENS				
			UA UNEQUAL ANGLE				
			UC UNIVERSAL CHANNEL				
			VOS VERIFY ON SITE				
			WPM WATERPROOF MEMBRANE				

H22

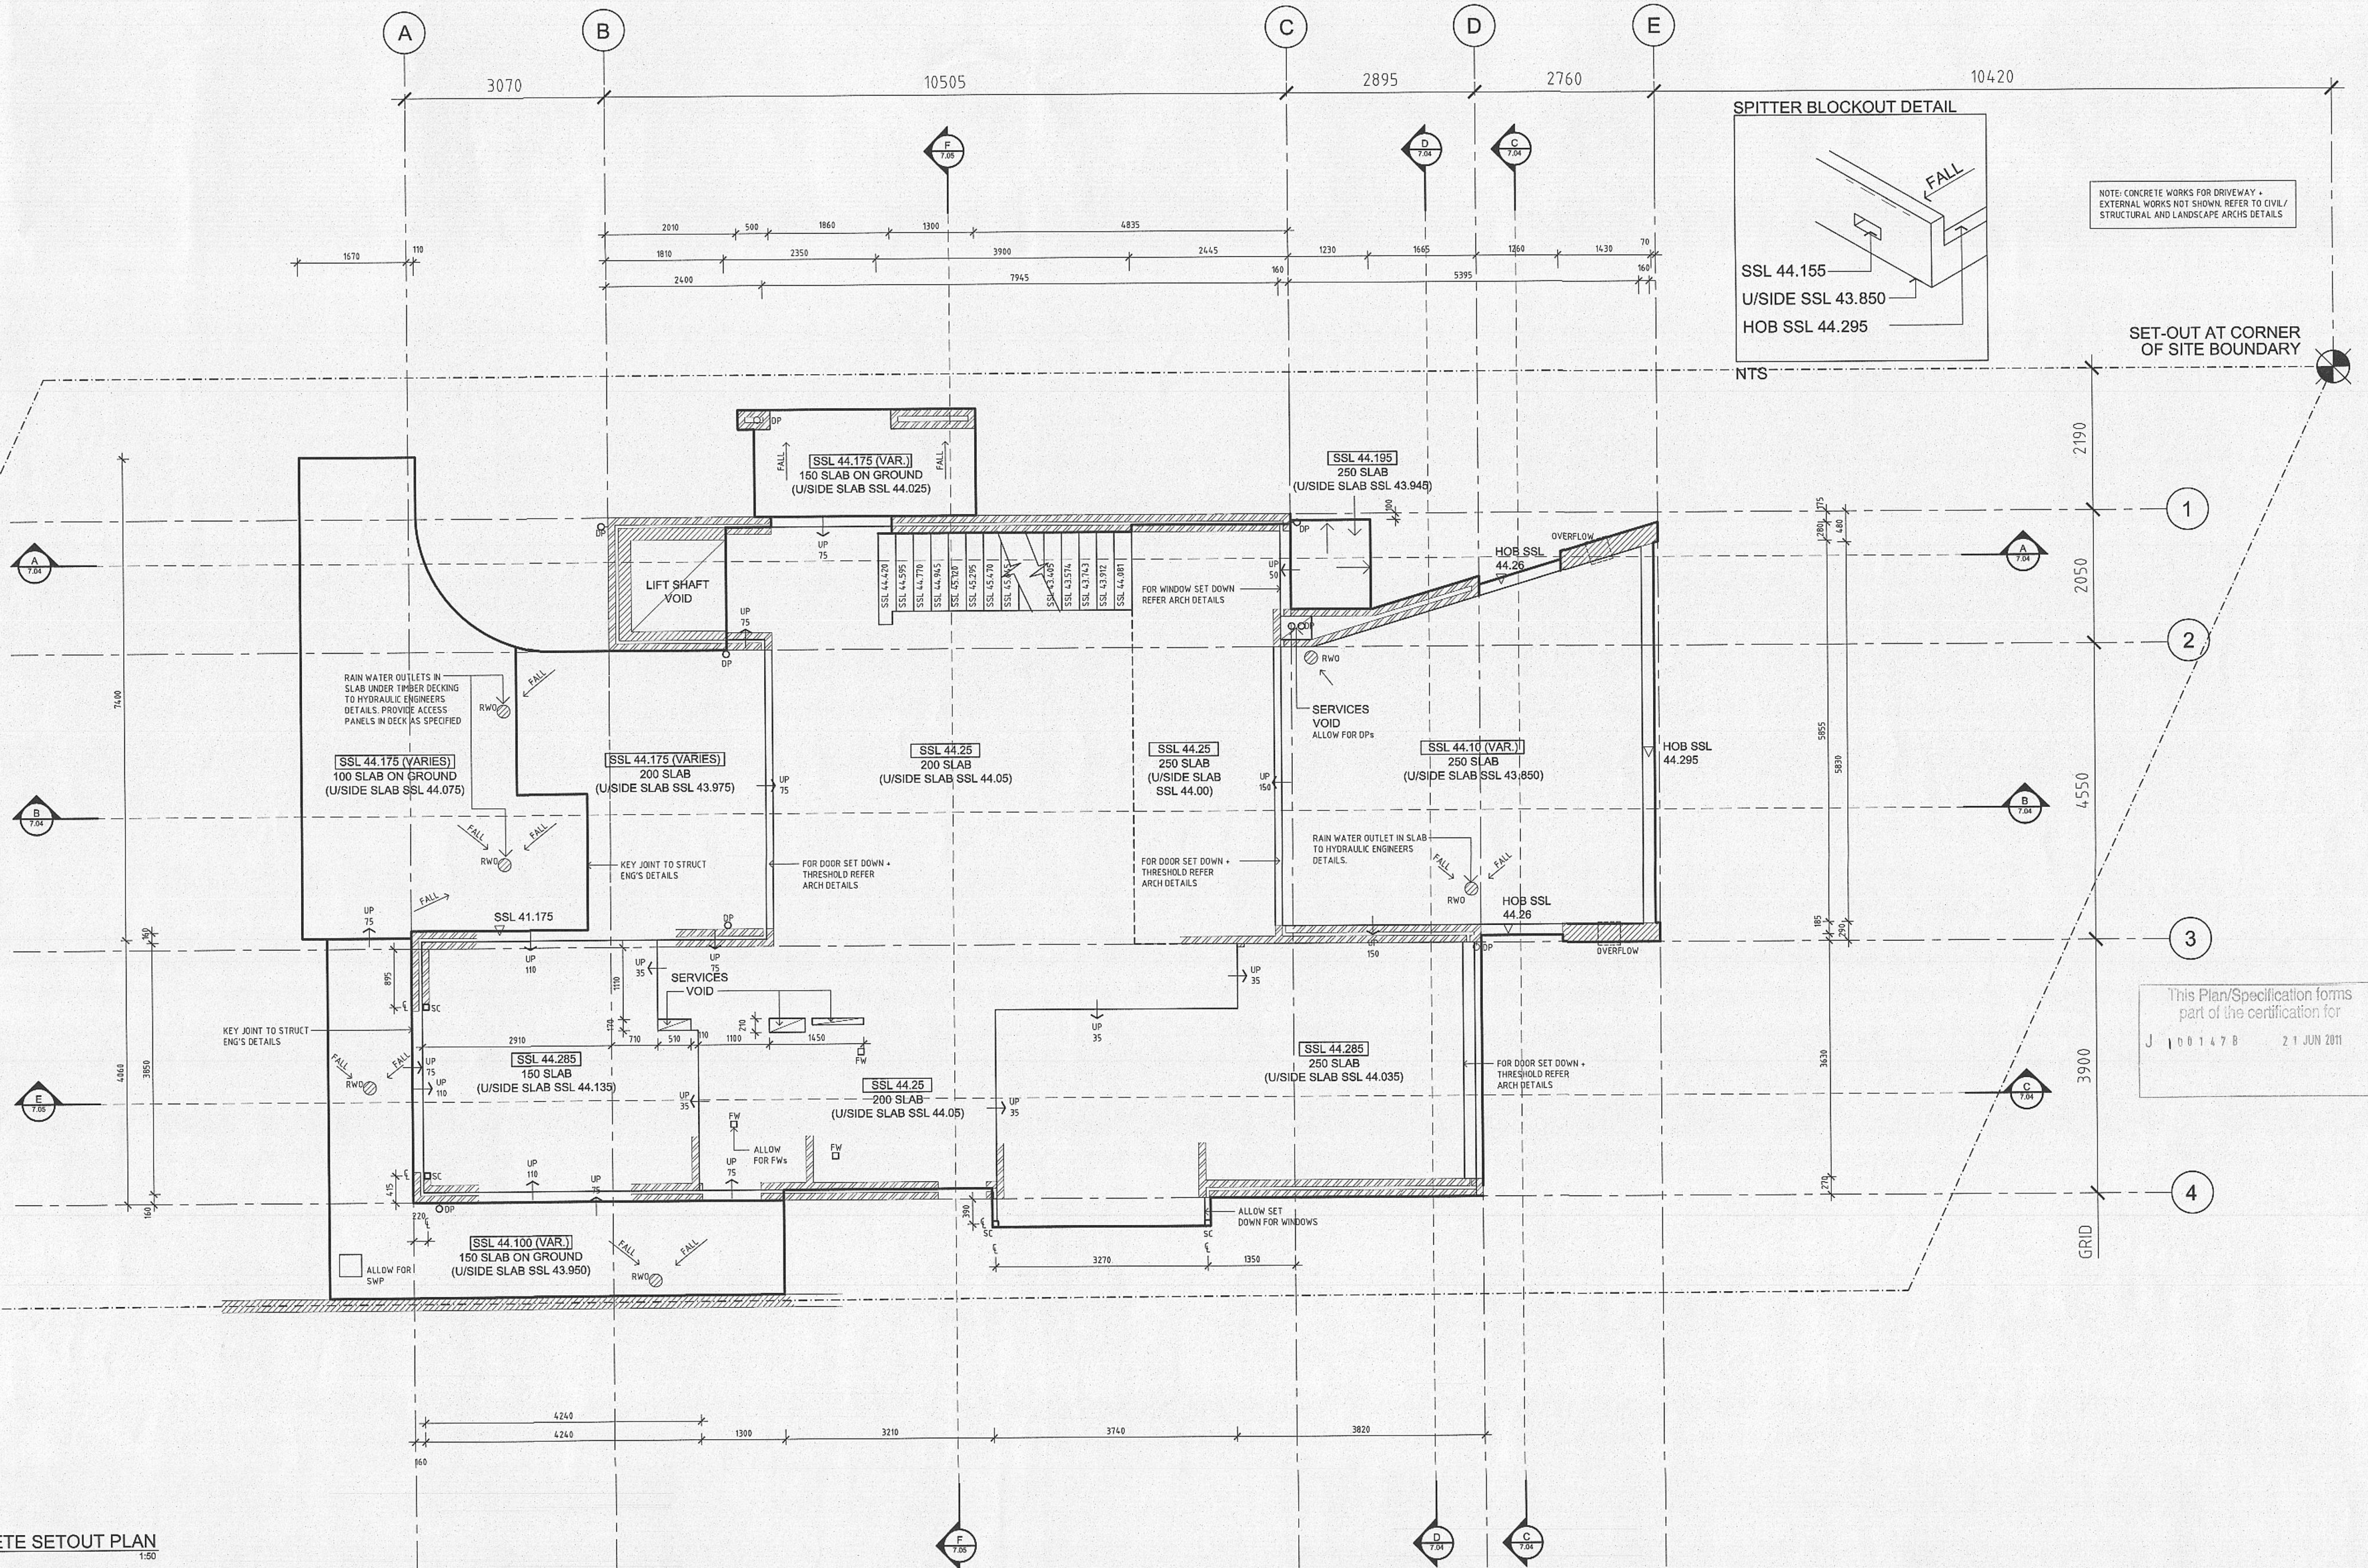

H22

REV:	DATE:	DOCUMENT STATUS/AMENDMENTS	ABBREVIATIONS:	CONSULTANTS	PROJECT	Drawn	Date
A	23.03.11	ISSUE FOR CONSTRUCTION	AL ALUMINIUM WINDOW BAI BALLUSTRADE BHD BULKHEAD BK BRICK BLOC BLOCK BL BLOCK CJ CONSTRUCTION JOINT CL CENTRE LINE CO CLEAR OUT CR CEMENT RENDER CTF FLOOR TILE	CIVIL/STRUCTURAL/HYDRAULIC ENGINEER Hughie Thompson Tel: 9439 2633 LANDSCAPE ARCHITECTS Manly Design Tel: 9400 112 632 MECHANICAL ENGINEER Terry Thompson PM Tel: 9299 4039 ELECTRICAL ENGINEER ATP Electrical Tel: 9913 1066	St. Patricks Estate Manly PRECINCT 1 STAGE 4 LEND LEASE	JS	MARCH 2011
			CTW WALL TILE DET DETAIL DP DOWN PIPE EA EQUAL ANGLE FC FIBRE CEMENT FG FIXED GLASS FW FLOOR WASTE GD GLAZED DOOR GL GLASS LOUVRES HW HARDWOOD HYD HYDRAULIC	RST RECESSED SHADOW TRIM RWO RAINWATER OUTLET SC STEEL COLUMN SGD SLIDING GLASS DOOR SHS SQUARE HOLLOW SECTION SK SKIRTING SSJ STRUCTURAL SILICONE JOINT SST SANDSTONE SWP STORMWATER PIT TD TIMBER DECKING	BUSHFIRE CONSULTANT Building Code & Bushfire Tel: 9437 4539 HERITAGE CONSULTANT Tanner Architects Tel: 9281 4399 BASIX CONSULTANT Efficient Living Tel: 9971 0023 SURVEYOR Whittaker Tel: 9234 8300 PLANNER Ingham Planning Tel: 9416 9111	Client LEND LEASE	Scale 1:50 Status CONSTRUCTION File S:\Projects\St. Patricks Estate Manly\Stage 4\13 Stage 4\1301\130101\130101.dwg
			INS INSULATION JF JOINERY NUMBER MDF MEDIUM DENSITY FIBREBOARD MRS METAL ROOF SHEETING OF OVERFLOW P PAINT PBD PLASTERBOARD PCP PRE-CAST CONCRETE PAVES PFC PARALLEL FLANGE CHANNEL RC REINFORCED CONCRETE RHS RECTANGULAR HOLLOW SECTION	TB TIMBER BATTENS UA UNEQUAL ANGLE UC UNIVERSAL CHANNEL VOS VERIFY ON SITE WPM WATERPROOF MEMBRANE	JOB NUMBER 07 0581 DRAWING NO. / ISSUE AMP22-7.02/A HOUSE NO. HOUSE 22		

MONTPELIER PLACE, MANLY - HOUSE 22

St Patrick's Estate - Precincts 1+13

AMP 22-0.01	DRAWING SCHEDULE	NTS
AMP 22-1.01	SITE/ROOF PLAN	1:50
AMP 22-1.02	LEVEL 1 FLOOR PLAN	1:50
AMP 22-1.03	LEVEL 2 FLOOR PLAN	1:50
AMP 22-1.04	LEVEL 3 FLOOR PLAN	1:50
AMP 22-1.05	LEVEL 1 ELECTRICAL, LIGHTING & RCP	1:50
AMP 22-1.06	LEVEL 2 ELECTRICAL, LIGHTING & RCP	1:50
AMP 22-1.07	LEVEL 3 ELECTRICAL, LIGHTING & RCP	1:50
AMP 22-2.01	ELEVATIONS SHEET 1	1:50
AMP 22-2.02	ELEVATIONS SHEET 2	1:50
AMP 22-3.01	SECTIONS SHEET 1	1:50
AMP 22-3.02	SECTIONS SHEET 2	1:50
AMP 22-3.03	DETAILS SECTIONS SHEET 1	1:20
AMP 22-3.04	DETAILS SECTIONS SHEET 2	1:20
AMP 22-3.05	DETAILS SECTIONS SHEET 3	1:20
AMP 22-3.06	DETAILS SECTIONS SHEET 4	1:20
AMP 22-4.01	DOOR & WINDOW SCHEDULE	1:50
AMP 22-5.01	CONSTRUCTION DETAILS SHEET 1	1:5
AMP 22-5.02	CONSTRUCTION DETAILS SHEET 2	1:5
AMP 22-5.03	CONSTRUCTION DETAILS SHEET 3	1:5
AMP 22-5.04	KITCHEN L3.01 (JN 3.3 - 3.4)	1:20 / 1:2
AMP 22-5.05	LAUNDRY L2.05 (JN 2.3)	1:20 / 1:2
AMP 22-5.06	POWDER ROOM L3.06 (JN 3.5)	1:20 / 1:2
AMP 22-5.07	BATHROOM 1 L2.06 (JN 2.4)	1:20 / 1:5 / 1:2
AMP 22-5.08	ENSUITE L3.05 (JN 3.6)	1:20 / 1:2
AMP 22-5.09	JOINERY 01 (JN 2.2, JN 2.5, JN 3.9)	1:20
AMP 22-5.10	JOINERY 02 (JN 3.7, JN 3.8, JN 2.1)	1:20
AMP 22-7.01	LEVEL 1 CONCRETE SETOUT PLAN	1:50
AMP 22-7.02	LEVEL 2 CONCRETE SETOUT PLAN	1:50
AMP 22-7.03	LEVEL 3 CONCRETE SETOUT PLAN	1:50
AMP 22-7.04	CONCRETE SECTIONS SHEET 1	1:50
AMP 22-7.05	CONCRETE SECTIONS SHEET 2	1:50

J 1001478 21 JUN 2011

422

